
## DUCTLESS SPLIT SYSTEM SCHEDULE

MARK MAN	UFACTURER INDO	DOR MODEL OUTDO	DOR MODEL SE	ERVICE CF (HIG		COOLING IBH)
DAHU-1 M	TSUBISHI MS	Z-GLO9NA MUZ-	-GLO9NA2 ECOMM	MERCE RM. 39	9 9(	000

1. PROVIDE WITH REMOTE WALL MOUNTED THERMOSTAT.

4. COORDINATE ROUTING AND INSTALLATION WITH SESCO & OWNER'S CONSTRUCTION SUPERVISOR.

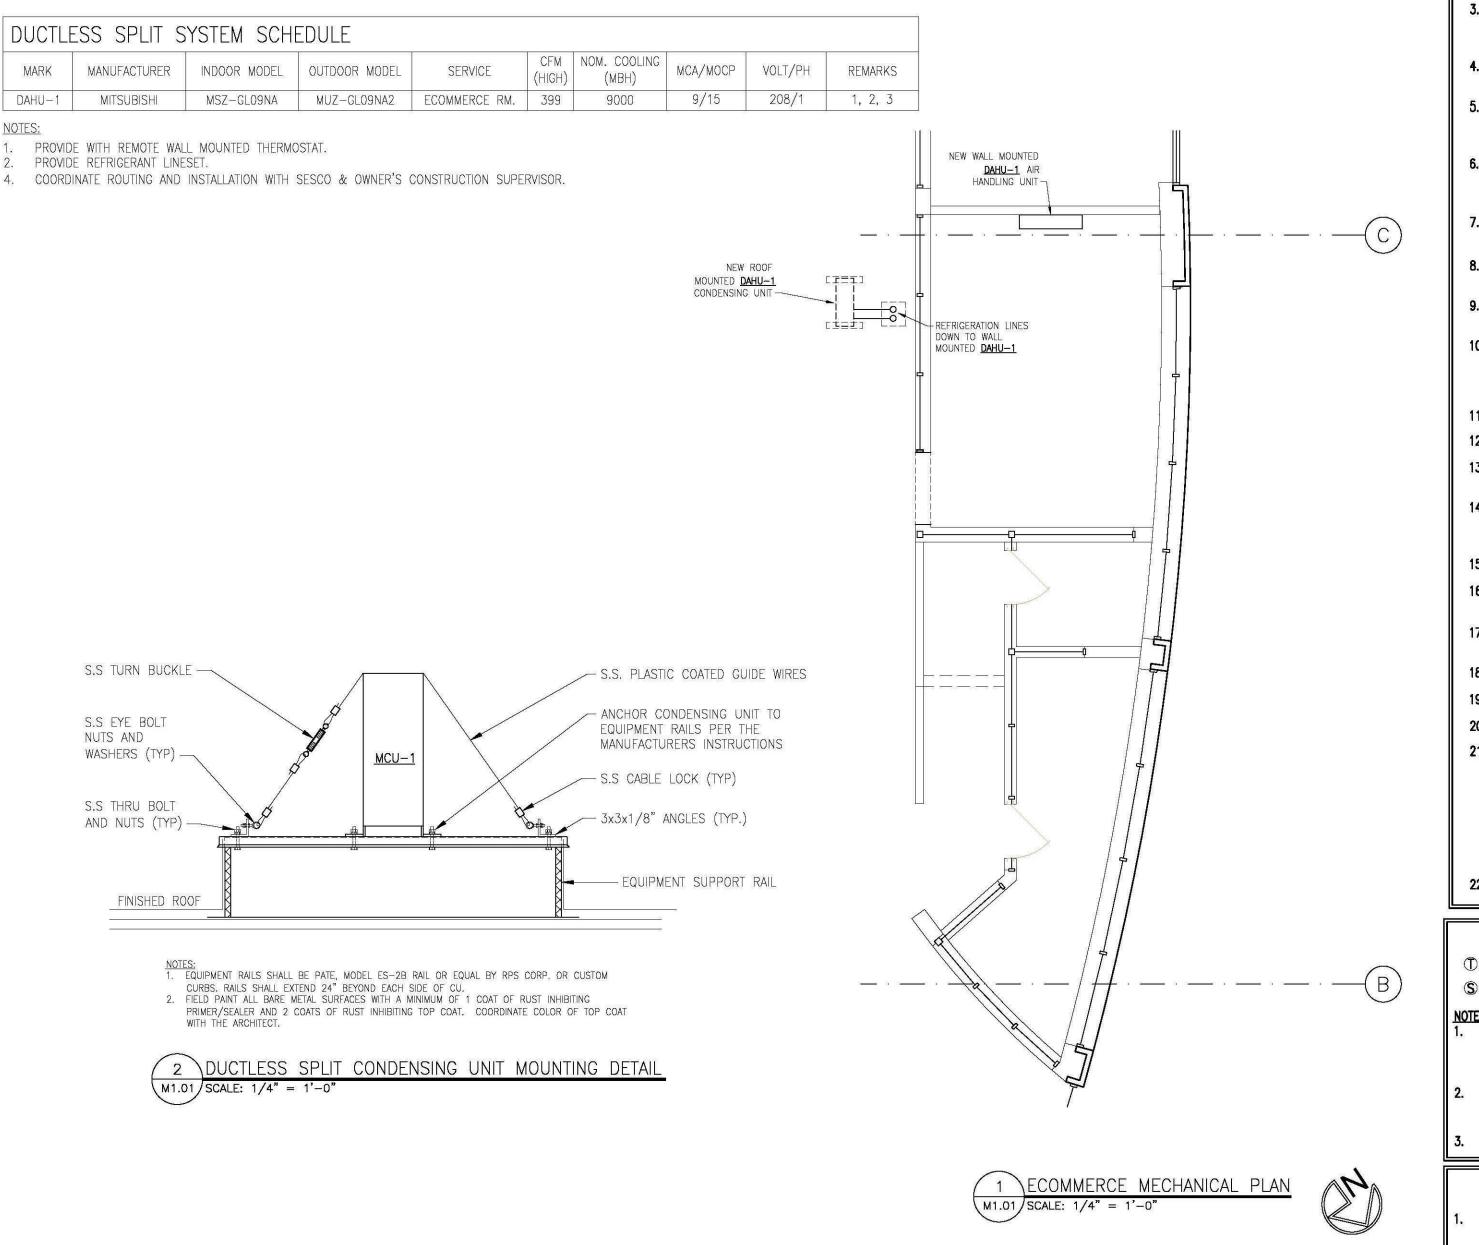

## RENOVATION NOTES SHARED SERVICES GROUP, L.L.C. Construction Manager OF ANY DISCREPANCIES.

- 2. FOR TRANSVERSE JOINTS 12" WIDE AND LARGER, PROPRIETARY DUCT CONNECTORS SHALL BE DUCT MATE OR WARD AND INSTALLED IN COMPLETE ACCORDANCE WITH MANUFACTURERS RECOMMENDATIONS, DUCT SEALANT TO BE DUCT MATE 440 GASKET TYPE OR EQUAL. ALL DUCTWORK SHALL BE CONSTRUCTED TO A 2" PRESSURE CLASS. FOR TRAVERSE JOINTS 11" WIDE OR SMALLER, THE ABOVE MAY BE USED, OR REFER TO SMACNA TO DETERMINE PROPER DUCT CONSTRUCTION FOR THE SPECIFIED PRESSURE CLASS.
- 3. ALL DUCTWORK WITH A WIDTH DIMENSION OF 46" OR LARGER SHALL BE SUPPORTED WITH TRAPEZE TYPE HANGERS. SUPPORTS SHALL BE ATTACHED TO DUCTWORK PRIOR TO APPLICATION OF EXTERNAL INSULATION. INSULATION SHALL BE APPLIED TO COMPLETELY COVER DUCTWORK AND SUPPORTS.
- 4. DUCTS CONNECTING TO NEW AND/OR RELOCATED DIFFUSERS SHALL BE INLET SIZE OF DIFFUSER. PROVIDE VOLUME DAMPER FOR BRANCH TAKEOFF AS INDICATED ON PLAN.
- 5. ALL LONGITUDINAL SEAMS AND NON-GASKETED TRANSVERSE JOINTS SHALL BE EXTERNALLY SEALED WITH HIGH PRESSURE DUCT SEALER BY UNITED MCGILL OR EQUAL. SEALER SHALL BE APPLIED BY M.C. AND APPROVED BY FOOD LION CONSTRUCTION MANAGER BEFORE DUCT INSULATION IS INSTALLED.
- 6. ALL NEW DUCT SIZES SHOWN ARE "INSIDE-CLEAR" DIMENSIONS. ALL NEW DUCTWORK SHALL HAVE 2", 3/4 PCF, EXTERNALLY WRAPPED INSULATION WITH VAPOR BARRIER (SEE SPECIFICATIONS). ROUTE ALL NEW DUCTWORK AS TIGHT TO ROOF JOISTS AS PRACTICAL. COORDINATE ROUTING TO AVOID CONFLICTS WITH OTHER TRADES.
- 7. FLEXIBLE DUCT MAY BE USED AT END OF RUNOUTS IN LENGTHS NOT EXCEEDING 4'-0". INSTALL PER SMACNA STANDARDS (SEE SPECIFICATIONS).
- 8. PROVIDE 90° METAL (24 GA. MINIMUM) DUCT ELBOW WITH 4 PIECE GORE AT ALL CEILING DIFFUSER/GRILLE-TO-FLEX DUCT CONNECTIONS.
- 9. M.C. SHALL VERIFY SIZE OF EXISTING DUCTWORK SCHEDULED TO REMAIN. EQUIPMENT OPENINGS AS REQUIRED FOR PROPER CONNECTION OF NEW TO EXISTING.
- 10. M.C. SHALL INSPECT AND REPAIR DUCTWORK AS REQUIRED TO PROVIDE A TIGHT AIR DISTRIBUTION SYSTEM. M.C. SHALL CAP AND INSULATE ALL OPEN DUCT TERMINATIONS AND OTHER OPENINGS IN EXISTING DUCTWORK DIRECTLY RESULTING FROM OR INCIDENTAL TO DEMOLITION. ALL SUPPLY AND RETURN OUTLETS SHALL BE BALANCED TO THE AIR FLOW QUANTITIES SHOWN ON DRAWINGS.
- 11. M.C. SHALL COORDINATE ALL WORK WITH OTHER TRADES TO AVOID CONFLICTS.
- 12. COORDINATE ALL DIFFUSER AND GRILLE LOCATIONS WITH CEILING GRID AS SHOWN ON ARCHITECTURAL DRAWINGS.
- HEIGHTS, LOCATIONS, AND CONTROL SETTINGS WITH PROPER FOOD LION CONSTRUCTION MANAGER. 14. CONTROL WIRING FOR NEW SENSORS, MOTORIZED DAMPERS, ETC. TO BE FURNISHED AND INSTALLED BY M.C. CONTROL WIRING SHALL BE ROUTED TO ECP/EMCC PANELS UNLESS OTHERWISE INDICATED. E.C. SHALL PROVIDE CONDUIT SYSTEM
- WITH PULL STRINGS. COORDINATE CONTROL WORK WITH PROPER FOOD LION CONSTRUCTION MANAGER. 15. EXISTING MOTOR STARTER CONTROLS FOR THE MACHINE ROOM TO BE WIRED TO ECP.
- 16. ALL SENSOR CONTROL WIRING SHALL BE SHIELDED (MINIMUM #22 AWG OR LARGER). CONTROL WIRING SHALL BE STRANDED (#14 AWG). DO NOT MIX SENSOR CABLE AND CONTROL WIRING IN SAME CONDUIT.
- 17. M.C. TO COORDINATE DUCTWORK SIZES WITH CLEARANCES ABOVE CEILING. M.C. TO NOTIFY PROPER FOOD LION CONSTRUCTION MANAGER OF ANY CONFLICTS.
- 18. REFER TO SPECIFICATIONS, DIVISION 23 SECTIONS FOR ADDITIONAL MECHANICAL REQUIREMENTS.
- 19. MECHANICAL CONTRACTOR IS RESPONSIBLE FOR CONNECTING/RECONNECTING AHU DRAINS.
- 20. ALL EXHAUST HOODS SHALL BE INSTALLED 6'-8" ABOVE FINISHED FLOOR UNLESS NOTED OTHERWISE. 21. THE MECHANICAL CONTRACTOR SHALL BE RESPONSIBLE FOR ALL LABOR, MATERIAL AND WORKMANSHIP INSTALLED BY HIM UNDER THIS SECTION OF THE SPECIFICATIONS AND TO CORRECT ANY DEFICIENCIES ADJUDGED BY FOOD LION. THIS GUARANTEE SHALL EXTEND FOR A PERIOD OF NOT LESS THAN TWELVE (12) MONTHS FROM THE DATE OF THE FINAL PROJECT ACCEPTANCE BY FOOD LION SHARED SERVICES GROUP, L.L.C., AGAINST ANY DEFECTS OR SYSTEM FAILURE. ALL EQUIPMENT MANUFACTURERS' WARRANTIES WHICH EXTEND BEYOND THE FIRST TWELVE (12) MONTHS SHALL BE TRANSFERRED TO FOOD LION. HOWEVER, IT SHALL BE UNDERSTOOD BY ALL PARTIES CONCERNED THAT THE WARRANTIES PERTAIN ONLY TO FURNISHING OF MATERIAL BY THE MANUFACTURER AND SHALL NOT INCLUDE REPLACEMENT LABOR COSTS, UNLESS OTHERWISE DESCRIBED BY THE MANUFACTURER.
- 22. ENGINEER OF RECORD TO PROVIDE ALL SEISMIC REQUIREMENTS WHEN APPLICABLE.

			SENSOR LEG	EN
Ū	THERMOSTAT	SRH	RELATIVE HUMIDITY	
®₁	TEMPERATURE	(S) <sub>SD</sub>	SMOKE DETECTOR	
2.	THE E.C. IS RESPONSIBLE FOR CONTROLLER. THIS WILL BE IN T CONTROLLERS OR 4-WIRE SHIEL COORDINATE WITH SESCO OR EN MC SHALL PROVIDE (1) PAIR O EXISTING AND/OR NEW ECP FOR MAKE FINAL TERMINATION AND P NEW AND/OR EXISTING SENSOR	The Form of Ded Cable 1 Iergy Team 1 F Control 1 R Reclaim He Anel Modific	F CAT5 CABLES FOR EAC WITH STORES THAT HAVE MEMBER. WIRES FROM EACH EXIST EAT STAGING. EC SHALL CATIONS AS REQUIRED.	CH CC E EARI ING A PROV
1.	ALL CONTROL WIRING PROVIDED			s to

- ALLOWED. ALL SHIELDED CABLE IS TO BE 22 GA. OR LARGER. ALL WIRING SHALL BE IN CONDUIT PROVIDED BY ELECTRICIAN. SENSOR CABLE CANNOT BE IN THE SAME CONDUIT AS THE CONTROL WIRING. TERMINATIONS FOR THE MECHANICAL CONTROLS BY MECHANICAL CONTRACTOR.
- WHEN DIRECTED BY FOOD LION, M.C. WILL BE RESPONSIBLE FOR REMOVING ALL OLD SMOKE DETECTORS. ONCE SYSTEM HAS BEEN SWITCHED OVER TO FIRE ALARM CONTACT, SESCO WILL NOTIFY G.C. IN WRITING. M.C. WILL THEN REMOVE OLD DETECTORS. WIRING FROM DETECTORS IS TO BE REMOVED TO ASSOCIATED JUNCTION BOXES AND CAPPED OFF WITH WIRE NUTS. WIRING FROM ECP TERMINALS IS TO BE REMOVED TO WIRING TROUGH AND CAPPED OFF WITH WIRE NUTS.

. M.C. SHALL FIELD VERIFY ALL EXISTING CONDITIONS AT THE JOB SITE PRIOR TO BEGINNING WORK. NOTIFY FOOD LION

13. TEMPERATURE AND HUMIDITY SENSORS AND CONTROLS SHALL BE MOUNTED @ 5'-8" A.F.F. U.N.O. VERIFY MOUNTING

(S) AIR PRESSURE SWITCH SAS DISCHARGE AIR SENSOR

ALL REFRIGERATION CONTROLLERS AND THE HVAC CONTROLLER WITH STORES THAT HAVE E-2 RLIER VERSIONS OF CPC CONTROLLERS.

AND OR NEW REFRIGERATION RACK TO THE DVIDE REQUIRED CONDUIT. EMS PERSONNEL SHALL

ND CONNECTIONS TO ECP/EMCC AS APPLICABLE.

D BE 14 GA. STRANDED. BX CABLE IS NOT

CUHACI PETERSON 2600 Maitland Center Parkway Suite #200 Maitland, FL 32751

> P (407) 661-9100 F (407) 661-9101 c-p.com Florida Corporate Certificate #AA C000526

## PYRIGHT © 2021 - ALL REPORTS, PLANS, SPECIFICATIONS, COMPUT LES, FIELD DATA, NOTES & OTHER DOCUMENTS ARE INSTRUMENTS SERVICE PREPARED BY: CUHACI PETERSON, (CP) AS INSTRUMENTS ( SERVICE REMAIN THE PROPERTY OF CP. CP SHALL RETAIN ALL COMMC LAW, STATUTORY, AND OTHER RESERVED RIGHTS, INCLUDING THE COPYRIGHT THERETO, ANY USE OR REPRODUCTION OF THIS DOCUMEN WITHOUT WRITTEN PERMISSION FROM CP IS A VIOLATION OF FEDERAL COPYRIGHT LAWS.

ARCHITECT/ENGINEER SEAL



CONSULTANT



## FOOD 鴉 LION

2110 EXECUTIVE DRIVE SALISBURY, NC 28145 PH: 704-633-8250 FX: 704-636-4940

<b>REVISION / ISSUE HISTORY</b>							
REV	DATE REVISION / ISSUE NAME						
-	04/14/2023 PERMI		T				
-							
-							
	5						
-							
	ECT NO		DRAWN BY				
222	0380		HM				
PERMI	T SUB DATE		CHECKED BY				
04/1	4/2023		CC				
PROJE	ECT						
FC		N ST	ORF #2594				
FOOD LION STORE #2594							
3260 RAY ROAD SPRING LAKE, NC 28390							
Sector Subscratters	4FLMK23						
CLIEN	T						
FC	OD LIC	N					
83 - 1948 1		- 15 - 558s					
2110 EXECUTIVE DRIVE							
SALISBURY, NC 28145							
PH: 704-633-8250 F: 704-636-5940							
ECOMMERCE							
ME	MECHANICAL PLAN						

2594M1.01\_00

M1.01

REV

SHEET NO