

■ ARCHITECT

RON W. WEBB 1659 W. HANRAHAN ROAD AYDEN, NC. 28513 TEL: (252) 531-2711

WEBB MT PISGAH

145 PROSPECT CHURCH RD ERWIN, NC 28339



120 SOMMERVILLE PARK ROAD RALEIGH, NC 27603 NC FIRM# C-3824

For Construction
Not for Construction

Review Set

written consent of Ron W. Webb Architect. These plans are copyrighted and are subject to copyright protection as an "Architectural Work" under Sec. 102 of the Copyright Act, 17 U.S.O. as amended December 1990 and known as Architectural Works Copyright Protection Act of 1990

© COPYRIGHT 2020

All drawings and copies thereof are instruments of service and as such remain the property of Ron W. Webb Architect They are to be used only with respect

to this project. With the exception of one complete set for each party to the contract, all copies are to be returned or accounted for to Ron W. Webb Architect

upon completion of the work. None or part of these drawings may be reproduced without the express

Issue Date: Issue Date


Plot Date: 10/23/2023 4:27:03 PM Revisions


	Mark	Date	Description

PLAN

FIRE ALARM PLAN


E60'

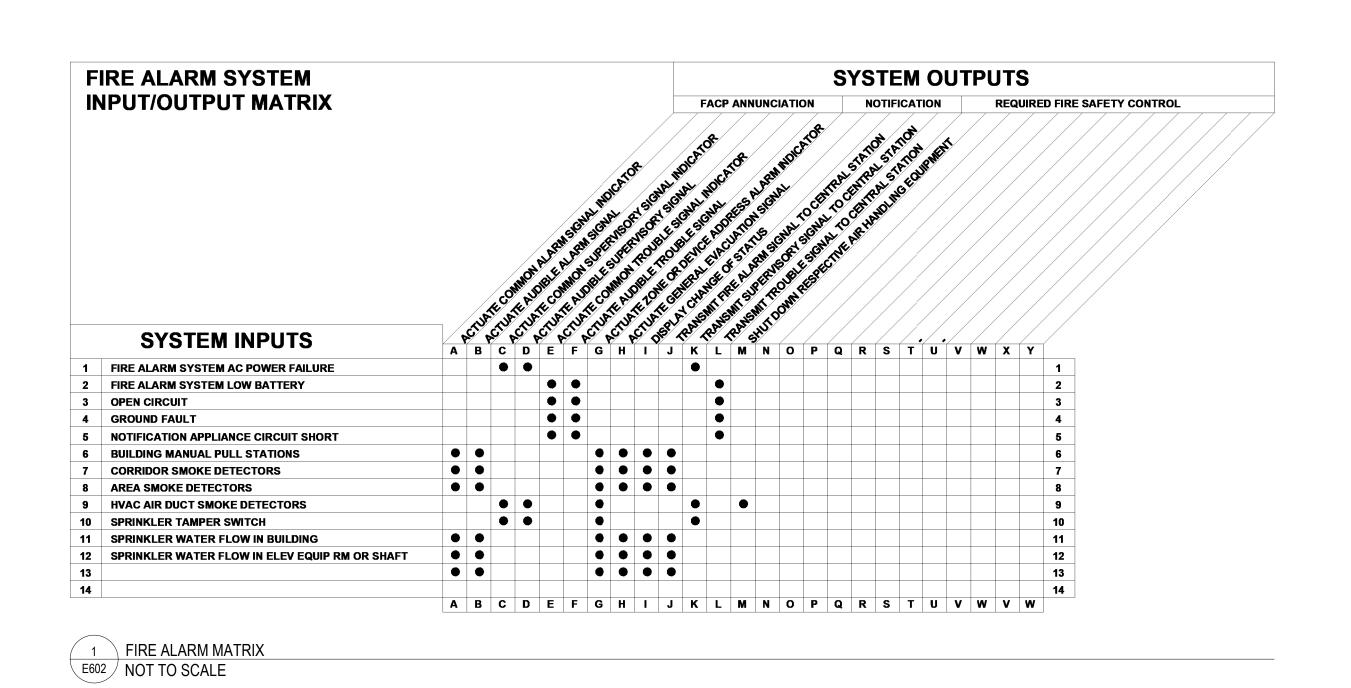


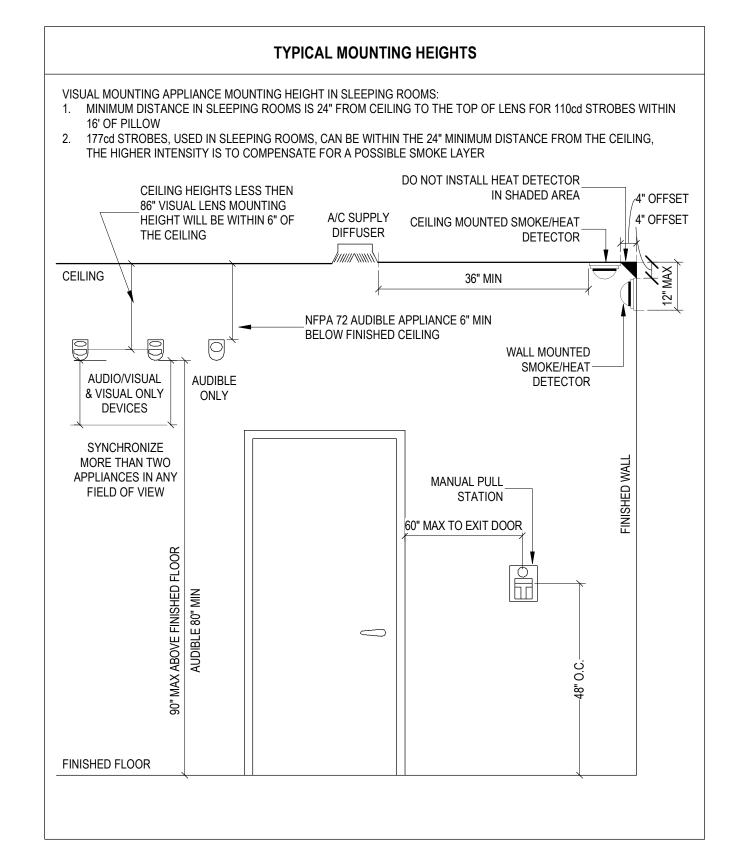

2 TYPICAL MOUNTING HEIGHTS E602 NOT TO SCALE

SEE FIRE ALARM SHOP DRAWING FOR NUMBER OF LOOPS REQUIRED TO SUPPORT HORN/STROBE CURRENT DRAW.

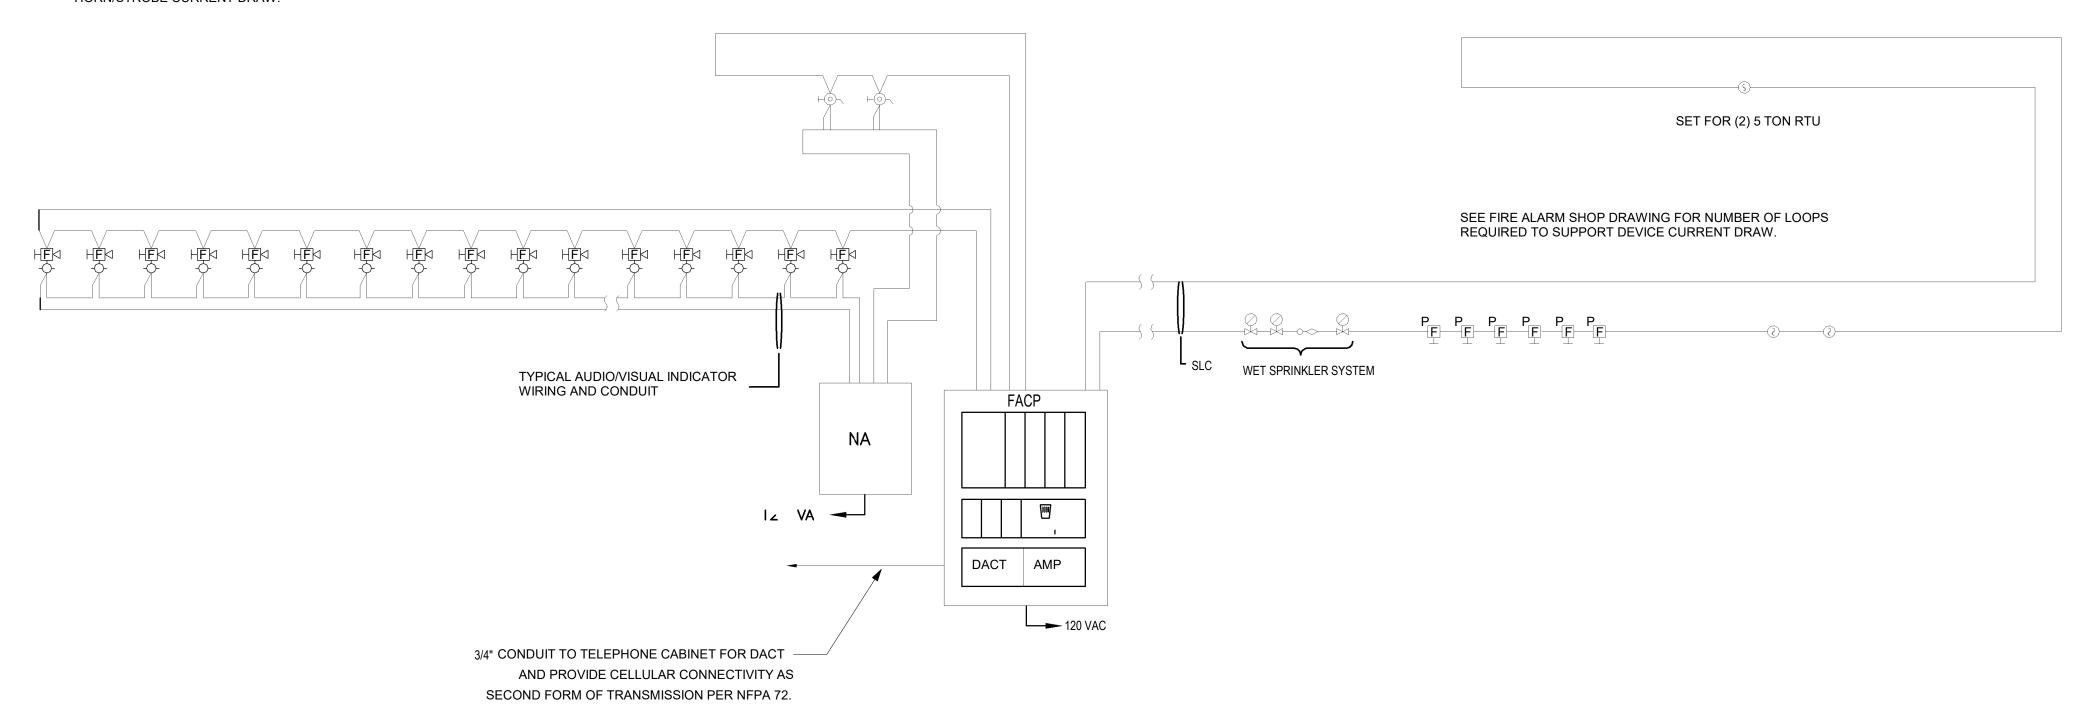

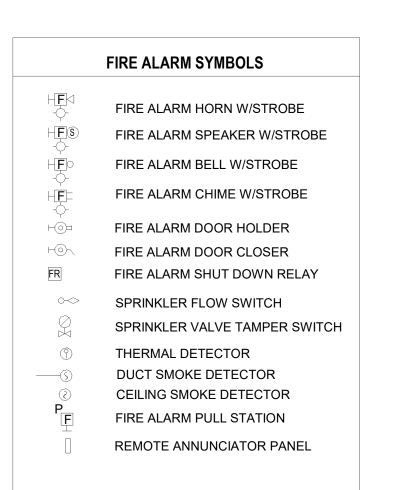

REFER TO FIRE ALARM SHOP DRAWINGS FOR MAKE/MODEL OF DEVICES.

3 FIRE ALARM RISER E602 NOT TO SCALE

■ ARCHITECT

RON W. WEBB 1659 W. HANRAHAN ROAD **AYDEN, NC. 28513** TEL: (252) 531-2711

WEBB MT PISGAH

145 PROSPECT CHURCH RD **ERWIN, NC 28339**



120 SOMMERVILLE PARK ROAD RALEIGH, NC 27603 NC FIRM # C-3824

All drawings and copies thereof are instruments of Construction service and as such remain the property of Ron W. Webb Architect They are to be used only with respect Not for Construction to this project. With the exception of one complete set for each party to the contract, all copies are to be returned or accounted for to Ron W. Webb Architect upon completion of the work. None or part of these drawings may be reproduced without the express written consent of Ron W. Webb Architect. These plans are copyrighted and are subject to copyright protection as an "Architectural Work" under Sec. 102 of the Copyright Act, 17 U.S.O. as amended

December 1990 and known as Architectural Works

Copyright Protection Act of 1990

© COPYRIGHT 2020 Issue Date: Issue Date

Plot Date: 10/23/2023 4:27:05 PM Revisions

	Mark	Date	Description
-			
Į			

FIRE ALARM DETAILS

Drawing No.