# Residence for

# Adams Homes AEC, LLC Builder Plan 2131 "A" FE (L) CS007

### GENERAL NOTES

- I. ALL WORK IS TO BE DONE IN STRICT ACCORDANCE WITH NORTH CAROLINA STATE RESIDENTIAL BUILDING CODE, 2018 EDITION (HEREWITH SHOWN AS N.C.S.R.B.C.).
- 2. DIMENSIONS SHOWN ON DRAWINGS GOVERN OVER SCALE.
- 3. STUD WALL DESIGN SHALL CONFORM TO ALL N.C.S.R.B.C. REQUIREMENTS.
- 4. CONTRACTOR SHALL USE TEMPERED SAFETY GLASS IN ALL LOCATIONS AS REQUIRED BY N.C.S.R.B.C., 2018 EDITION, SECTION R308.4
- 5. ANY HABITABLE ROOM SHALL MEET ALL LIGHT/VENTILATION AND EGRESS AS REQUIRED BY N.C.S.R.B.C., 2018 EDITION, SECTIONS R-303.1 AND R-310.1
- 6. ALL WALLS SHOWN ON FLOOR PLANS ARE 2x4 FRAME UNLESS NOTED OTHERWISE.
- 7. ALL ANGLED WALLS SHOWN ON FLOOR PLANS ARE 45° UNLESS NOTED OTHERWISE.
- 8. ALL MINDOWS SHALL HAVE A MINIMUM DPI RATING OF 25. BUILDER SHALL VERIFY WITH MINDOW MANUFACTURER THAT UNITS INSTALLED MEET THESE REQUIREMENTS AS PER N.C.S.R.B.C., 2018 EDITION, TABLE 301.2(6).
- 9. ENERGY EFFICIENCY REQUIREMENTS FOR THE SPECIFIC CLIMATE ZONE WHERE STRUCTURE IS BEING BUILT SHALL BE IN ACCORDANCE WITH CHAPTER II OF THE NORTH CAROLINA RESIDENTIAL BUILDING CODE, 2018 EDITION, AS SHOWN IN TABLES NIIO1.2 AND NIIO2.1.
- IO. TERMITE TREATMENT BORATE APPLIED TO ALL FRAME MEMBERS WITHIN 24" AFF.

### INDEX TO DRAWINGS

COVER SHEET

FRONT AND LEFT SIDE ELEVATIONS

REAR AND RIGHT SIDE ELEVATIONS

FIRST FLOOR PLAN
SECOND FLOOR PLAN

5 FIRST FLOOR ELECTRICAL PLAN
6 SECOND FLOOR ELECTRICAL PLAN
OPT1 FLOOR PLAN OPTIONS

opt2 REAR PORCH OPTIONS
D1 CONSTRUCTION DETAILS
CONSTRUCTION DETAILS
CONSTRUCTION DETAILS

CRAWL SPACE FOUNDATION PLAN
FIRST FLOOR CEILING FRAMING PLAN
SECOND FLOOR CEILING FRAMING PLAN
ROOF FRAMING PLAN

\$D1 STRUCTURAL DETAILS
\$D2 STRUCTURAL DETAILS
\$PEC STRUCTURAL SPECIFICATIONS
\$8 PLAN OPTIONS FRAMING

#### RESIDENTIAL BUILDING CODE SUMMARY

- PLANS ARE DESIGNED TO THE 2018 NORTH CAROLINA RESIDENTIAL BUILDING CODE.
- 2. HOUSE IS DESIGNED FOR 120 MPH, 3 SECOND GUST (93 MPH FASTEST WIND), EXPOSURE B.
- 3. ANCHOR BOLTS SHALL BE MIN. 1/2" DIAMETER WITH STANDARD WASHER AND NUT AND SHALL EXTEND 1" MIN. INTO MASONRY OR CONCRETE. BOLTS TO BE NO MORE THAN 6' O.C. AND WITHIN 12" OF CORNERS. ALTERNATE ANCHOR STRAPS CAN BE USED INSTEAD OF ANCHOR BOLTS SPACED AT THE EQUIVALENT SPACING AND INSTALLED PER MANUFACTURER'S SPECIFICATION'S EXCEPT AT GARAGE LUG FTG.
- 4. MEAN ROOF HEIGHT: 24'-4"
- 5. COMPONENT & CLADDING DESIGNED FOR THE FOLLOWING LOADS:

  MEAN ROOF HGT: UP TO 30' 30'-1"TO 35' 35'-1"TO 40' 40'-1"TO 45'

	<del></del>	<del>50   10 55</del>	<del>55   10   10  </del>	<del>70   10   7</del>
ZONE I	16.5, -18.0	17.3, -18.9	18.0, -19.6	18.5, -20.2
ZONE 2	16.5, -21.0	17.3, -22.1	18.0, -22.9	18.5, -23.5
ZONE 3	16.5, -21.0	17.3, -22.1	18.0, -22.9	18.5, -23.5
ZONE 4	18.0, <b>-</b> 19.5	18.9, <b>-</b> 20.5	19.6, <b>-</b> 21.3	20.2, <b>-</b> 21.8
ZONE 5	18.0, <b>-</b> 24.1	18.9, -25.3	19.6, -26.3	20.2, -27.0

- 6. MINIMUM VALUES FOR ENERGY COMPLIANCE: ZONE 4
- 7. MAXIMUM GLAZING U-FACTOR: <u>0.35</u>
- 8. INSULATING VALUES: CEILING: R-30\* / WALLS: R-15 / FLOOR: R-19 , SLABS: R-10. CODE REFERENCE: TABLE NI102.1 (\*R-30 ONLY IF UNCOMPRESSED, R-38 REQUIRED IF COMPRESSED)
- 9. FLASHING SHALL BE INSTALLED IN ACCORDANCE WITH SECTION R703.8 OF THE N.C.R.B.C.
- IO. FIREBLOCKING SHALL BE INSTALLED IN ACCORDANCE WITH SECTION R602.8 OF THE N.C.R.B.C.
- II. DRAFTSTOPPING SHALL BE INSTALLED IN ACCORDANCE WITH SECTION R302.12 OF THE N.C.R.B.C.

#### **AREA CALCULATIONS**

IST FLOOR:	931	GARAGE:	521
2ND FLOOR:	1200	FRONT PORCH:	99
TOTAL:	2 3	PATIO:	140
		TOTAL	760

COV. PORCH OPT: 224

MIDTH: 39'-0" DEPTH: 53'-0"

#### TOILET ACCESSORIES LEGEND

MATERIALS LEGEND

ROUGH WOOD

BLOCKING

PLYWOOD

BATT INSULATION

RIGID INSULATION

PROVIDE 2x4 BLOCKING IN THE WALL FOR THE FOLLOWING:

TB TOWEL BAR
TO TOU ET PAPER

CONCRETE BLOCK/STONE

CONCRETE

BRICK

TP TOILET PAPER HOLDER
TR TOWEL RING

MC MEDICINE CABINET

AR MAGAZINE RACK

# THE PURPOSE OF THESE DRAWINGS IS TO SHOW THE INTENT OF THE DESIGN AND CONSTRUCTION OF THIS HOME. ANY ERRORS AND/OR OMISSIONS FOUND IN THIS SET SHOULD IMMEDIATELY BE REPORTED TO $\underline{ADAMS}$ HOMES FOR CLARIFICATION OR CORRECTION. THE CONTRACTOR SHOULD VERIFY ALL CONDITIONS AND DIMENSIONS $\underline{PRIOR}$ TO CONSTRUCTION.

# FOUNDATION VENTING CALCULATIONS

(REFERENCE: N.C.S.R.B.C., 2018 EDITION, SECTION R408)


THE MINIMUM NET AREA OF VENTILATION OPENINGS SHALL BE NOT LESS THAN ONE
(1) SQUARE FOOT FOR EACH 150 SQUARE FEET OF CRAWL SPACE GROUND AREA AND ONE
FOUNDATION VENT SHALL BE WITHIN THREE (3) FEET OF EACH CORNER OF THE BUILDING.

EXCEPTION: THE TOTAL AREA OF VENTILATION OPENINGS MAY BE REDUCED TO 1/1500 OF THE UNDERFLOOR AREA WHERE THE GROUND SURFACE IS TREATED WITH AN APPROVED VAPOR RETARDER
MATERIAL AND THE REQUIRED OPENINGS ARE PLACED SO AS TO PROVIDE CROSS-VENTILATION.

931 SQUARE FEET OF CRAWL SPACE AREA / 150 = 6.21 SQUARE FEET OF NET FREE AREA REQUIRED

### ATTIC VENTILATION REQUIREMENTS

NATURAL ROOF VENTILATION	MECHANICAL ROOF VENTILATOR
1467 SQ. FT.	1467 50. FT.
150 - 4. 10 50. FT. VENT REQUI	300 24.09 5Q. FT. VENT REQ D
BUILDER TO PROVIDE APPROPRIATE	VENTILATING AS REQUIRED PER CODE

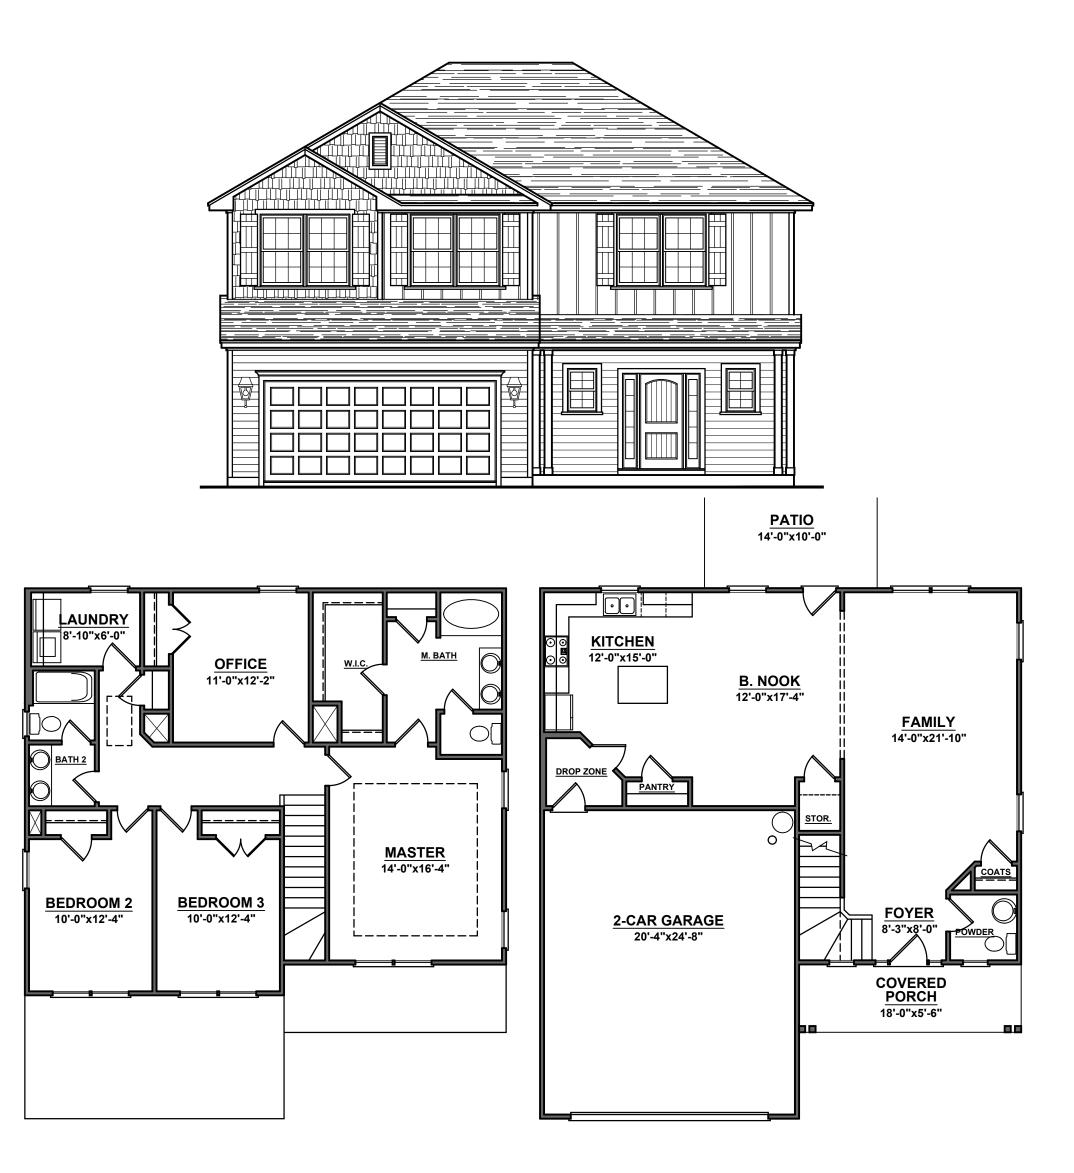




5474




2/24/2022

ROJECT	
5474	
REVISIONS	

SHEET

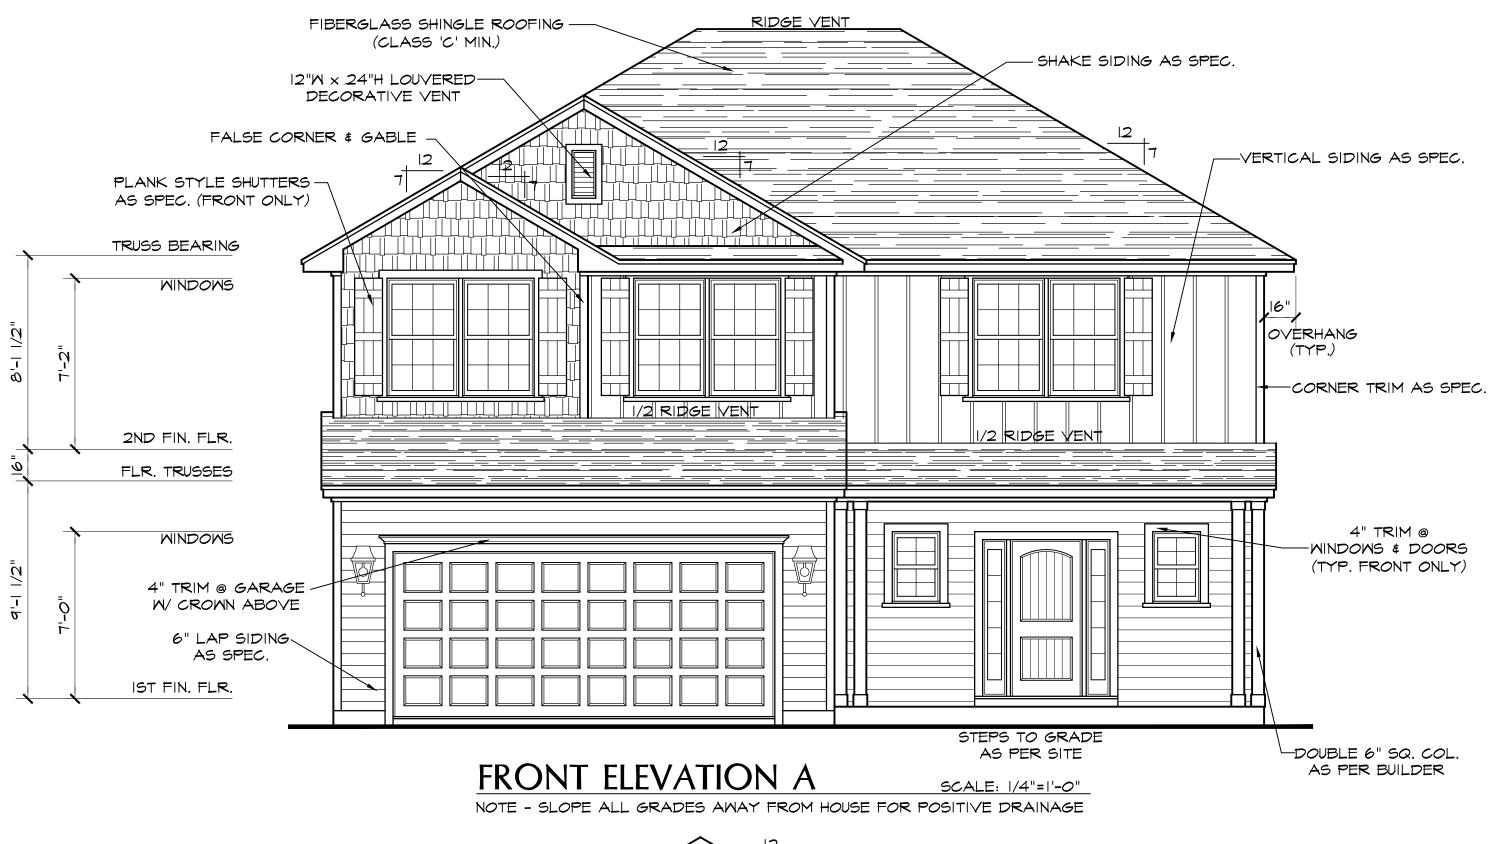

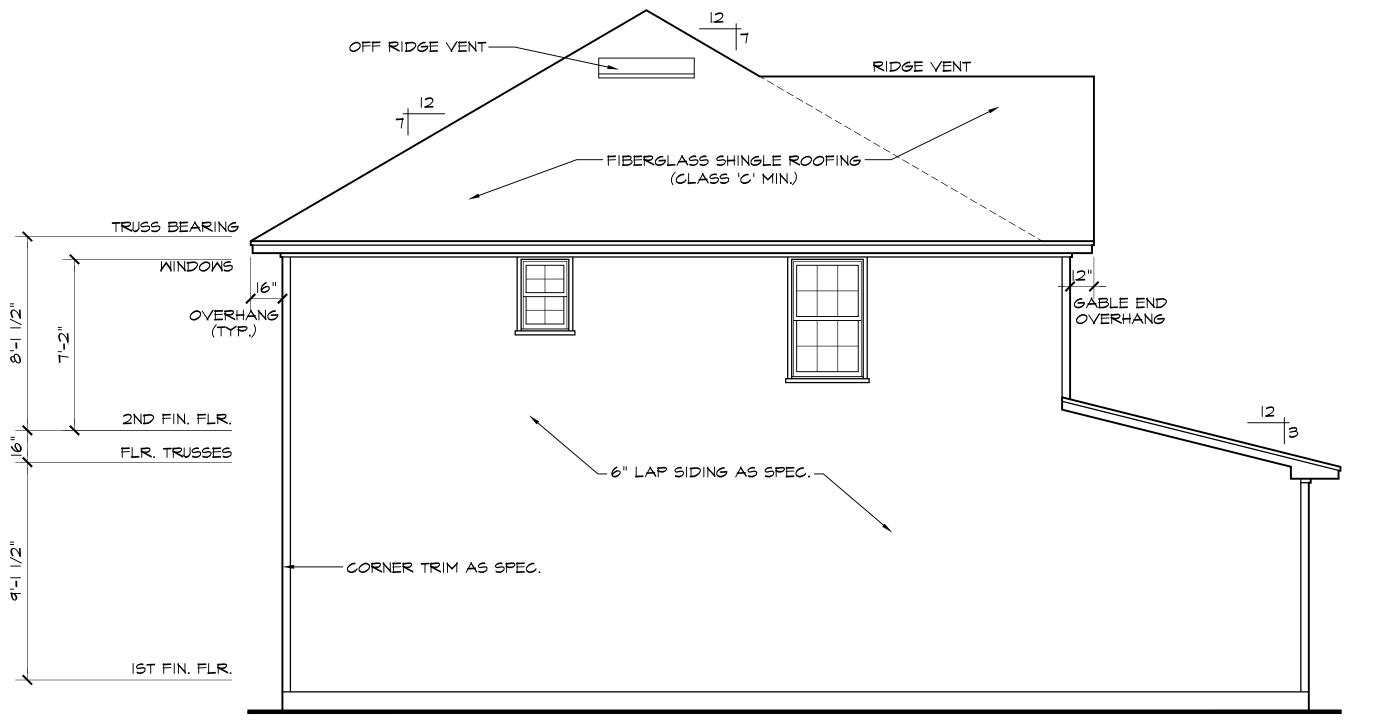

LEFT SIDE ELEVATION

SCALE: 1/4"=1'-0"










CS007 出

DATE DRAWN
2/24/2022
PROJECT
5474
REVISIONS
SHEET

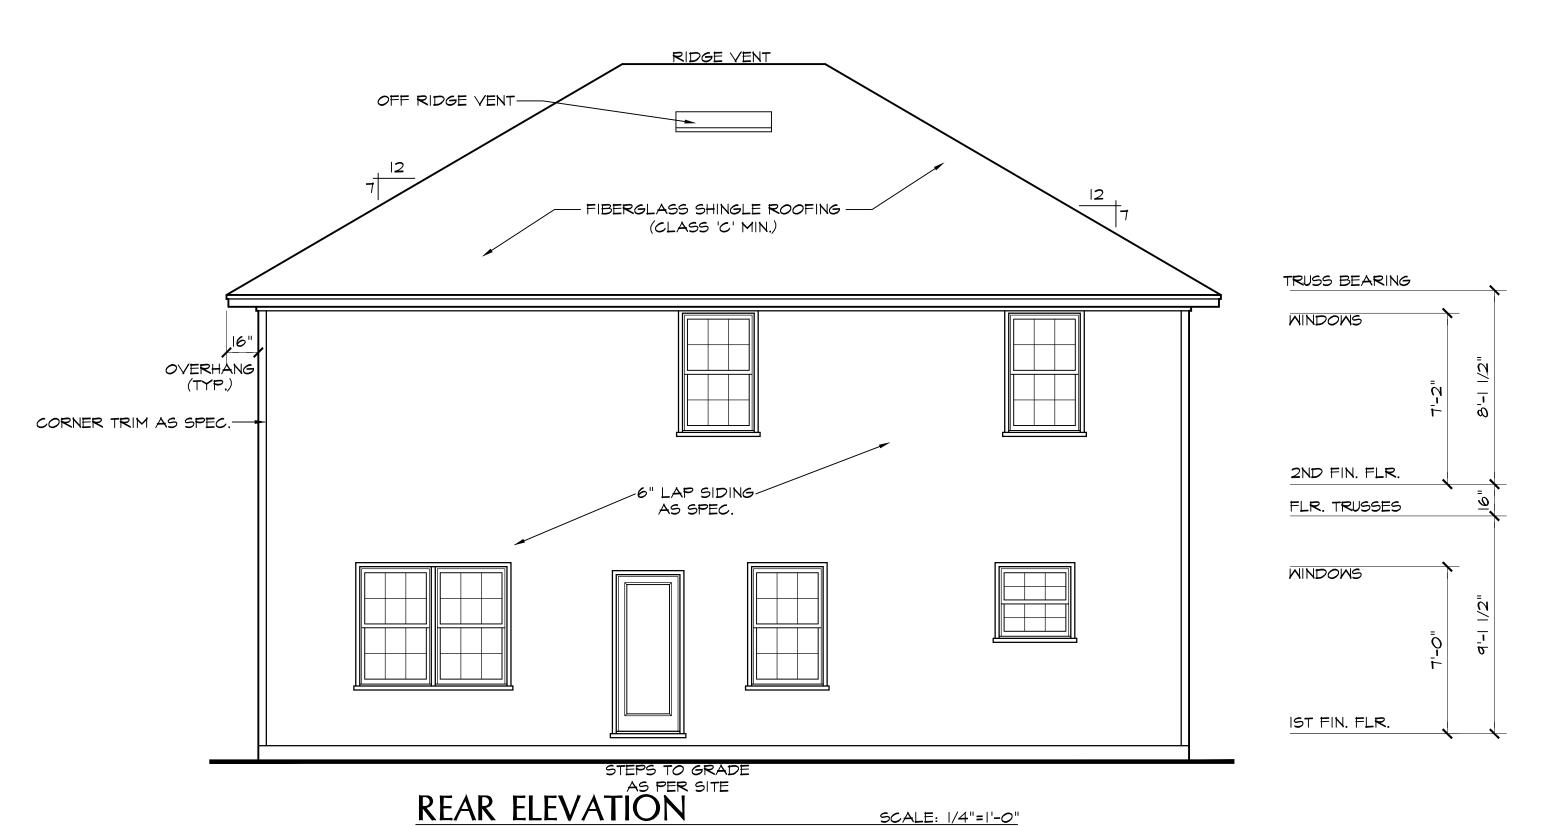

SCALE: 1/4"=1'-0" NOTE - SLOPE ALL GRADES AWAY FROM HOUSE FOR POSITIVE DRAINAGE

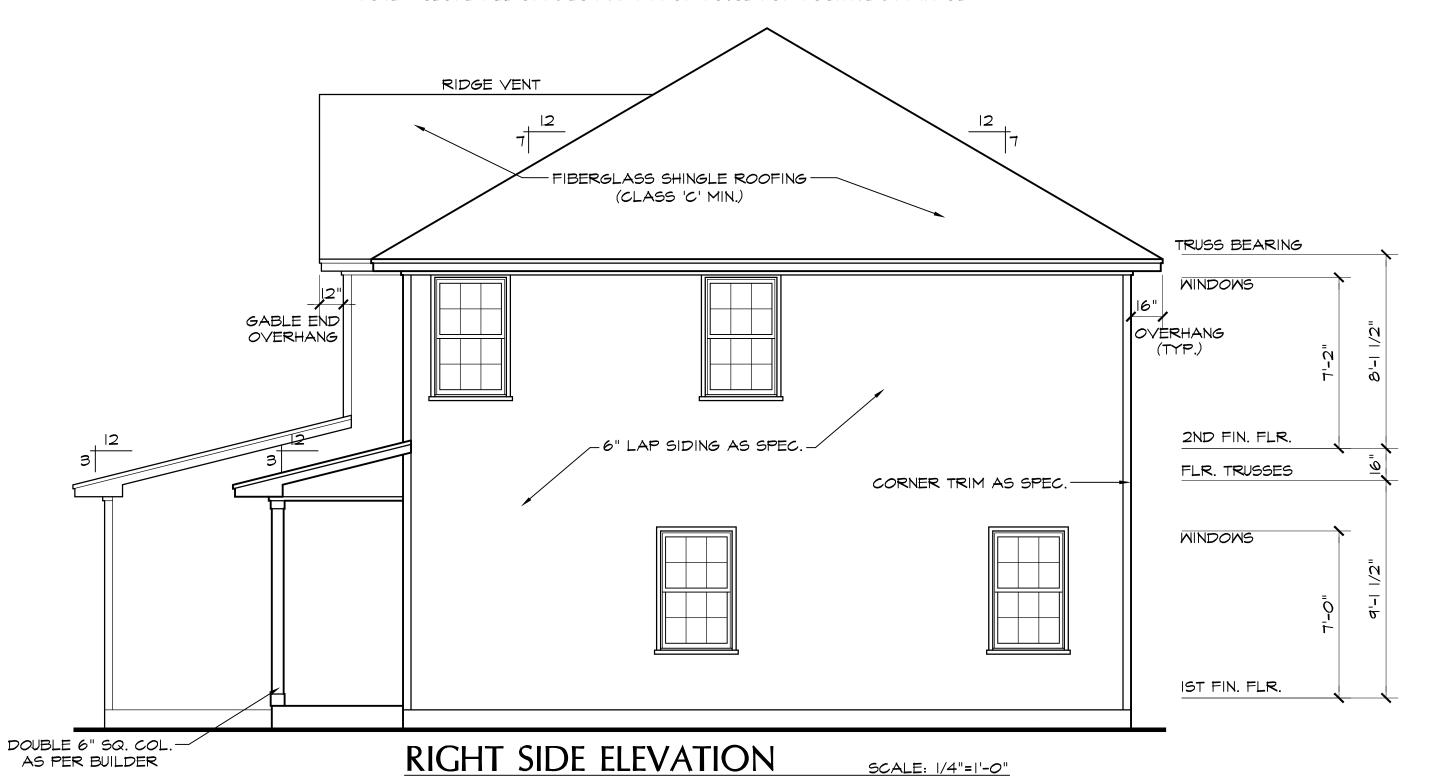


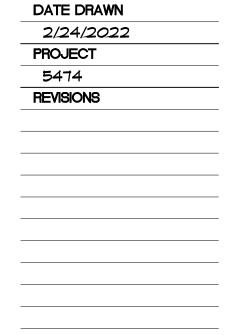



SHEET

FIRST FLOOR PLAN

 9'-0" (NOM.) CLG. HGT. U.N.O. SCALE: 1/4"=1'-0" SET WINDOWS @ 7'-0" U.N.O.

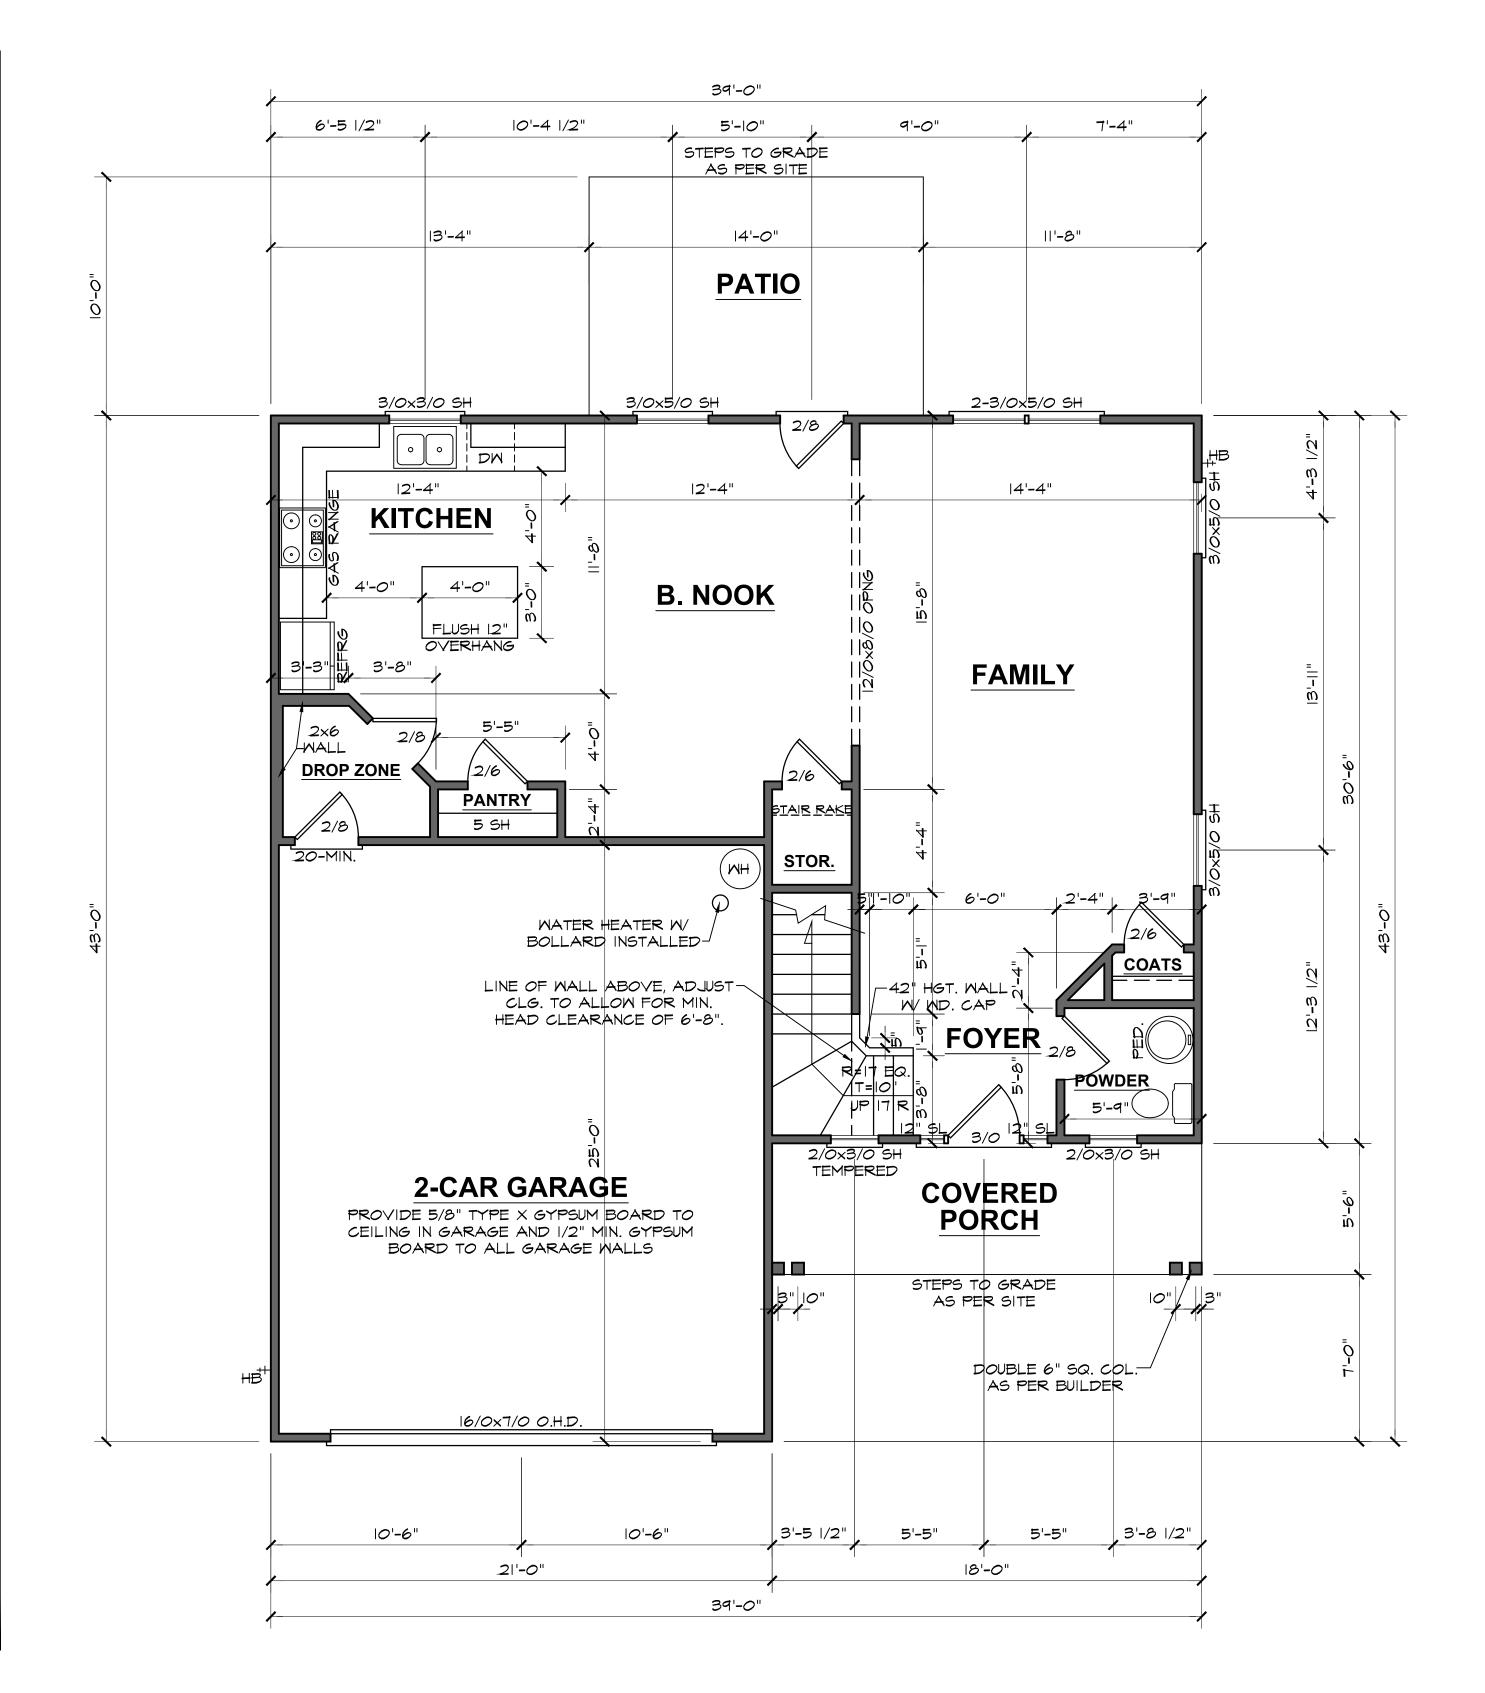




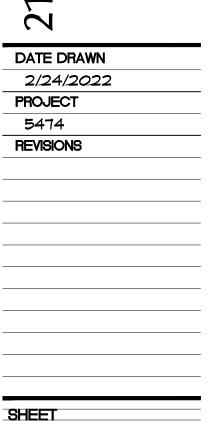

# SECOND FLOOR PLAN

8'-0" (NOM.) CLG. HGT. U.N.O. SCALE: 1/4"=1'-0" SET WINDOWS @ 7'-2" U.N.O.

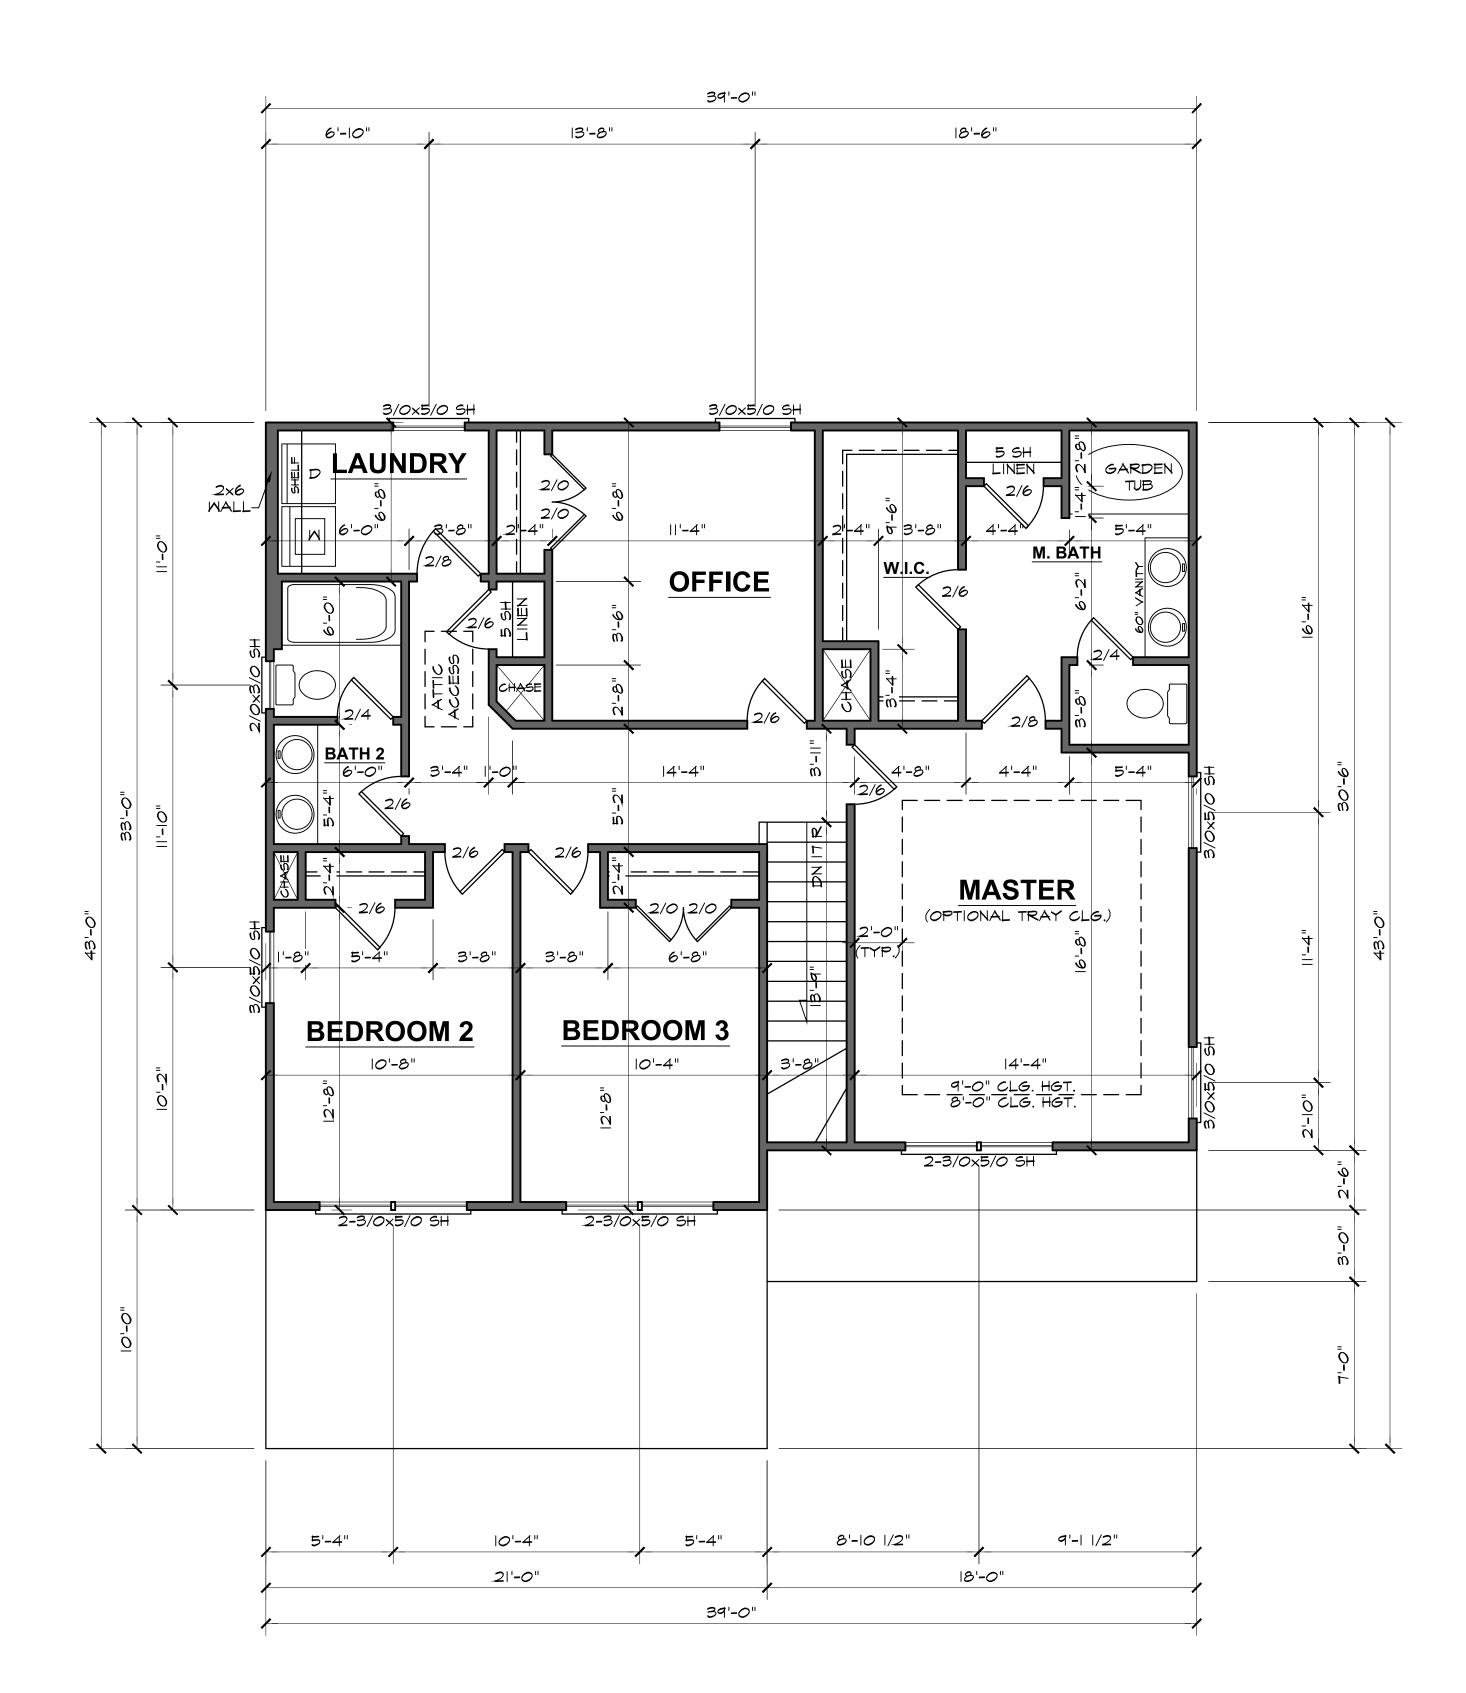


5474

**PROJECT** 

REVISIONS

SHEET 5

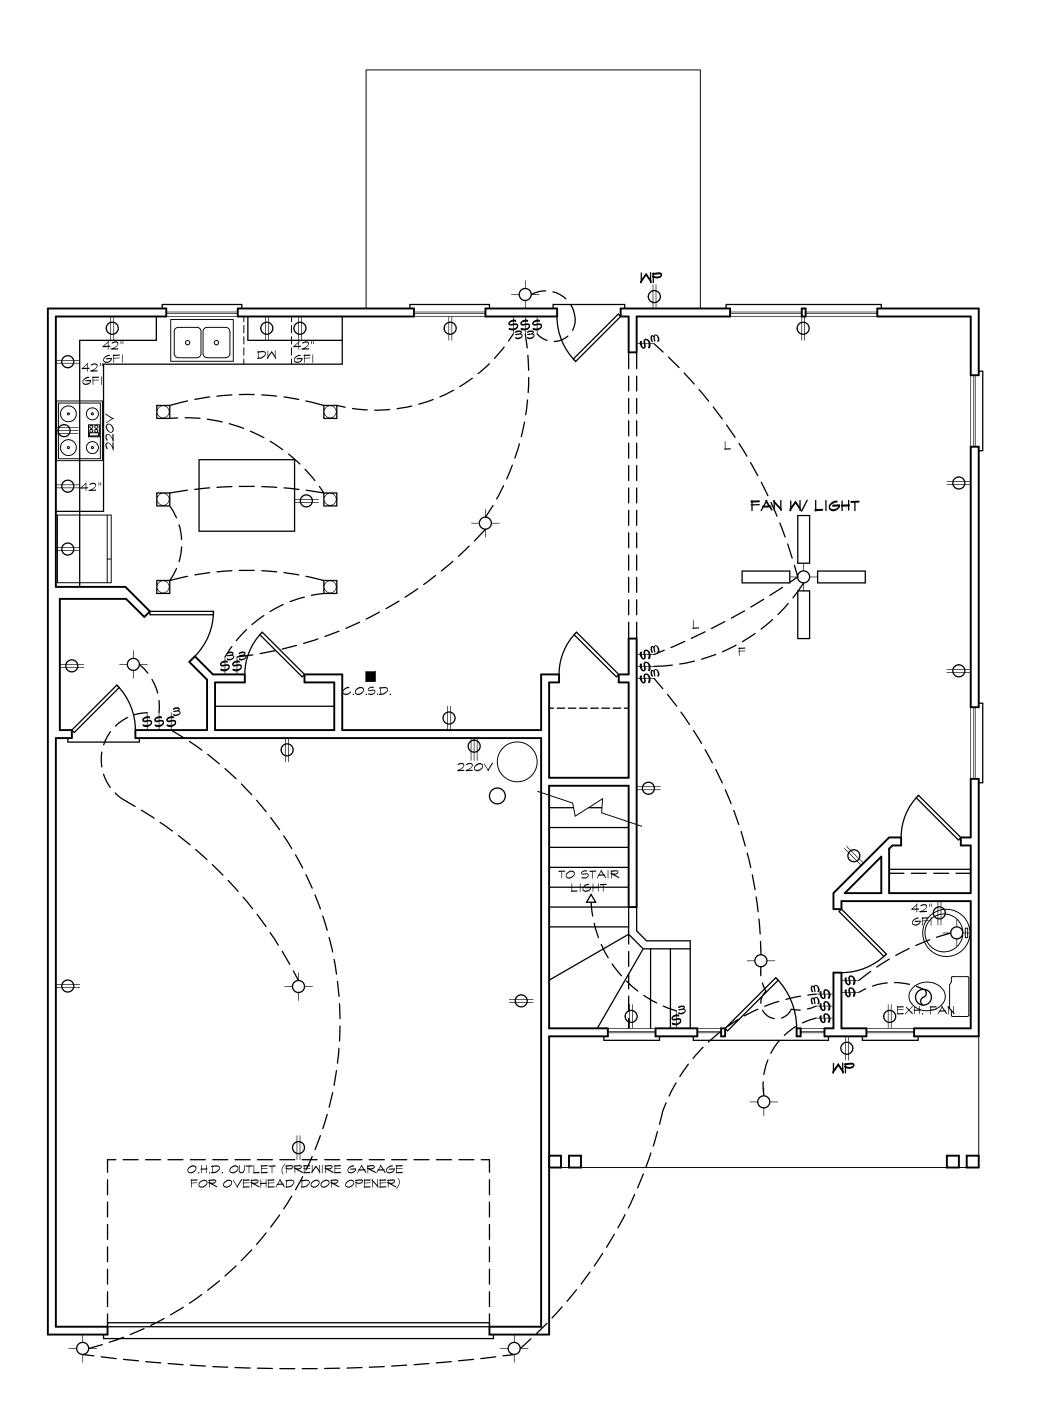


## ELECTRICAL LEGEND S - FAN/LIGHT WP WATERPROOF OUTLET - RECESSED LIGHTING \$ - SINGLE PULL SMITCH \$ - 3-WAY SWITCH \$ - 4-WAY SWITCH \$ - DIMMER SWITCH ■ - SMOKE DETECTOR 1 - FLOOD LIGHTS 7 - EYEBALL SPOTS → DUPLEX RECEPTACLE (IIOV) - 220 VOLT RECEPTACLE SWITCHED RECEPTACLE (TOP WIRE ONLY) - GROUND FAULT CIRCUIT INTERRUPTOR - CLG FAN/LIGHTS TRACK LIGHTS - FLUORESCENT LIGHTING ○ - CABLE OUTLET ▲ - TELEPHONE OUTLET △ - COMPUTER DATA OUTLET 🛛 - BURGLAR ALARM - INTERCOM NOTE: ALL ELECTRICAL TO BE VERIFIED BY OWNER/BUILDER BEFORE ROUGH-IN.

# FIRST FLOOR ELECTRICAL PLAN

NOTE - ELECTRICAL RECEPTACLE AND SWITCH QUANTITIES AND LOCATIONS SHOWN ON PLAN ARE FOR ILLUSTRATION PURPOSES ONLY. ACTUAL NUMBER AND LOCATIONS SHALL BE FIELD DETERMINED AS PER CLIENT AND BUILDER EXCEPT WHERE CODE REQUIREMENTS APPLY.

**REVISIONS** 

SHEET

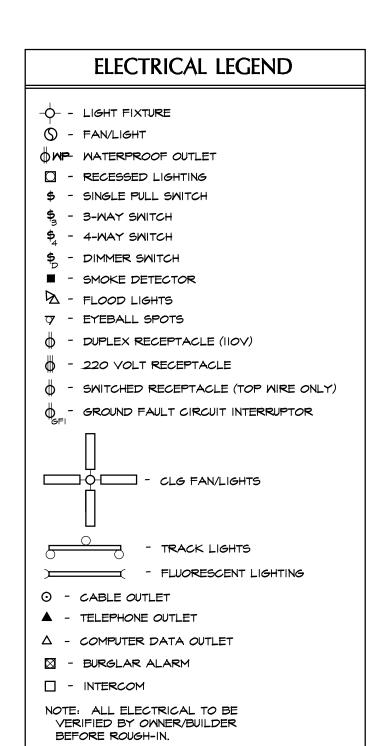

FAN W/ LIGHT OPTIONAL FAN W/ LIGHT OPTIONAL FAN W/ LIGHT

OPTIONAL FAN W/ LIGHT

C.O.S.D.

EXH. FAN

# SECOND FLOOR ELECTRICAL PLAN

NOTE - ELECTRICAL RECEPTACLE AND SWITCH QUANTITIES AND LOCATIONS SHOWN ON PLAN ARE FOR ILLUSTRATION PURPOSES ONLY. ACTUAL NUMBER AND LOCATIONS SHALL BE FIELD DETERMINED AS PER CLIENT AND BUILDER EXCEPT WHERE CODE REQUIREMENTS APPLY.

DATE DRAWN 2/24/2022 PROJECT 5474 REVISIONS

SHEET

**OPTIONAL FIREPLACE BUMP OUT** 

**SIDE VIEW** 

TRUSS BRG.

IST FIN. FLR.

1/2 RIDGE VENT


**REAR VIEW** 

4' X 3' (1) PC. FIBERGLASS SHOWER IN LIEU OF LINEN CLOSET 4' X 4' FIXED OBSCURED GLASS WINDOW OBSCURED GLASS 4/0x4/0 FXD **OPTIONAL MASTER BATH** 


**FAMILY** 


**PLAN VIEW** 

OPTIONAL MASTER BATH

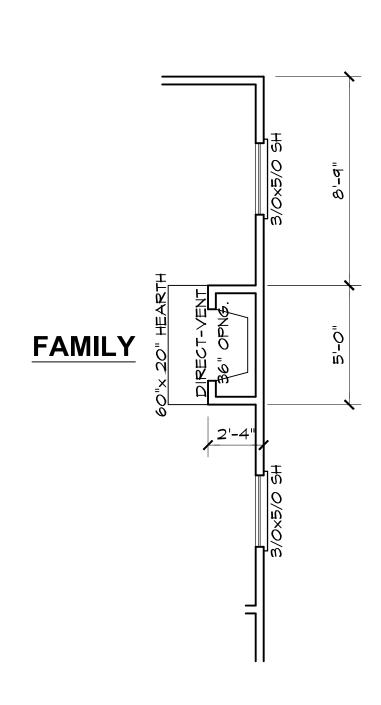


**OPTIONAL FIREPLACE** 

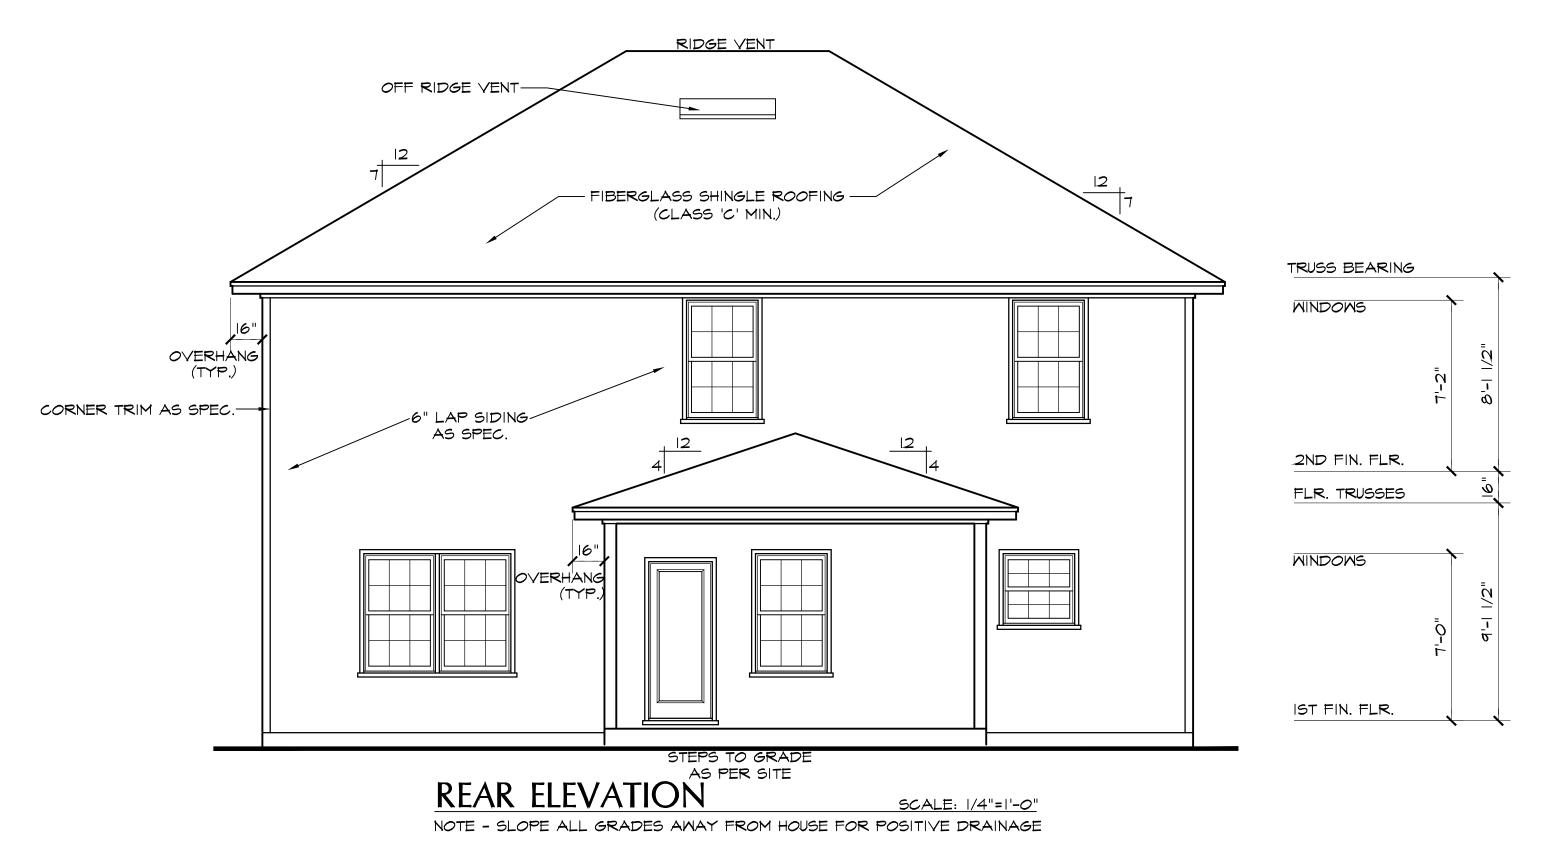

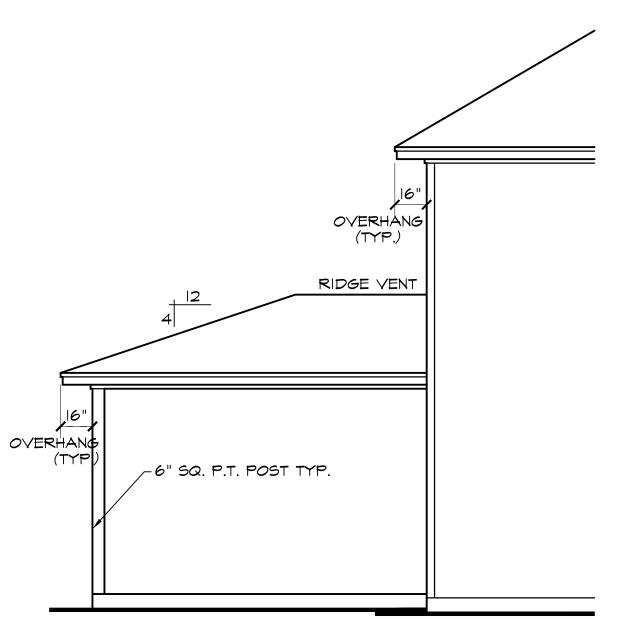




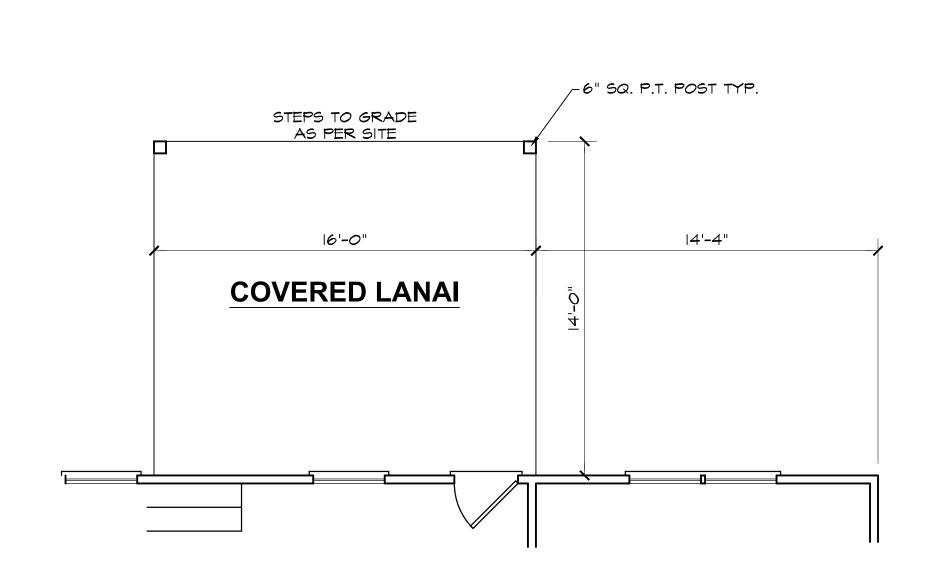

COVERED PORCH SCALE: 1/4"=1'-0"

(L) CS007

✓ SHEET	2131 "A"
	DATE DRAWN
( )	2/24/2022
	PROJECT
<b>—</b>	5474 REVISIONS
( )	
<u> </u>	
	SHEET
~	
	Ont
_	

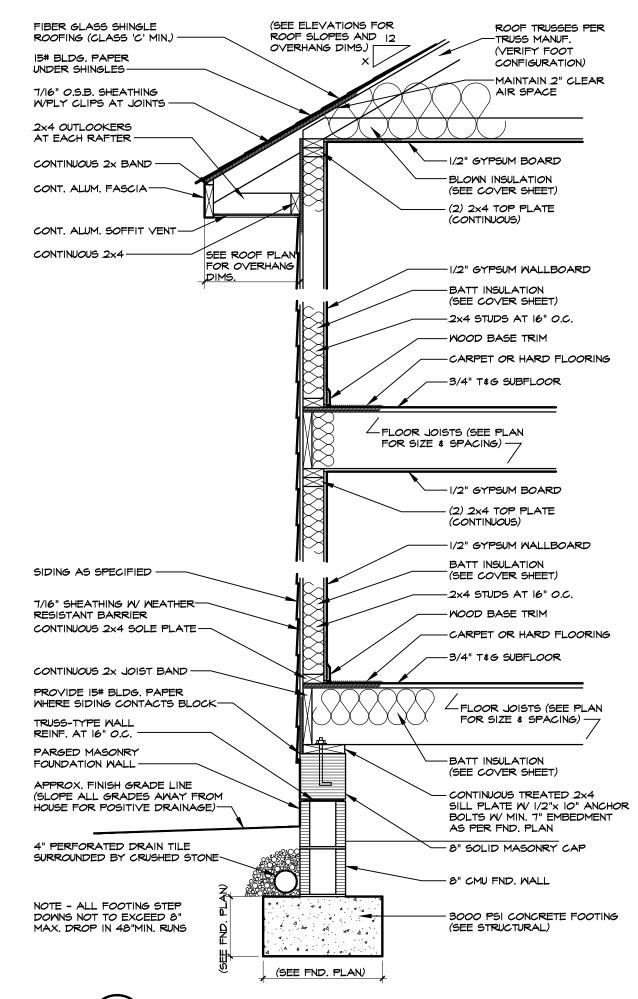

MN.O. ΣXX # 60 | 40 | 60 10" U.N.O.[ \* 7 3/4" FOR S.C. 8 1/4" FOR N.C. STAIR PICKETS SHALL BE SPACED SUCH THAT A 4" DIA. SPHERE MAY NOT BE ABLE TO PASS THRU BETWEEN

> TYPICAL STAIR DETAIL SCALE: 3/4"=1'-0"


回

S

DATE DRAW	1

REVISIONS

SHEET

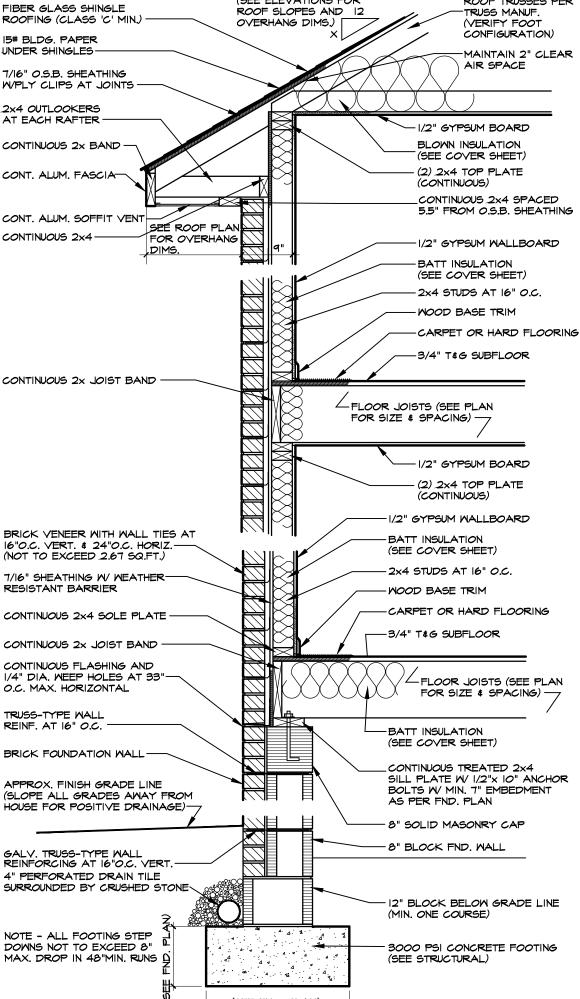

SCALE: 3/4"=1'-0"

Ш S  $\checkmark$ 4


(W/ 12" FOUNDATION WALL)

DATE DRAWN REVISIONS



Ш S  $\checkmark$ 4

DATE DRAWN **REVISIONS** 

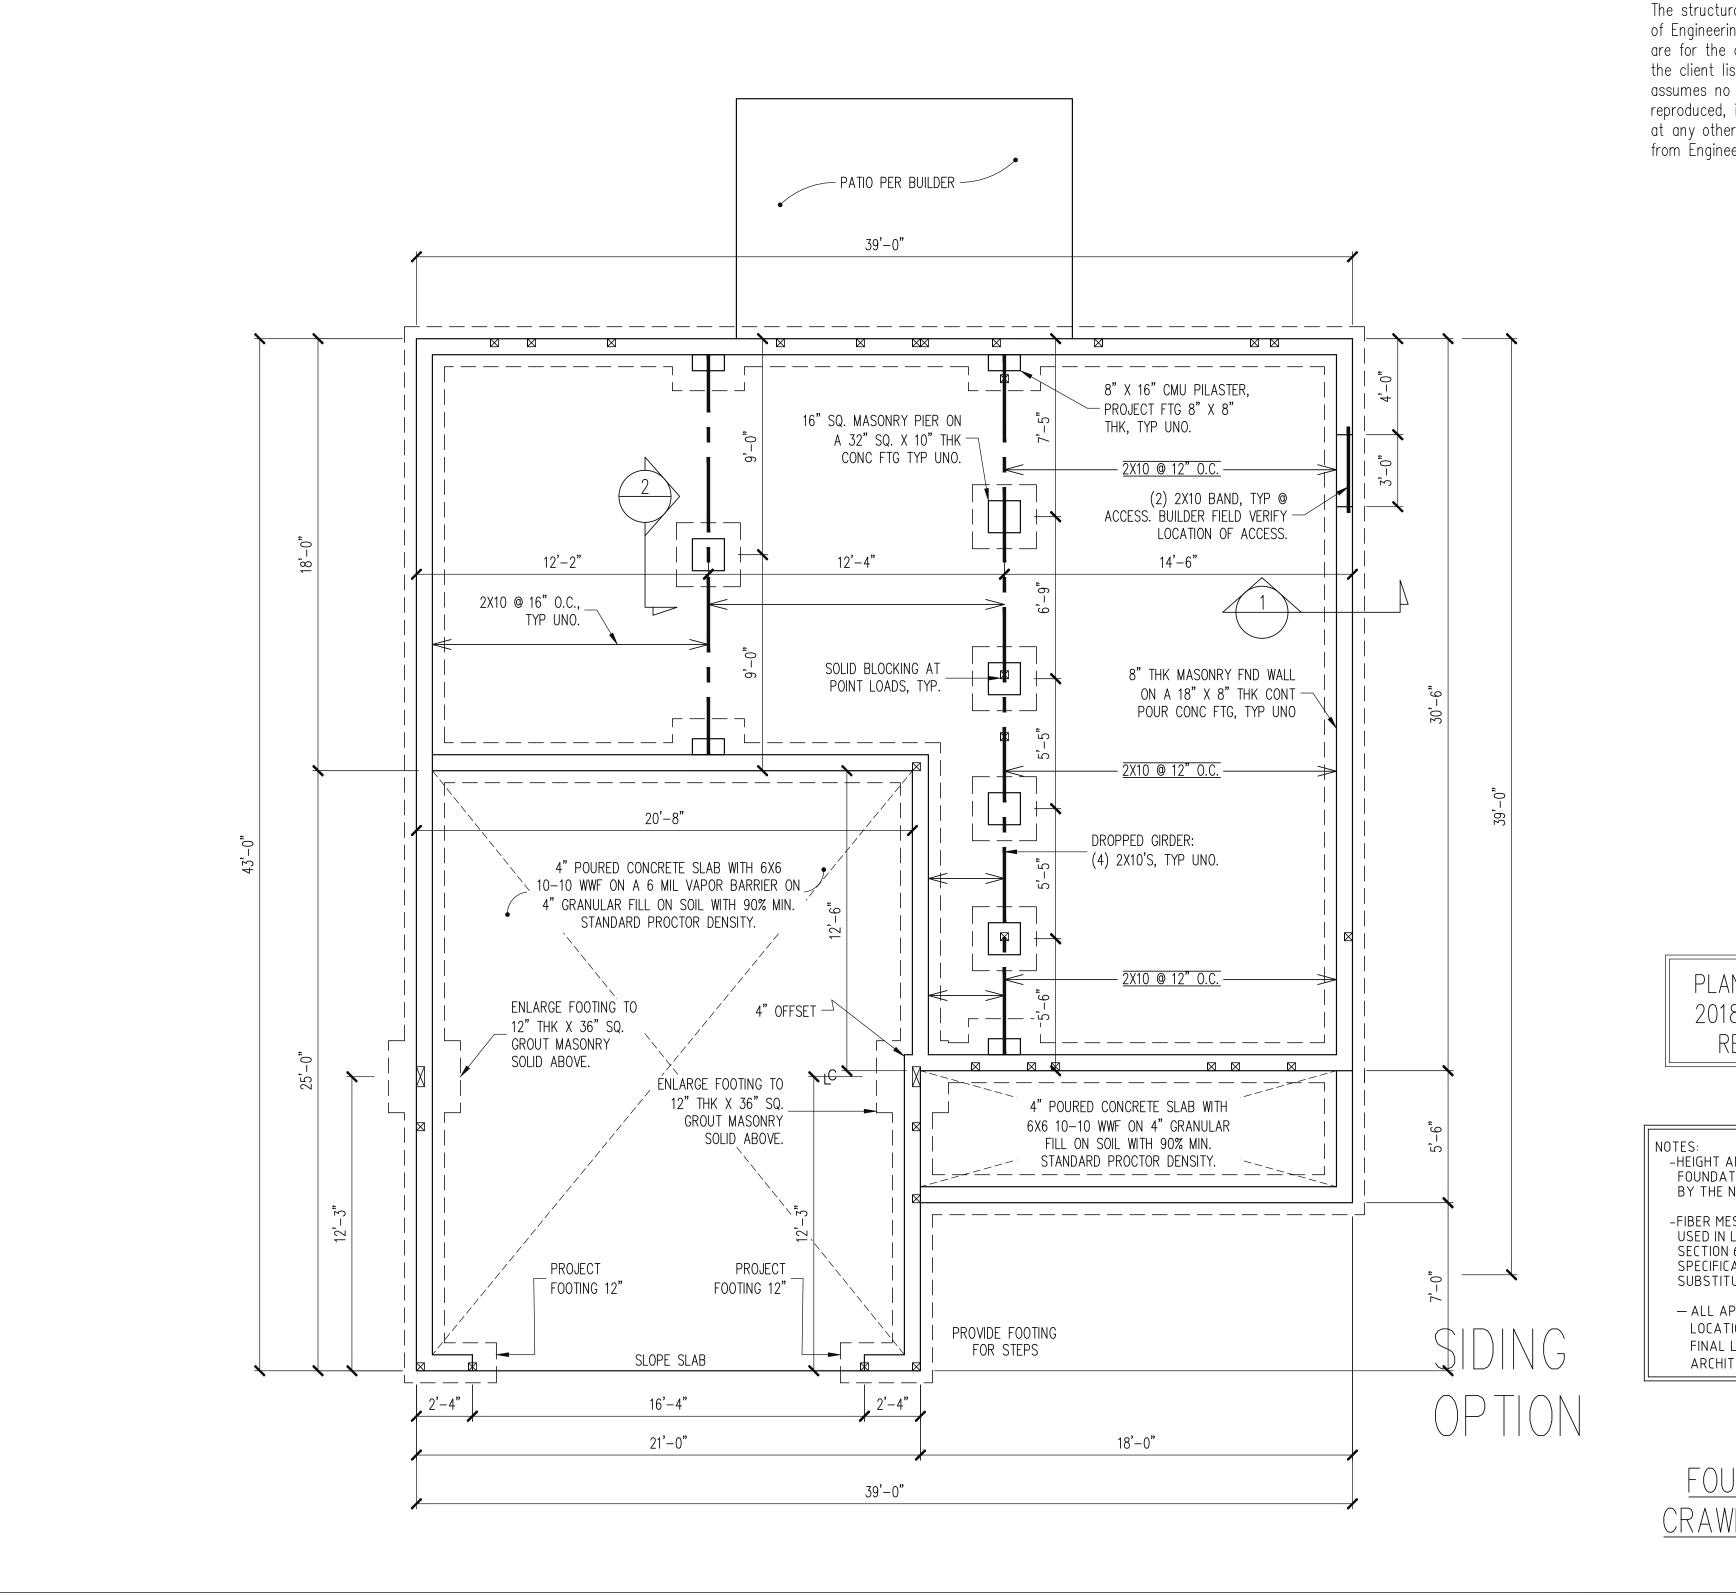

The structural design of this plan is the property of Engineering Tech Associates, P.A. These plans are for the one time use at the location and for the client listed. Engineering Tech Associates, P.A. assumes no liability for these plans if they are reproduced, in whole or in part, for construction at any other location without written permission from Engineering Tech Associates, P.A.

PLAN DESIGNED UNDER 2018 NORTH CAROLINA RESIDENTIAL CODE

-HEIGHT AND BACKFILL LIMITATIONS FOR FOUNDATION WALLS ARE TO BE GOVERNED BY THE NCSBC, LATEST EDITION.

-FIBER MESH REINFORCED CONCRETE MAY BE USED IN LIEU OF WELDED WIRE FABRIC. SEE SECTION 6.01 OF THE CONSTRUCTION SPECIFICATIONS FOR ALLOWABLE SUBSTITUTION DETAILS.


 ALL APPLIANCE AND PLUMBING LOCATIONS ARE FOR REFERENCE ONLY.
 FINAL LOCATIONS MUST BE VERIFIED WITH ARCHITECTURAL FLOOR PLANS.

FOUNDATION PLAN CRAWL SPACE OPTION

1/4" = 1'-0"

STRUCTURAL ENGINEERS
License No. C-3870
318 W Millbrook Road, Unit 201
Raleigh, North Carolina 27609
Phone: (919) 844-1661



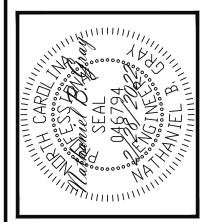


		ENG CAR/NBG		DATE 2/28/2022
	MUC	ENG	REV:	DATE
ADAMS HOMES	SCOPE STRUCTURAL ADDENDUM	LOT #: 7 CAROLINA SEASON		2131 MASTER

PLAN NO. 2131

PROJECT NO. 22-18-073

SHEET NO.

**S**1

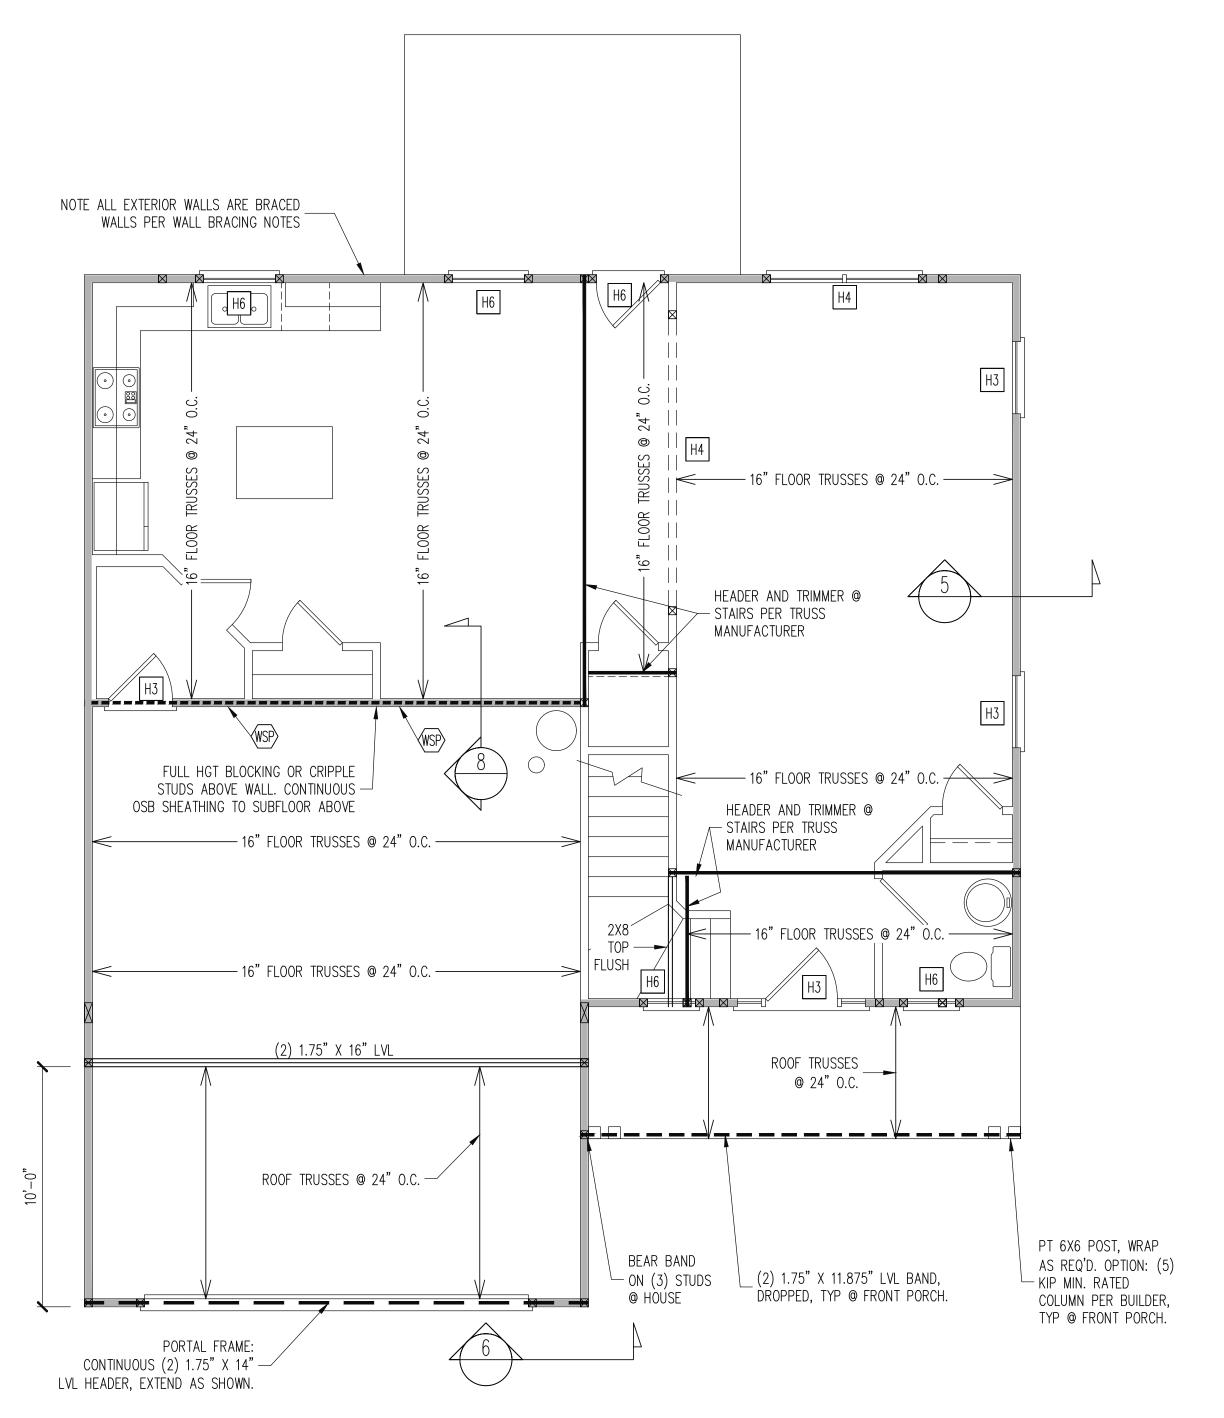

## REQUIRED STUDS FOR BEAM SUPPORT

REFER TO SECTIONS 5.02 - 5.06 OF THE CONSTRUCTION SPECIFICATIONS FOR REQUIRED NUMBER OF STUDS FOR BEAM SUPPORT, TYP UNO.

### HEADER SCHEDULE

- H1 SINGLE 2X4 TURNED FLAT (A)
- H2 (2) 2X4'S ON SINGLE JACKS (B)
- H3 (2) 2X10'S ON SINGLE JACKS (C)
- H4 (2) 1.75" X 9.25" LVL'S ON DBL JACKS
- H6 (2) 2X10'S ON DBL 2X4 JACKS
- (A) TYPICAL FOR INTERIOR NON LOAD BEARING WALLS ONLY, ROUGH OPENING 38" MAX.
- (B) TYPICAL FOR INTERIOR NON LOAD BEARING WALLS ONLY, ROUGH OPNG 38" TO 74" MAX.
- (C) TYPICAL FOR ALL CONDITIONS NOT LISTED IN (A) OR (B) UNO.

-HEADERS IN NON LOAD BEARING INTERIOR WALLS ARE NOT LABELED. -KING STUDS EXTERIOR WALLS: SINGLE KING STUDS FOR 6' MAX OPENINGS. DBL KING STUDS FOR 10' MAX OPENINGS. TRPL KING STUDS FOR 14' MAX OPENINGS. QUAD KING STUDS FOR 18' MAX OPENINGS. FOR 2X6 WALLS, ONE HALF THE AMOUNT OF KING STUDS REQUIRED (ROUND UP) UNO

## WALL BRACING

ALL EXTERIOR STUD WALLS ARE TO BE CONTINUOUSLY SHEATHED WITH 7/16 APA RATED OSB NAILED TO STUDS WITH 8d NAILS @ 6" O.C. AT PANEL EDGES, 12" O.C. IN PANEL FIELD.

SINGLE JOIST, CONTINUOUS RIM JOIST, OR BLOCKING OF EQUAL DEPTH IS REQUIRED ABOVE AND BELOW ALL BRACED WALLS. NAIL BLOCKING ABOVE WALL TO TOP PLATE WITH 8d TOE NAILS @ 6" O.C. NAIL SOLE PLATE OF BRACED WALL TO BLOCKING BELOW WITH (3) 16d NAILS @ 16" O.C. BLOCKING AT HORIZONTAL JOINTS IN BRACED WALL LINES ONLY REQUIRED AT SHADED WALLS, UNO.

SHADED WALLS:


WSP - INTERIOR BRACED WALL WITH 3" MIN. THICKNESS WOOD STRUCTURAL PANELING, (1) SIDE. ATTACH WSP TO STUD WALL WITH 8d NAILS @ 6" O.C. AT PANEL EDGES, 12" O.C. IN PANEL FIELD. BLOCK AT ALL PANEL EDGES.


PROVIDED CONTINUOUS SHEATHING = 156' MIN. -WALL BRACING IS BY ENGINEERED DESIGN AND NOT PRESCRIPTIVE PER SECTION 602.10 OF THE 2018 NCRC. CONTINUOUS SHEATHING HAS BEEN PROVIDED, ALONG WITH ALTERNATIVE METHODS TO INSURE THE MINIMUM INTENT OF SECTION 602.10 OF THE 2018 NCRC HAS BEEN MET AND EXCEEDED. -BRACED WALL PANELS SHALL BE FASTENED IN ACCORDANCE WITH TABLE 602.3(1) TO PROVIDE CONTINUOUS PANEL UPLIFT RESISTANCE AND COMPLIANCE WITH NCRBC R602.3.5 AND R802.11 UNLESS NOTED OTHERWISE ON STRUCTURAL PLANS.

SIDING OPTION 1ST FLOOR FRAMING PLAN WALLS AND CEILING

1/4" = 1'-0"

STRUCTURAL ENGINEERS
License No. C-3870
318 W Millbrook Road, Unit 201
Raleigh, North Carolina 27609
Phone: (919) 844-1661

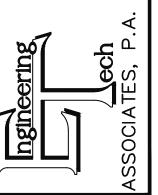

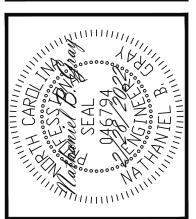


	CAR/NBG		DATE: 2/28/2022
MUC	ENG	REV:	DATE
SCOPE: STRUCTURAL ADDEND	LOT #: 7 CAROLINA SEASON		2131 MASTER
	SCOPE: STRUCTURAL ADDENDUM	7 CAR	STRUCTURAL ADDENDUA 7 CAROLINA SEASON

PLAN NO. 2131

PROJECT NO. 22-18-073

SHEET NO. **S2** 

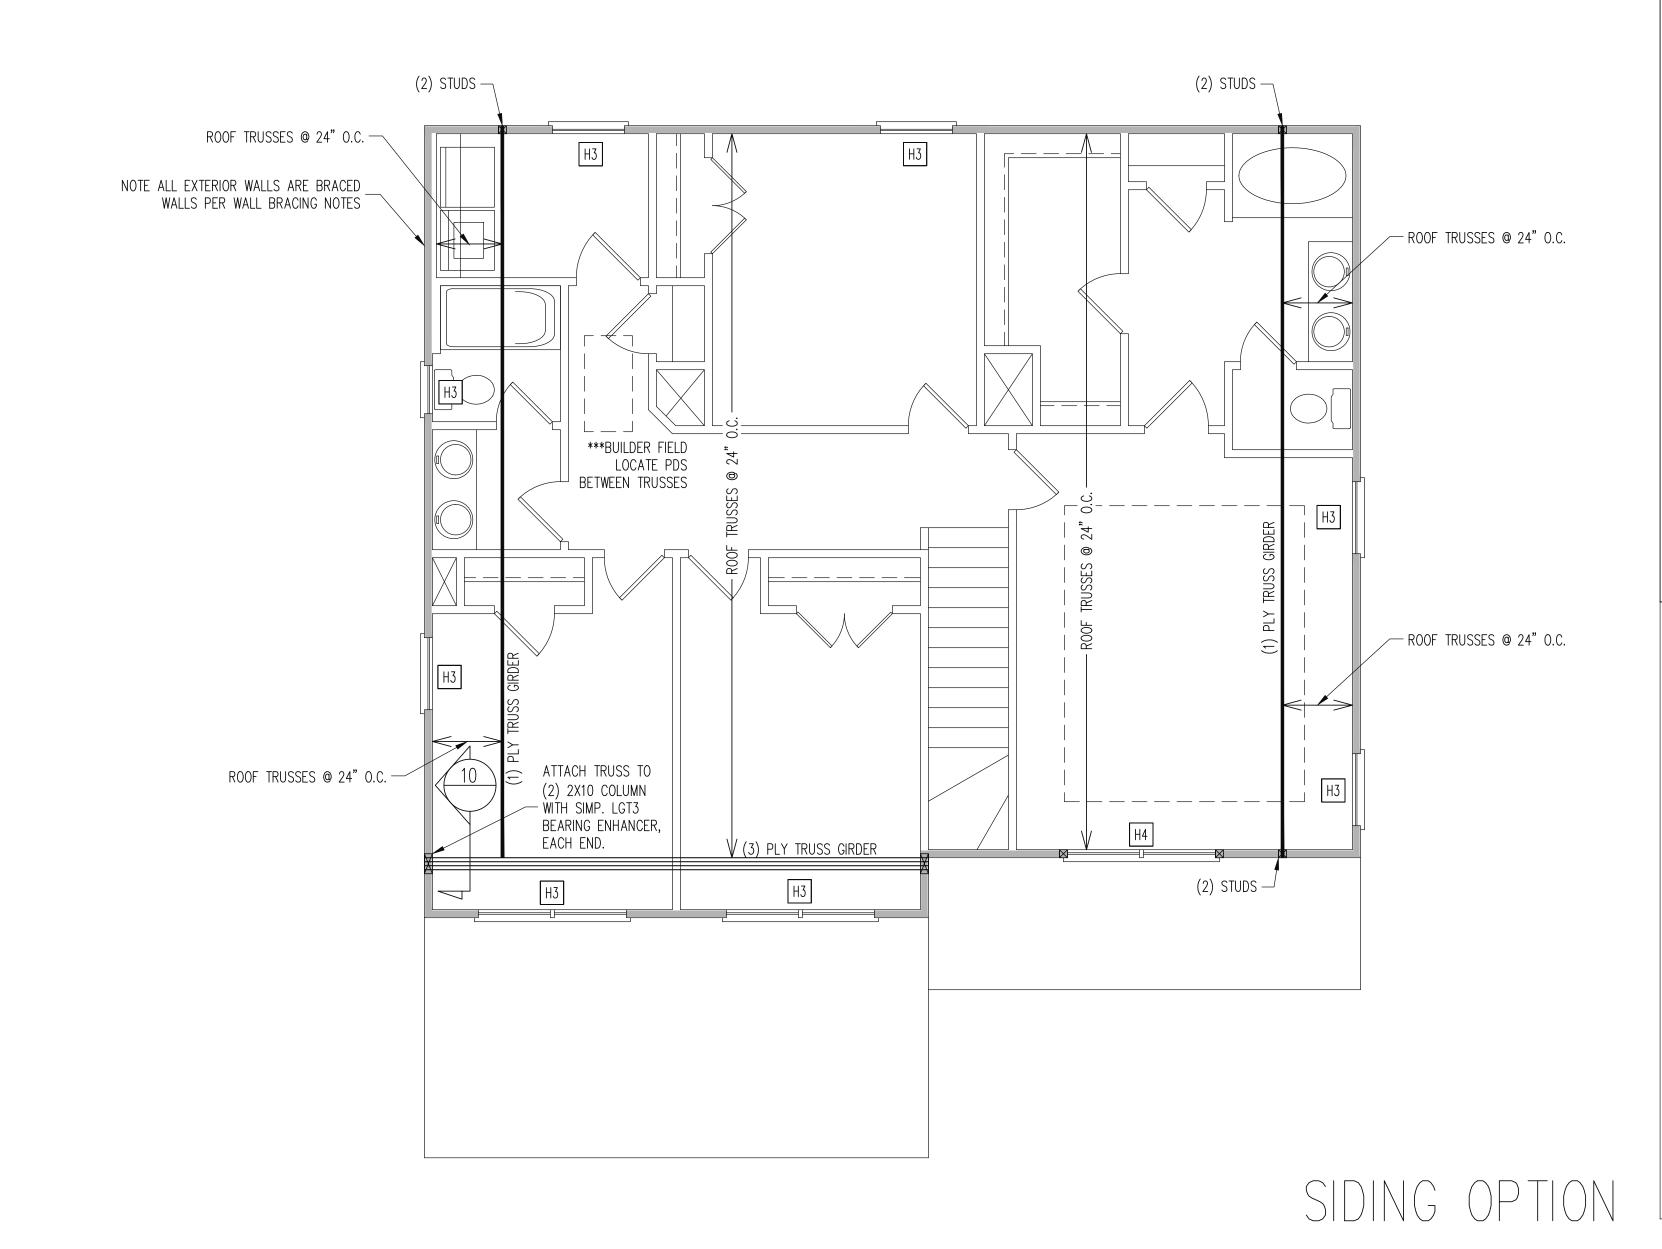

# REQUIRED STUDS FOR BEAM SUPPORT

REFER TO SECTIONS 5.02 - 5.06 OF THE CONSTRUCTION SPECIFICATIONS FOR REQUIRED NUMBER OF STUDS FOR BEAM SUPPORT, TYP UNO.

## HEADER SCHEDULE

- H1 SINGLE 2X4 TURNED FLAT (A)
- H2 (2) 2X4'S ON SINGLE JACKS (B)
- H3 (2) 2X10'S ON SINGLE JACKS (C)
- H4 (2) 1.75" X 9.25" LVL'S ON DBL JACKS
- H5 (3) 2X10'S ON SINGLE 2X6 JACKS
- (A) TYPICAL FOR INTERIOR NON LOAD BEARING WALLS ONLY, ROUGH OPENING 38" MAX.
- (B) TYPICAL FOR INTERIOR NON LOAD BEARING WALLS ONLY, ROUGH OPNG 38" TO 74" MAX.
- (C) TYPICAL FOR ALL CONDITIONS NOT LISTED IN (A) OR (B) UNO.

#### NOTES

- -HEADERS IN NON LOAD BEARING INTERIOR WALLS ARE NOT LABELED.
- -KING STUDS EXTERIOR WALLS:
  SINGLE KING STUDS FOR 6' MAX OPENINGS.
  DBL KING STUDS FOR 10' MAX OPENINGS.
  TRPL KING STUDS FOR 14' MAX OPENINGS.
  QUAD KING STUDS FOR 18' MAX OPENINGS.
  FOR 2X6 WALLS, ONE HALF THE AMOUNT OF KING STUDS REQUIRED (ROUND UP) UNO

## WALL BRACING

ALL EXTERIOR STUD WALLS ARE TO BE CONTINUOUSLY SHEATHED WITH 7/16 APA RATED OSB NAILED TO STUDS WITH 8d NAILS @ 6" O.C. AT PANEL EDGES, 12" O.C. IN PANEL FIELD.

SINGLE JOIST, CONTINUOUS RIM JOIST, OR BLOCKING OF EQUAL DEPTH IS REQUIRED ABOVE AND BELOW ALL BRACED WALLS. NAIL BLOCKING ABOVE WALL TO TOP PLATE WITH 8d TOE NAILS @ 6" O.C. NAIL SOLE PLATE OF BRACED WALL TO BLOCKING BELOW WITH (3) 16d NAILS @ 16" O.C. BLOCKING AT HORIZONTAL JOINTS IN BRACED WALL LINES ONLY REQUIRED AT SHADED WALLS, UNO.

SHADED WALLS:

PROVIDED CONTINUOUS SHEATHING = 144' MIN.


-WALL BRACING IS BY ENGINEERED DESIGN AND NOT PRESCRIPTIVE PER SECTION 602.10 OF THE 2018 NCRC. CONTINUOUS SHEATHING HAS BEEN PROVIDED, ALONG WITH ALTERNATIVE METHODS TO INSURE THE MINIMUM INTENT OF SECTION 602.10 OF THE 2018 NCRC HAS BEEN MET AND EXCEEDED.


-BRACED WALL PANELS SHALL BE FASTENED IN ACCORDANCE WITH TABLE 602.3(1) TO PROVIDE CONTINUOUS PANEL UPLIFT RESISTANCE AND COMPLIANCE WITH NCRBC R602.3.5 AND R802.11 UNLESS NOTED OTHERWISE ON STRUCTURAL PLANS.

# 2ND FLOOR FRAMING PLAN

 $\frac{\text{WALLS AND CEILING}}{1/4" = 1'-0"}$ 

STRUCTURAL ENGINEERS
License No. C-3870
318 W Millbrook Road, Unit 201
Raleigh, North Carolina 27609
Phone: (919) 844-1661

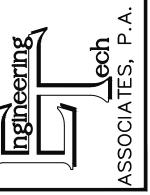

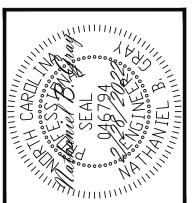


		ENG CAR/NBG		DATE 2/28/2022
	MUC	ENG	REV:	DATE
ADAMS HOMES	STRUCTURAL ADDENDUM	7 CAROLINA SEASON		2131 MASTER
	SCOPE	<b>:#</b> 101		

PLAN NO. 2131

PROJECT NO. 22-18-073

SHEET NO.

The structural design of this plan is the property of Engineering Tech Associates, P.A. These plans are for the one time use at the location and for the client listed. Engineering Tech Associates, P.A. assumes no liability for these plans if they are reproduced, in whole or in part, for construction at any other location without written permission from Engineering Tech Associates, P.A.

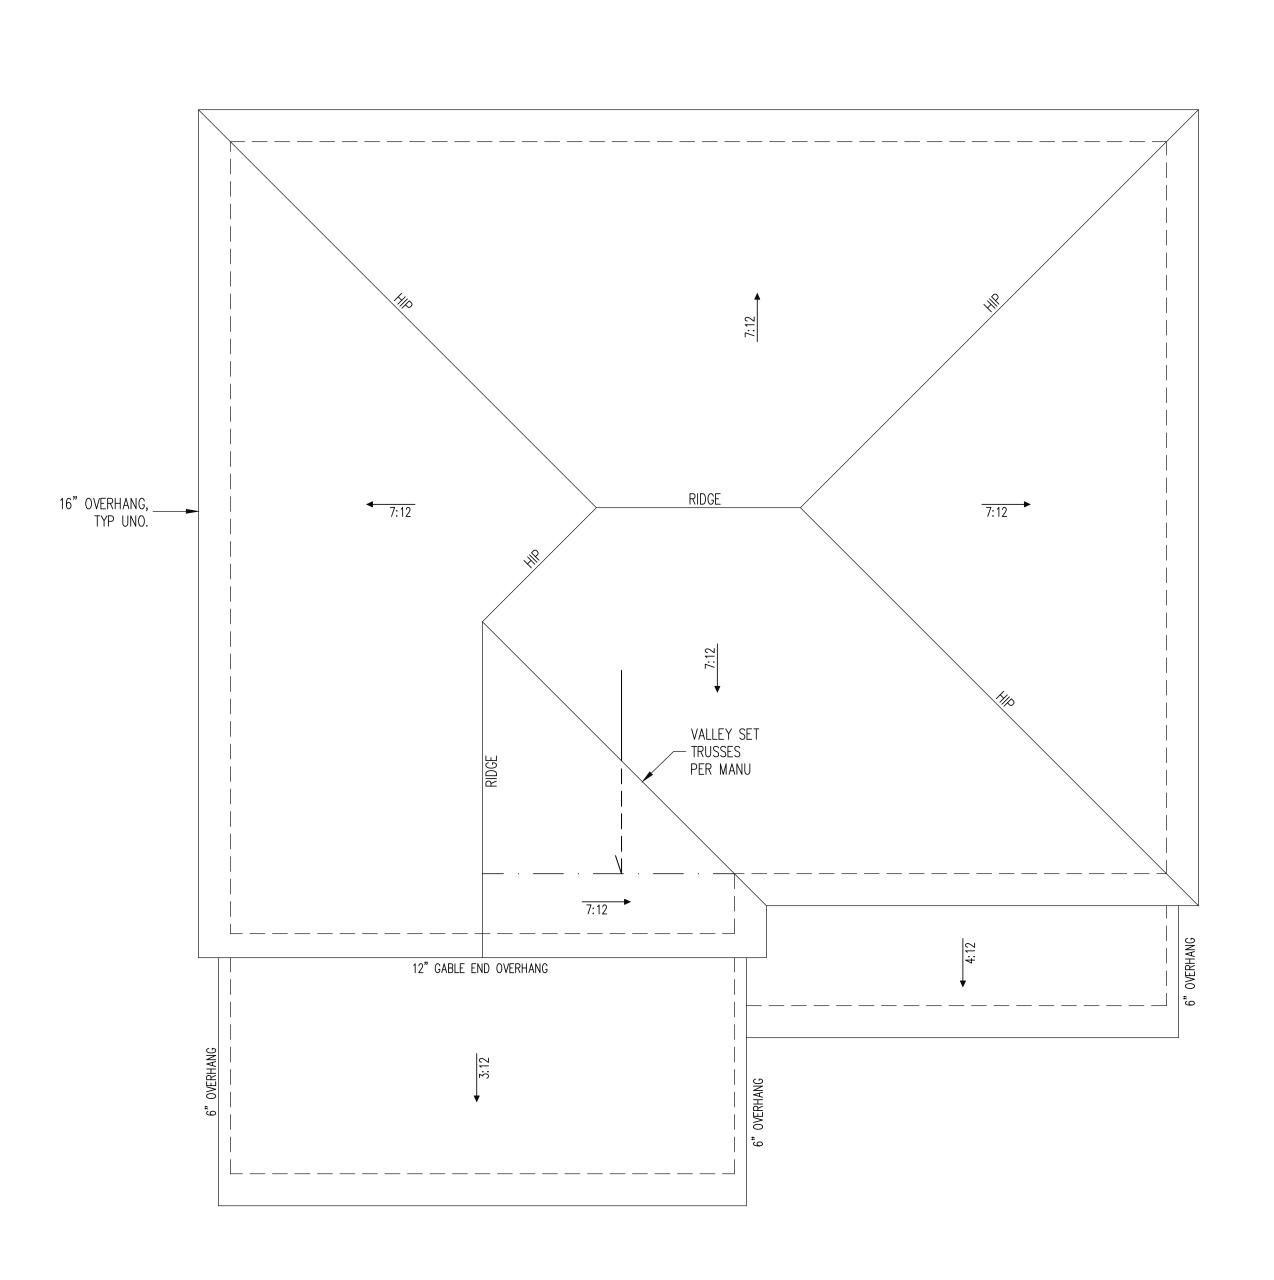

TRUSS UPLIFT CONNECTORS EXPOSURE B, 120 MPH, ANY PITCH, 24" O.C. MAX ROOF TRUSS SPACING

TRUSSES SHALL BE ATTACHED TO SUPPORT WALL FOR UPLIFT RESISTANCE. CONTINUOUS OSB WALL SHEATHING BELOW PROVIDE CONTINUOUS UPLIFT RESISTANCE TO FOUNDATION. ALL TRUSSES SUPPORTED BY INTERMEDIATE SUPPORT WALLS, KNEEWALLS OR BEAMS SHALL BE ATTACHED TO SUPPORTING MEMBER PER SCHE BELOW.

ROOF SPAN IS MEASURED HORIZONTALLY BETWEEN FURTHEST SUPPORT POINTS.

ROOF SPAN

ROOF SPAN

NAILING PER TABLE 602.3(1)

NAILING PER TABLE 602.3(1)

FRAMING NOTES


ROOF ONLY -ROOF TRUSSES PER MANU. TYPICAL U.N.O.


-ROOF PITCHES 7:12 TYP U.N.O. -VERIFY ALL KNEEWALL HEIGHTS, ROOF PITCHES, AND ARCHITECTURAL OVERHANGS PRIOR TO CONSTRUCTION

SIDING OPTION

> ROOF FRAMING PLAN 1/4" = 1'-0"

STRUCTURAL ENGINEERS
License No. C-3870
318 W Millbrook Road, Unit 201
Raleigh, North Carolina 27609
Phone: (919) 844-1661

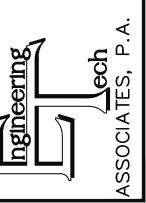

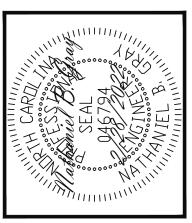

		ENG CAR/NBG		OATE 2/28/2022
	MNG	ENG	REV:	DATE
ADAMS HOMES	STRUCTURAL ADDENDUM	7 CAROLINA SEASON		2131 MASTER
	SCOPE	# 1O1		


(1) SIMPSON H2.5A HURRICANE CLIP TO DBL TOP PLATE OR BEAM

CONNECTOR NAILING PER TABLE 602.3(1) NCRBC 2018 EDITION


PLAN NO. 2131

PROJECT NO. 22-18-073


> SHEET NO. **S4**

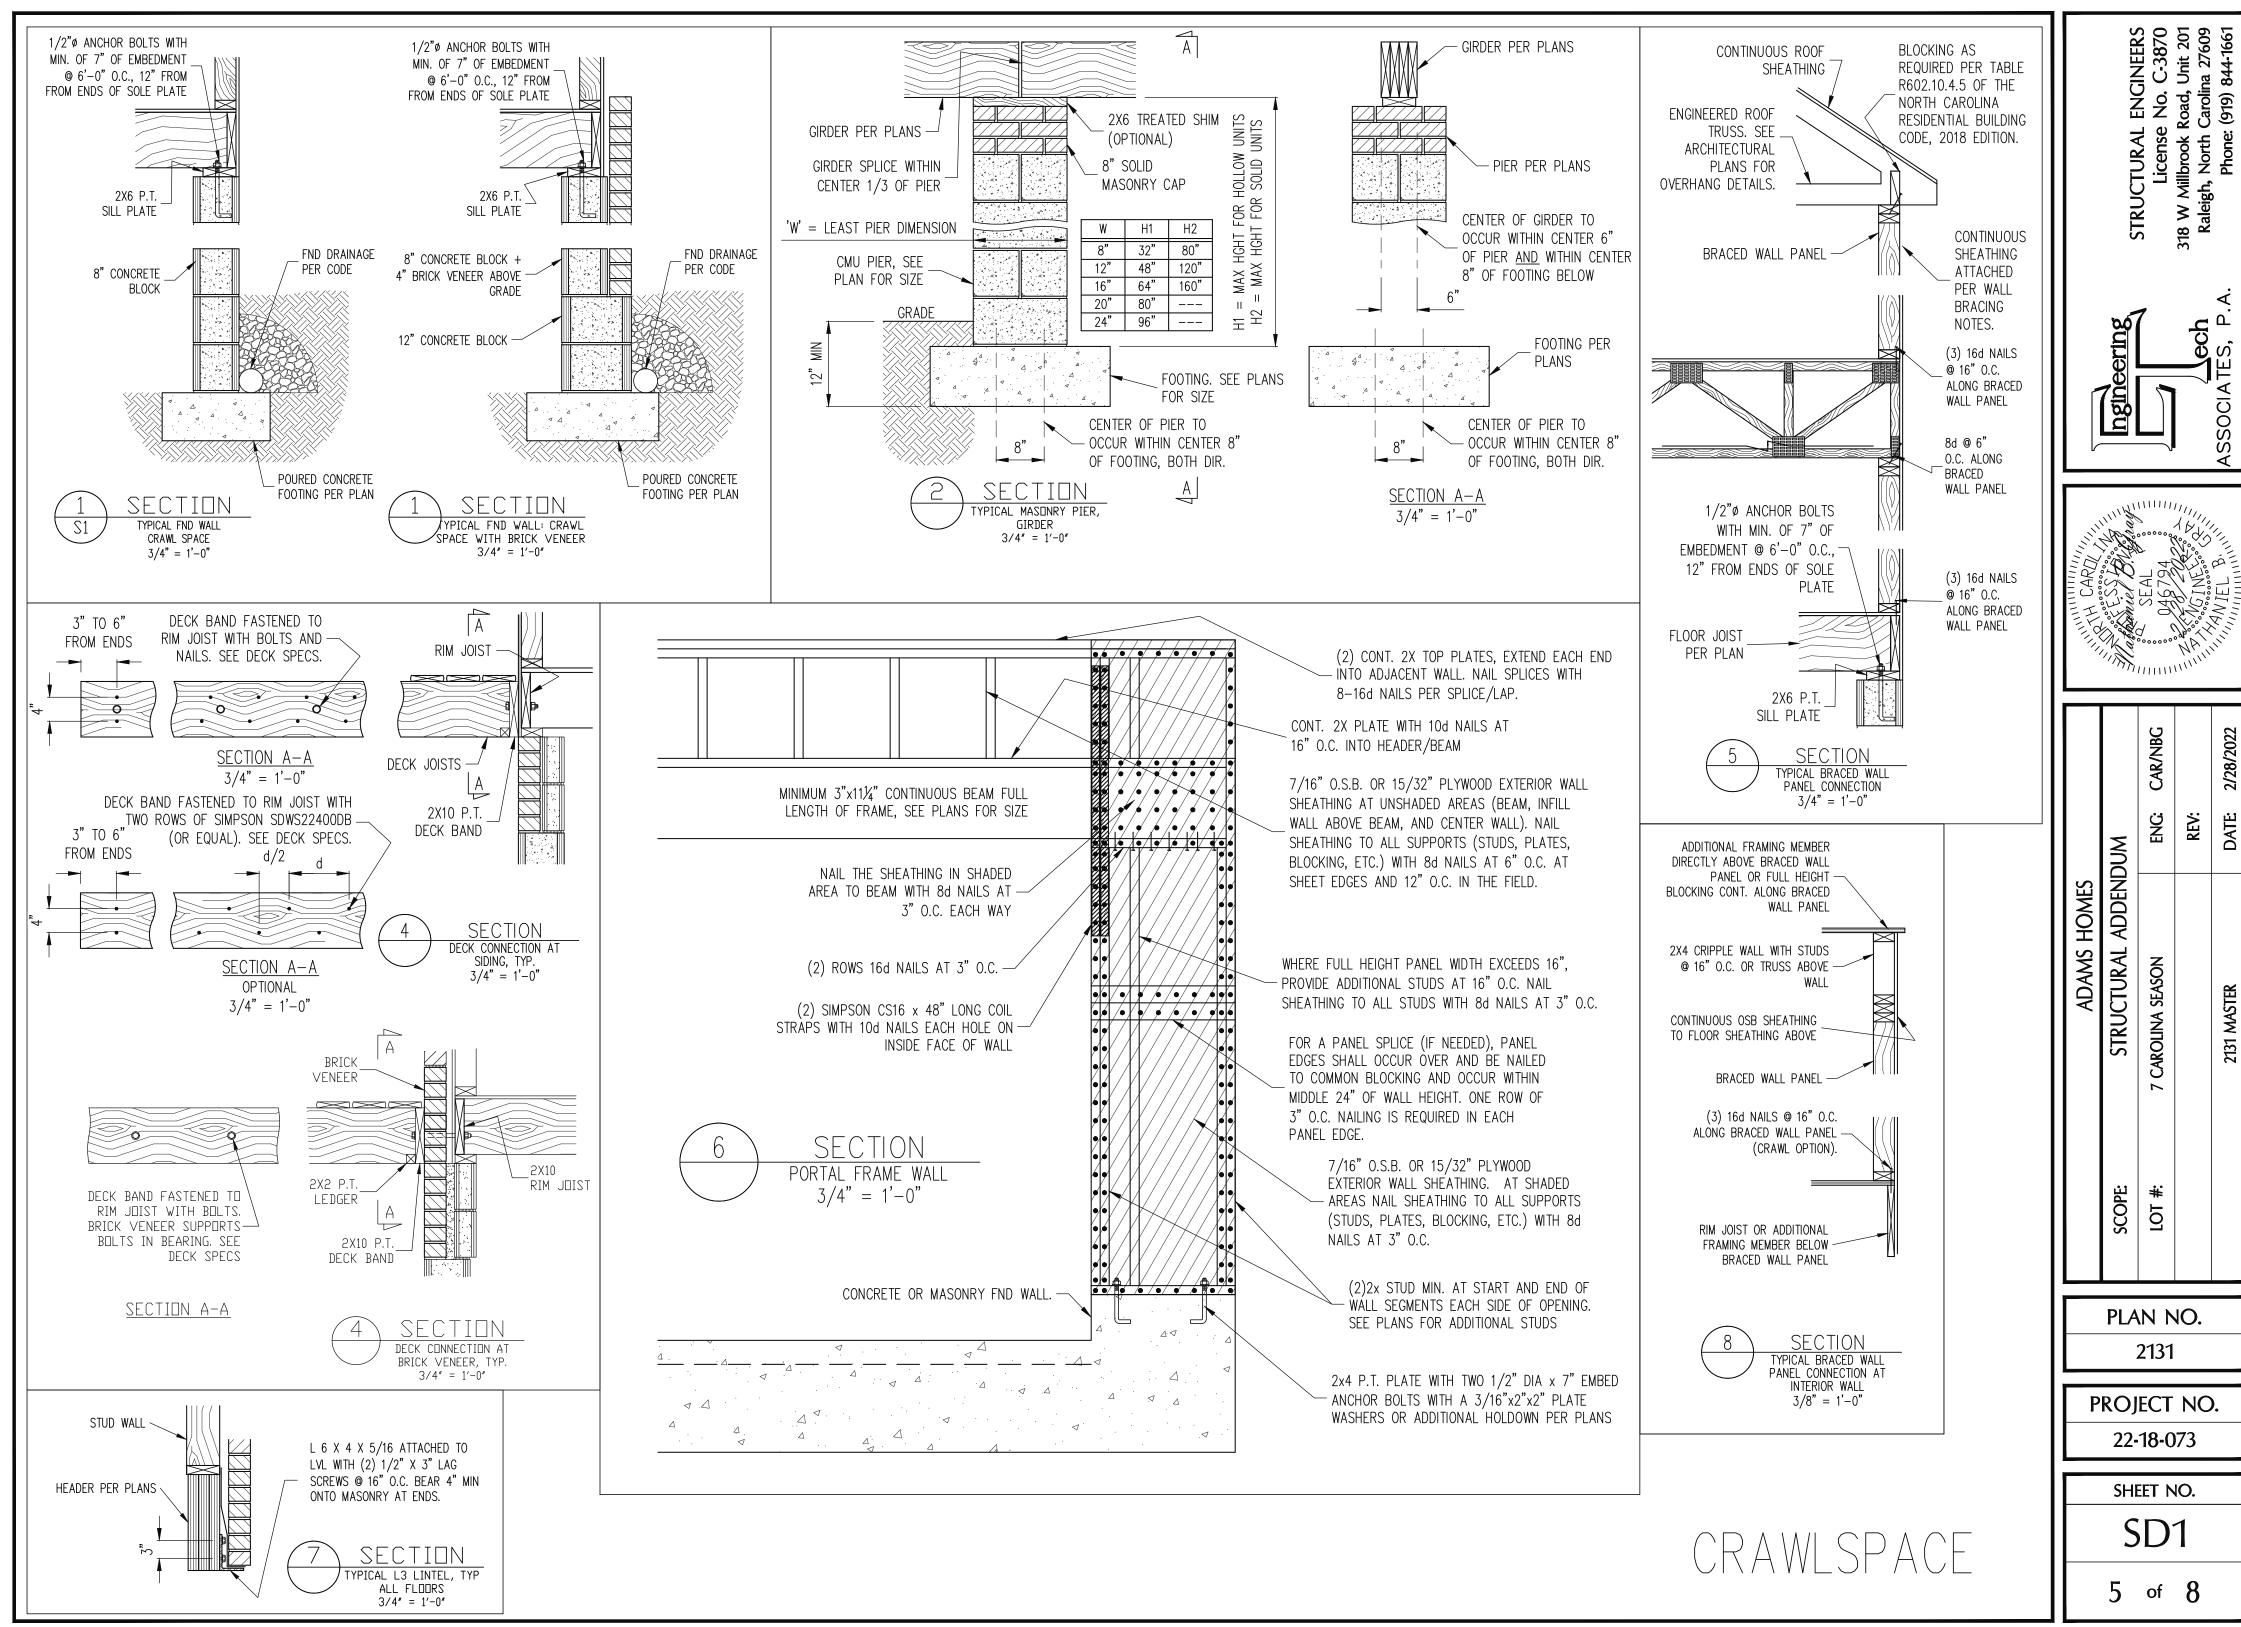




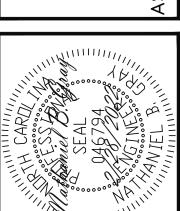


		ADAMS HOMES		
DI 1	SCOPE	STRUCTURAL ADDENDUM	MO	
	FOI #:	7 CAROLINA SEASON	ENG	ENG CAR/NBG
			REV:	
		2131 MASTER	DATE	DATE: 2/28/2022

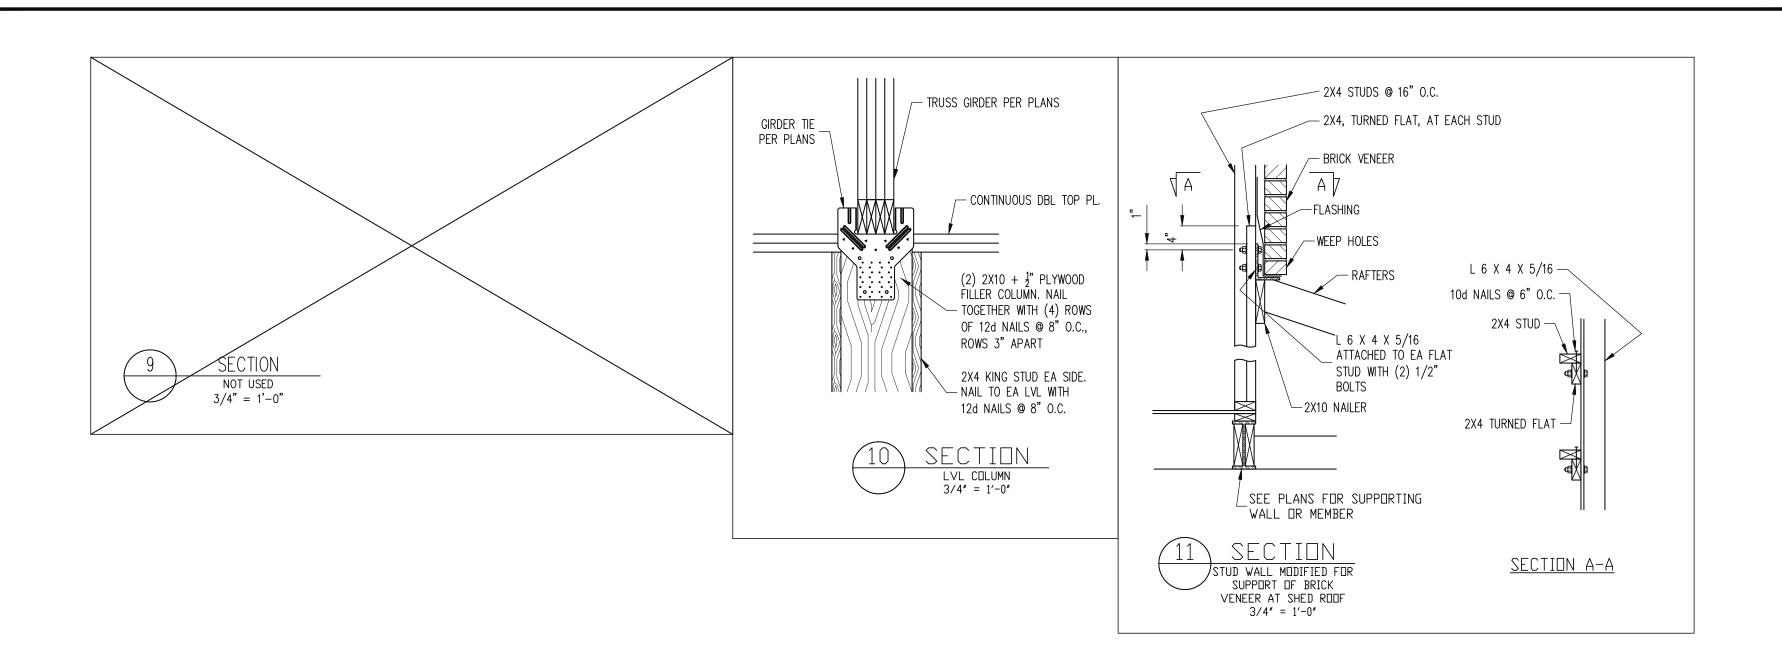

STRUCTURAL ENGINEERS
License No. C-3870
318 W Millbrook Road, Unit 201
Raleigh, North Carolina 27609
Phone: (919) 844-1661

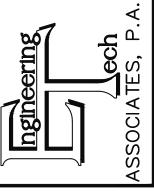

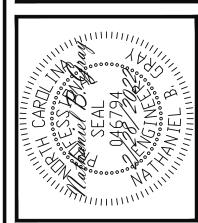

DATE: 2/28/2022	DATE	2131 MASTER
	REV:	
ENG: CAR/NBG	ENG	LOT #: 7 CAROLINA SEASON
	MUC	SCOPE STRUCTURAL ADDENDUM
		ADAMS HOMES

PLAN NO. 2131

PROJECT NO. 22-18-073

SHEET NO.

## CONSTRUCTION SPECIFICATIONS

10 (15 FOR VAULTS)

#### <u>PART 1: GENERAL</u>

- 1.01 CONSTRUCTION SHALL MEET THE REQUIREMENTS OF THE NORTH CAROLINA RESIDENTIAL CODE, 2018 EDITION.
- 1.02 STRUCTURAL STEEL SHALL MEET THE REQUIREMENTS OF THE AISC SPECIFICATION FOR THE DESIGN, FABRICATION AND ERECTION OF STRUCTURAL STEEL FOR BUILDINGS.
- 1.03 REINFORCED CAST IN PLACE CONCRETE SHALL BE PROPORTIONED, MIXED AND PLACED IN ACCORDANCE WITH THE SPECIFICATIONS OF ACI 318, LATEST EDITION.
- 1.04 MASONRY CONSTRUCTION SHALL CONFORM TO THE SPECIFICATIONS OF ACI 530-95, LATEST EDITION.
- METHODS, PROCEDURES AND SEQUENCES OF CONSTRUCTION ARE THE RESPONSIBILITY OF THE CONTRACTOR. THE CONTRACTOR SHALL TAKE ALL NECESSARY PRECAUTIONS TO MAINTAIN AND INSURE THE INTEGRITY OF THE STRUCTURE AT ALL STAGES OF

#### PART 2: DIMENSIONS

2.01 DIMENSIONS SHOWN SHALL GOVERN OVER SCALE ON THESE DRAWINGS.

#### PART 3: DESIGN LOADS

3.01 DESIGN LOADS SHALL CONFORM WITH THE TABLE BELOW:

USE	LIVE LOAD (PSF)	DEAD LOAD (PSF)
BALCONIES, DECKS, ATTICS WITH FIXED STAIR ACCESS, DWELLING UNITS (INCLUDUNG SLEEPING ROOMS), ATTICS WITH FIXED STAIR ACCESS, STAIRS, FIRE ESCAPES	40	10
GARAGES (PASSENGER CARS ONLY) ATTICS (NO STORAGE, LESS THAN 5' HEADROOM)	50 10	 10
ATTICS (WITH STORAGE)	20	10

- NOTES: INDIVIDUAL STAIR TREADS ARE TO BE DESIGNED FOR THE UNIFORMLY DISTRIBUTED LIVE LOAD OR A 300 LB. CONCENTRATED LOAD ACTING OVER AN AREA OF 4 SQ. IN., WHICHEVER PRODUCES THE GREATER STRESS
  - GUARD RAILS AND HAND RAILS ARE TO BE DESIGNED FOR A SINGLE CONCENTRATED LOAD OF 200 LB. APPLIED IN ANY DIRECTION AT ANY POINT ALONG THE TOP. - BUILDER TO VERIFY DEAD LOAD DOES NOT EXCEED 10 PSF WHEN HEAVY FLOOR OR ROOF FINISHES SUCH AS TILE OR SLATE ARE UTILIZED
- 3.02 INTERIOR WALLS: 5 PSF LATERAL.

R00F

- 3.03 BASIC WIND DESIGN VELOCITY OF 120 MPH.
- 3.04 LOAD DURATION FACTOR FOR ROOF STRUCTURAL MEMBERS IS 1.15.
- 3.05 SOIL BEARING CAPACITY 2000 PSF (PRESUMPTIVE).

- 4.01 STRUCTURAL STEEL SQUARE AND RECTANGULAR TUBING SHALL CONFORM TO ASTM A500 GRADE B MINIMUM GRADE. ALL OTHER STRUCTURAL STEEL SHALL CONFORM TO ASTM A992 MINIMUM GRADE TYP UNO.
- 4.02 REBAR SHALL BE DEFORMED STEEL CONFORMING TO ASTM A615 GRADE 60 TYP UNO
- 4.03 SOLID SAWN WOOD FRAMING DESIGN IS BASED ON NO. 2 SPRUCE PINE FIR FOR JOISTS, RAFTERS, WOOD GIRDERS/BEAMS, STUDS, ETC. ALLOWANCE HAS BEEN MADE FOR SYP #2
- 4.04 LVL OR PSL MINIMUM ALLOWABLE DESIGN STRESSES ARE AS FOLLOWS: E= 1.9 X 10E6 PSI, Fb = 2600 PSI, Fv = 285 PSI, Fc = 750 PSI
- 4.05 LSL MINIMUM ALLOWABLE DESIGN STRESSES ARE AS FOLLOWS: E= 1.3 X 10E6 PSI, Fb = 1700 PSI, Fv = 400 PSI, Fc = 680 PSI
- 4.06 BOLTS SHALL CONFORM TO ASTM A307 MINIMUM GRADE TYP UNO
- 4.07 WELDING ELECTRODES SHALL BE E70XX
- 4.08 LUMBER IN CONTACT WITH THE GROUND, CONCRETE OR MASONRY SHALL BE PRESSURE TREATED IN ACCORDANCE WITH AWPA STANDARD C-15. ALL OTHER EXPOSED LUMBER SHALL BE TREATED IN ACCORDANCE WITH AWPA STANDARD C-2 OR BY ANY METHOD GIVING EQUAL PROTECTION. THE BUILDING CODE OFFICE MAY ALSO APPROVE A NATURAL DECAY RESISTANT WOOD PER SECTION 19-6(A)

#### 4.09 CAST IN PLACE CONCRETE SHALL BE OF NORMAL WEIGHT AND SHALL HAVE A MINIMUM COMPRESSIVE STRENGTH OF 3000 PSI AT 28 DAYS TYP UNO.

- 4.10 CONCRETE MASONRY UNITS SHALL CONFORM TO ASTM C 90 OR ASTM C 55.
- 4.12 NAILS SHALL BE COMMON WIRE NAILS TYP UNO.

4.11 MORTAR SHALL BE TYPE S CONFORMING TO ASTM C 476.

4.13 LAG SCREWS SHALL CONFORM TO ANSI/ASME STANDARD B18.2.1-1981.

#### PART 5: CONSTRUCTION

- FLITCH PLATE BEAMS SHALL CONSIST OF A CONTINUOUS STEEL PLATE BOLTED BETWEEN TWO PIECES OF CONTINUOUS LUMBER AS SIZED ON THE PLANS. BOLT PIECES TOGETHER USING 1/2" Ø BOLTS SPACED AT 24" O.C. STAGGERED TOP TO BOTTOM OF THE BEAM. MAINTAIN A 2" EDGE DISTANCE. PLACE TWO BOLTS, ONE ABOVE THE OTHER, 6" FROM
- 5.02 STEEL, LVL AND FLITCH PLATE BEAMS BEARING ON A STUD WALL PERPENDICULAR TO THE BEAM SHALL BEAR FULL WIDTH ON THE SUPPORTING WALL INDICATED AND SHALL BE SUPPORTED BY A MINIMUM OF THREE GANGED STUDS, OR A GANGED STUD COLUMN WITH A NUMBER OF STUDS SUCH THAT THE STUD COLUMN IS AT LEAST AS WIDE AS THE BEAM BEING SUPPORTED, WHICHEVER IS GREATER, TYP UNO.
- 5.03 STEEL, LVL AND FLITCH PLATE BEAMS BEARING ONTO THE END OF A STUD WALL PARALLEL TO THE BEAM SHALL BEAR A MINIMUM OF 4 1/2" ONTO THE WALL AND BE SUPPORTED BY A TRPL STUD GANGED COLUMN TYP UNO.
- 5.04 SOLID SAWN LUMBER GANGED BEAMS BEARING ON A STUD WALL PERPENDICULAR TO THE BEAM SHALL SHALL BEAR FULL WIDTH ON THE SUPPORTING WALL INDICATED (LESS 1 1/2" TO ALLOW FOR A CONTINUOUS RIM JOIST) AND SHALL BE SUPPORTED BY À
- 5.05 SOLID SAWN LUMBER GANGED BEAMS BEARING ONTO THE END OF A STUD WALL PARALLEL TO THE BEAM SHALL BEAR A MINIMUM OF 3" ONTO THE WALL AND BE SUPPORTED BY A DBL STUD GANGED COLUMN TYP UNO.
- 5.06 EXTRA JOISTS OR SINGLE LVL MEMBERS OF 1.75" OR LESS WIDTH, BEARING ON A STUD WALL PERPENDICULAR TO THE BEAM SHALL BEAR ON THE WALL A MINIMUM OF 2" AND SHALL BE SUPPORTED BY ONE ADDITIONAL STUD.
- 5.07 SOLID SAWN LUMBER JOISTS THAT ARE GANGED TO FORM A BEAM SHALL HAVE ADJACENT MEMBERS IN THE BEAM NAILED TOGETHER WITH THREE ROWS OF 10d
- 5.08 LVL MEMBERS THAT ARE GANGED TO FORM A BEAM SHALL HAVE ADJACENT MEMBERS IN THE BEAM FASTENED TOGETHER PER MANUFACTURERS RECOMMENDATIONS, TYP UNO
- 5.09 STUDS THAT ARE GANGED TO FORM A COLUMN SHALL HAVE ADJACENT STUDS WITHIN THE COLUMN NAILED TOGETHER WITH ONE ROW OF 10d NAILS AT 8" O.C. (TWO ROWS OF 10d NAILS @ 8" O.C., 3" APART, FOR 2X8 OR 2X10 STUDS) ALL COLUMNS SHALL BE CONTINUOUS DOWN TO THE FOUNDATION OR OTHER PROPERLY DESIGNED STRUCTURAL ELEMENT SUCH AS A BEAM. COLUMNS TRANSFERRING LOADS THROUGH FLOOR LEVELS SHALL BE SOLIDLY BLOCKED FOR THE FULL WIDTH OF THE STUD COLUMN WITHIN THE CAVITY FORMED BY THE FLOOR JOISTS.
- 5.10 STUD WALLS SHALL CONSIST OF 2X4 STUDS SPACED AT 16" O.C. UNO. STUDS SHALL BE CONTINUOUS FROM SOLE PLATE AT FLOOR TO DOUBLE TOP PLATE AT THE CEILING OR ROOF. NO INTERMEDIATE BANDS OR PLATES SHALL CAUSE DISCONTINUITIES IN A STUD WALL EXCEPT AS REQUIRED FOR DOOR OR WINDOW OPENINGS. THE KING STUDS FOR SUCH OPENINGS SHALL BE CONTINUOUS.
- 5.11 PILOT HOLES SHALL BE USED FOR LAG SCREW INSTALLATION AND SHALL BE BORED ACCORDING TO NDS SPECIFICATIONS.
- 5.12 ALL WELDING SHALL BE PERFORMED BY AN AWS CERTIFIED WELDER
- 5.13 ALL CONCRETE, INCLUDING CONCRETE FOR FOOTINGS, IS TO BE CAST IN PLACE, TYP UNO.
- 5.14 BOLTS AND LAG SCREWS USED FOR BOLTING WOOD MEMBERS SHALL HAVE STANDARD WASHERS INSTALLED FOR THE NUTS AND BOLT / SCREW HEADS

- 6.01 IN LIEU OF WELDED WIRE FABRIC IN SLABS: SYNTHETIC POLYPROPYLENE FIBRILLATED MICRO FIBERS, FIBER LENGTH 1 1/2", DOSAGE RATE 1 1/2 LBS/CU YD.
- OTHER MATERIAL OR MEMBER SIZE SUBSTITUTIONS REQUIRE THE WRITTEN AUTHORIZATION OF THE DESIGNERS. UNAUTHORIZED DEVIATIONS ARE THE SOLE RESPONSIBILITY OF THE

- A DECK IS AN EXPOSED EXTERIOR WOOD FLOOR STRUCTURE WHICH MAY BE ATTACHED TO A STRUCTURE OR BE FREE STANDING, ROOFED PORCHES, OPEN OR SCREENED IN, MAY BE CONSTRUCTED USING THESE PROVISIONS.
- 2. SUPPORT POSTS SHALL BE SUPPORTED BY A FOOTING.
- WHEN ATTACHED TO A STRUCTURE, THE STRUCTURE TO WHICH ATTACHED SHALL HAVE A TREATED WOOD BAND FOR THE LENGTH OF THE DECK, OR CORROSION RESISTANT FLASHING SHALL BE USED TO PREVENT MOISTURE FROM COMING IN CONTACT WITH THE UNTREATED FRAMING OF THE STRUCTURE. THE DECK BAND AND THE STRUCTURE BAND SHALL BE CONSTRUCTED IN CONTACT WITH EACH OTHER EXCEPT AT BRICK VENEER AND WHERE PLYWOOD SHEATHING IS REQUIRED AND PROPERLY FLASHED. SIDING SHALL NOT BE INSTALLED BETWEEN THE STRUCTURE AND THE DECK BAND. IF ATTACHED TO A BRICK VENEER STRUCTURE, NEITHER FLASHING NOR A TREATED BAND FOR THE BRICK STRUCTURE IS REQUIRED. IN ADDITION, THE TREATED DECK BAND SHALL BE CONSTRUCTED IN CONTACT WITH THE BRICK VENEER.
- WHEN THE DECK IS SUPPORTED AT THE STRUCTURE BY ATTACHING THE DECK TO THE STRUCTURE, THE FOLLOWING ATTACHMENT SCHEDULES SHALL APPLY FOR ATTACHING THE DECK BAND TO THE STRUCTURE:
- A. ALL STRUCTURES EXCEPT BRICK VENEER STRUCTURES

	JOIST LENGTH					
	UP TO 8' MAX.	UP TO 8' MAX. UP TO 16' MAX.				
REQUIRED FASTENERS	ONE- 5/8" Ø BOLT @ 42" O.C. AND (2) ROWS OF 12d NAILS @ 8" O.C. OR TWO ROWS OF SIMPSON SDWS22400DB @ d = 32" O.C. STAGGERED	ONE- 5/8" Ø BOLT @ 20" O.C. AND (3) ROWS OF 12d NAILS @ 6" O.C. OR TWO ROWS OF SIMPSON SDWS22400DB @ d = 16" O.C. STAGGERED				

A . BRICK VENEER STRUCTURES

	JOIST LENGTH		
	UP TO 8' MAX.	UP TO 16' MAX.	
REQUIRED FASTENERS	ONE- 5/8" Ø BOLT @ 28" O.C.	ONE- 5/8" Ø BOLT @ 16" O.C.	

- IF THE DECK BAND IS SUPPORTED BY A 1/2" MINIMUM MASONRY LEDGE ALONG THE FOUNDATION WALL, 5/8" Ø BOLTS SPACED @ 48" O.C. MAY BE USED FOR SUPPORT.
- OTHER MEANS OF SUPPORT, SUCH AS JOIST HANGERS, MAY BE USED TO CONNECT DECK
- GIRDERS SHALL BEAR DIRECTLY ON POSTS OR BE BE CONNECTED TO THE SIDES OF POSTS WITH 2- 5/8" Ø BOLTS
- FLOOR DECKING SHALL BE NO. 2 GRADE TREATED SOUTHERN PINE OR EQUIVALENT. THE MINIMUM FLOOR DECKING THICKNESS SHALL BE AS FOLLOWS:

## DECK SPECIFICATIONS

JOIST SPAN	DECKING
12" O.C.	1" S4S
16" O.C.	1" T&G
24" O.C.	1 1/4" S4S
32" O.C.	2" S4S

MAXIMUM HEIGHT OF DECK SUPPORT POSTS IS AS FOLLOWS:

POST SIZE	MAX POST HEIGHT		
4X4	8'		
6X6	20'		
ENGINEERED	20' +		

- NOTES: 1) THIS TABLE IS BASED ON NO. 2 TREATED SOUTHERN PINE POSTS. 2) THIS TABLE IS BASED ON A MAXIMUM TRIBUTARY AREA OF 128 SQ. FT. S) POST HEIGHT IS FROM TOP OF FOOTING TO BOTTOM OF GIRDER.
- DECKS SHALL BE BRACED TO PROVIDE LATERAL STABILITY BY ONE OF THE FOLLOWING
- A. WHEN THE DECK FLOOR HEIGHT IS LESS THAN 4'-0" AND THE DECK IS ATTACHED TO THE STRUCTURE IN ACCORDANCE WITH SECTION 4, LATERAL BRACING IS NOT REQUIRED.
- B. 4X4 WOOD KNEE BRACES MAY BE PROVIDED ON EACH COLUMN IN BOTH DIRECTIONS. THE KNEE BRACES SHALL ATTACH TO EACH POST AT A POINT NOT LESS THAN 1/3 OF THE POST LENGTH FROM THE TOP OF THE POST, AND THE BRACES SHALL BE ANGLED BETWEEN 45° AND 60° FROM THE HORIZONTAL, KNEE BRACES SHALL BE ATTACHED AT THE ENDS TO THE GIRDER AND THE POST WITH ONE - 5/8" BOLT
- C. FOR FREE STANDING DECKS WITHOUT KNEE BRACES OR DIAGONAL BRACING, LATERAL STABILITY MAY BE PROVIDED BY EMBEDDING THE POSTS IN CONCRETE IN ACCORDANCE

POST SIZE	TRIBUT. AREA	POST HEIGHT	EMB. DEPTH	CONC. DIAM.
4X4	48 SQ. FT.	4'-0"	2'-6"	1'-0"
6X6	120 SQ. FT.	6'-0"	3'-6"	1'-8"

- D. 2X6 DIAGONAL VERTICAL CROSS BRACING SHALL BE PROVIDED IN TWO PERPENDICULAR DIRECTIONS FOR FREE STANDING DECKS OR PARALLEL TO THE STRUCTURE AT THE EXTERIOR COLUMN LINE FOR ATTACHED DECKS. THE BRACES SHALL BE ATTACHED TO THE POSTS WITH ONE -5/8"  $\phi$  BOLT AT EACH END OF THE BRACE.
- 1) ALL NAILS AND BOLTS ARE TO BE HOT DIPPED GALVANIZED. 2) MINIMUM EDGE DISTANCE FOR BOLTS IS 2 1/2". 3) NAILS MUST PENETRATE THE SUPPORTING STRUCTURE BAND A MINIMUM OF 1 1/2".

FLR FLOOR

ALL WORK IS TO BE DONE IN STRICT ACCORDANCE WITH STATE AND LOCAL CODES. THE BUILDER
IS RESPONSIBLE FOR REVIEWING PLANS PRIOR TO CONSTRUCTION. IF ENGINEERING SERVICES HAS
BEEN PROVIDED THE BUILDER SHALL VERIFY THAT THE FOUNDATION AND STRUCTURAL PLANS
HAVE BEEN SEALED BY AN ENGINEER REGISTERED BY THE STATE. IF THE PLANS HAVE NOT BEEN
SIGNED AND SEALED, THE BUILDER SHALL IMMEDIATELY CONTACT ENGINEERING TECH BEFORE
PROCEEDING FURTHER. ANY ERRORS DUE TO A FAILURE TO FOLLOW THE ABOVE PROCEDURES
SHALL NOT BE THE RESPONSIBILITY OF ENGINEERING TECH. ALL FINAL SETS OF THE SAME PLAN
ISSUED TO A BUILDER SHOULD BE REVIEWED FOR UNIFORMITY, ESPECIALLY IF PRIOR SETS OF
PLANS HAVE REEN ISSUED AS STUDY COPIES

NOTES

ENGINEERING TECH DOES NOT PERFORM FENESTRATION, ROOF VENT, OR ATTIC CALCULATIONS OR ANY OTHER AREA CALCULATIONS THAT ARE NOT RELATED TO STRUCTURAL ENGINEERING.

TRUSSES TO BE DESIGNED BY AN ENGINEER REGISTERED IN NORTH CAROLINA. FINAL TRUSS DRAWING SHOULD BE SUBMITTED TO ENGINEERING TECH ASSOCIATES, PA FOR REVIEW

ABV	ABOVE	FND	FOUNDATION
В.	BOTH	FTG	FOOTING
B.E.	BOTH ENDS	HDG	HOT DIPPED
BTWN	BETWEEN		GALVANIZED
CONC	CONCRETE	HGR	HANGER
CS	CONTINUOUS SHEATHING	LVL	LAMINATED VENE
DIA	DIAMETER		LUMBER
DBL	DOUBLE	NTS	NOT TO SCALE
DJ	DOUBLE JOIST	0.C.	ON CENTER
DSP	DBL STUD POCKET	PSL	PARALLEL STRAN
EQ	EQUAL		LUMBER
EA	EACH	PT	PRESSURE TREAT
FLG	FLANGE	QJ	QUAD JOIST
FL PL	FLITCH PLATE	SP	STUD POCKET

# ARREVIATIONS

טטר	INE VIA HOINS	)	
FND	FOUNDATION	TJ	TRIPLE JOIST
FTG	FOOTING	TYP	TYPICAL
HDG	HOT DIPPED	TRPL	TRIPLE
	GALVANIZED	TSP	TRIPLE STUD POCKET
HGR	HANGER	UNO	UNLESS NOTED
LVL	LAMINATED VENEER		OTHERWISE
	LUMBER	XJ	EXTRA JOIST
NTS	NOT TO SCALE		
0.C.	ON CENTER		
PSL	PARALLEL STRAND		
	LUMBER		
PT	PRESSURE TREATED		
QJ	QUAD JOIST		
SP	STUD POCKET		
SQ	SQUARE		
	FND FTG HDG HGR LVL NTS O.C. PSL PT QJ SP	FND FOUNDATION FTG FOOTING HDG HOT DIPPED GALVANIZED HGR HANGER LVL LAMINATED VENEER LUMBER NTS NOT TO SCALE O.C. ON CENTER PSL PARALLEL STRAND LUMBER PT PRESSURE TREATED QJ QUAD JOIST SP STUD POCKET	FTG FOOTING TYP HDG HOT DIPPED TRPL GALVANIZED TSP HGR HANGER UNO LVL LAMINATED VENEER LUMBER XJ NTS NOT TO SCALE O.C. ON CENTER PSL PARALLEL STRAND LUMBER PT PRESSURE TREATED QJ QUAD JOIST SP STUD POCKET

BUILDER IS PERMITTED TO USE 11.875" TJI/210 JOISTS @ 19.2" O.C. IN LIEU OF 2X10'S @ 16" O.C. 2X10 BEAMS ARE TO BE REPLACED WITH THE SAME NUMBER OF 1.75" X 11.875" LVL'S AND JOISTS SHOULD BE ATTACHED TO FLUSH BEAMS WITH SIMP. IUS2.06/11.88 OR EQUIVALENT.


L ENGINEERS


Se No. C-3870

Road, Unit 201

Carolina 27609

(919) 844-1661 License License / Millbrook Resigh, North C <u>8</u> ≤ ∞ ≈

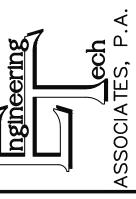

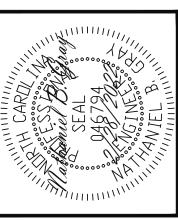



		ENG: CAR/NBG		DATE 2/28/2022
	MNC	ENG	REV:	DATE
ADAMS HOMES	STRUCTURAL ADDENDUM	7 CAROLINA SEASON		2131 MASTER
	SCOPE	<b>:# 101</b>		


PLAN NO. 2131

PROJECT NO. 22-18-073

> SHEET NO. SPEC

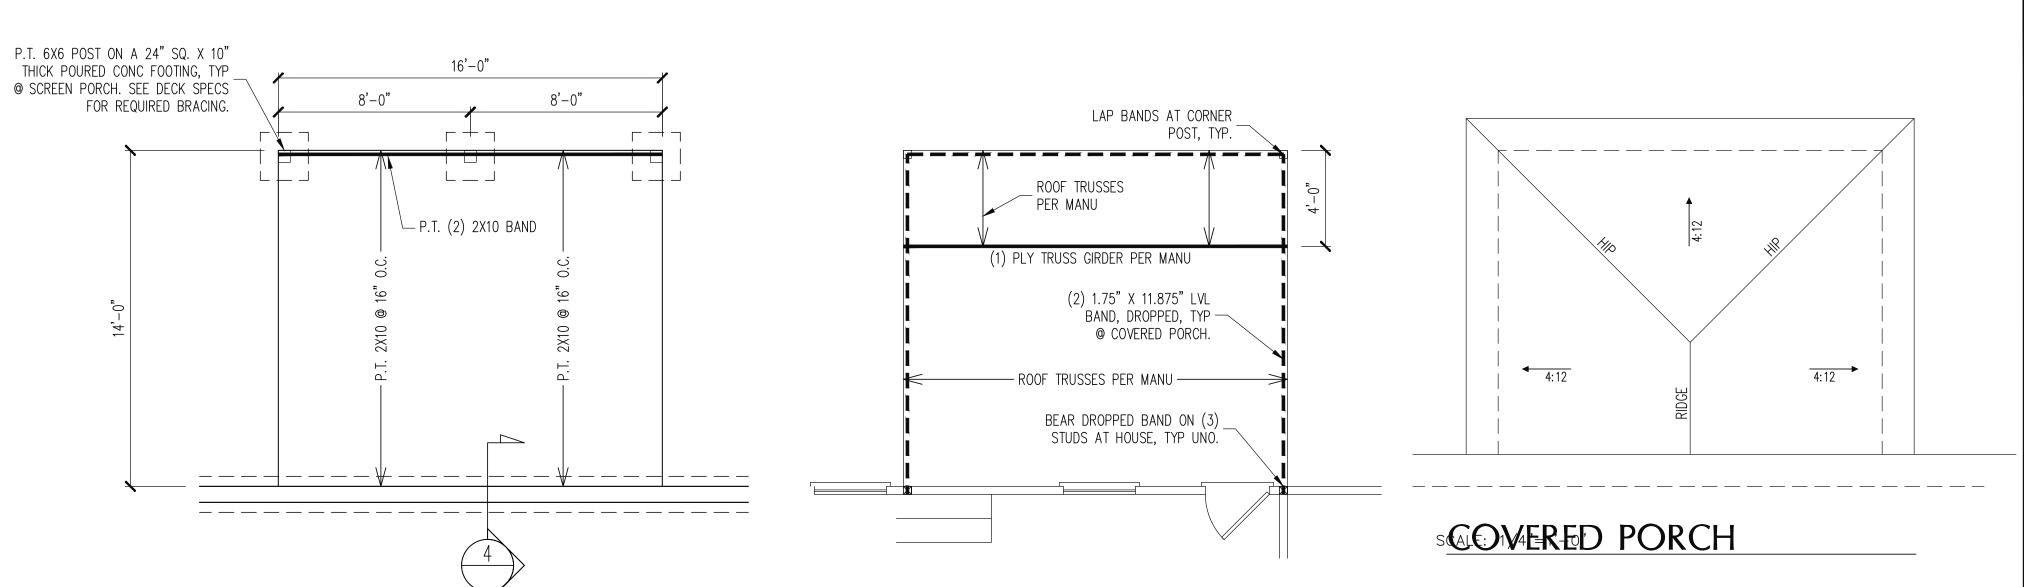


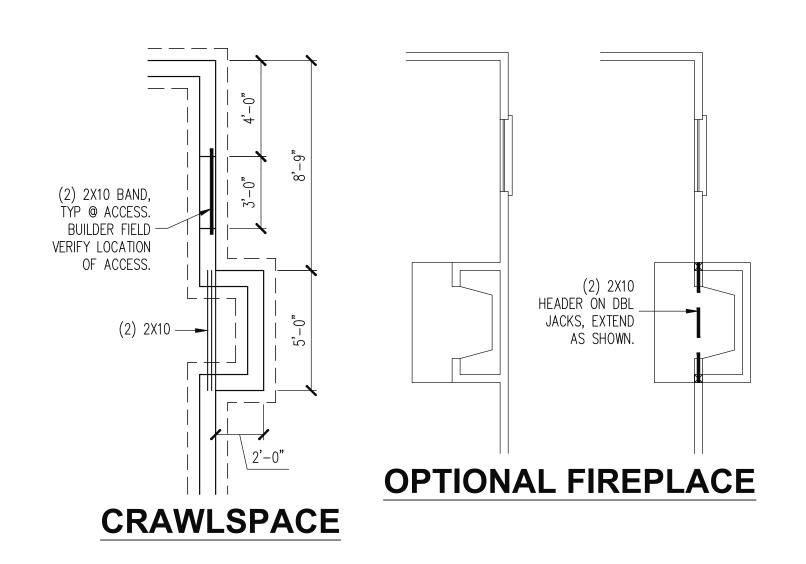


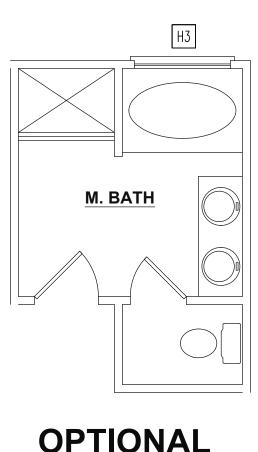

OPTIONAL MASTER BATH

STRUCTURAL ENGINEERS
License No. C-3870
318 W Millbrook Road, Unit 201
Raleigh, North Carolina 27609
Phone: (919) 844-1661

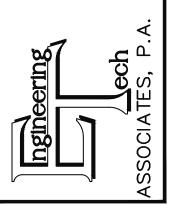

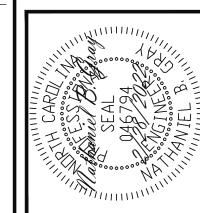

		ENG: CAR/NBG		2/28/2022		
	WNC	ENG	REV:	DATE		
ADAMS HOMES	STRUCTURAL ADDENDUM	LOT #: 7 CAROLINA SEASON		2131 MASTER		
PLANINO						

PLAN NO. 2131

PROJECT NO. 22-18-073

SHEET NO.