




**SOUTH ELEVATION**

SCALE: 1/4" = 1'-0"



**EAST ELEVATION**

SCALE: 1/4" = 1'-0"

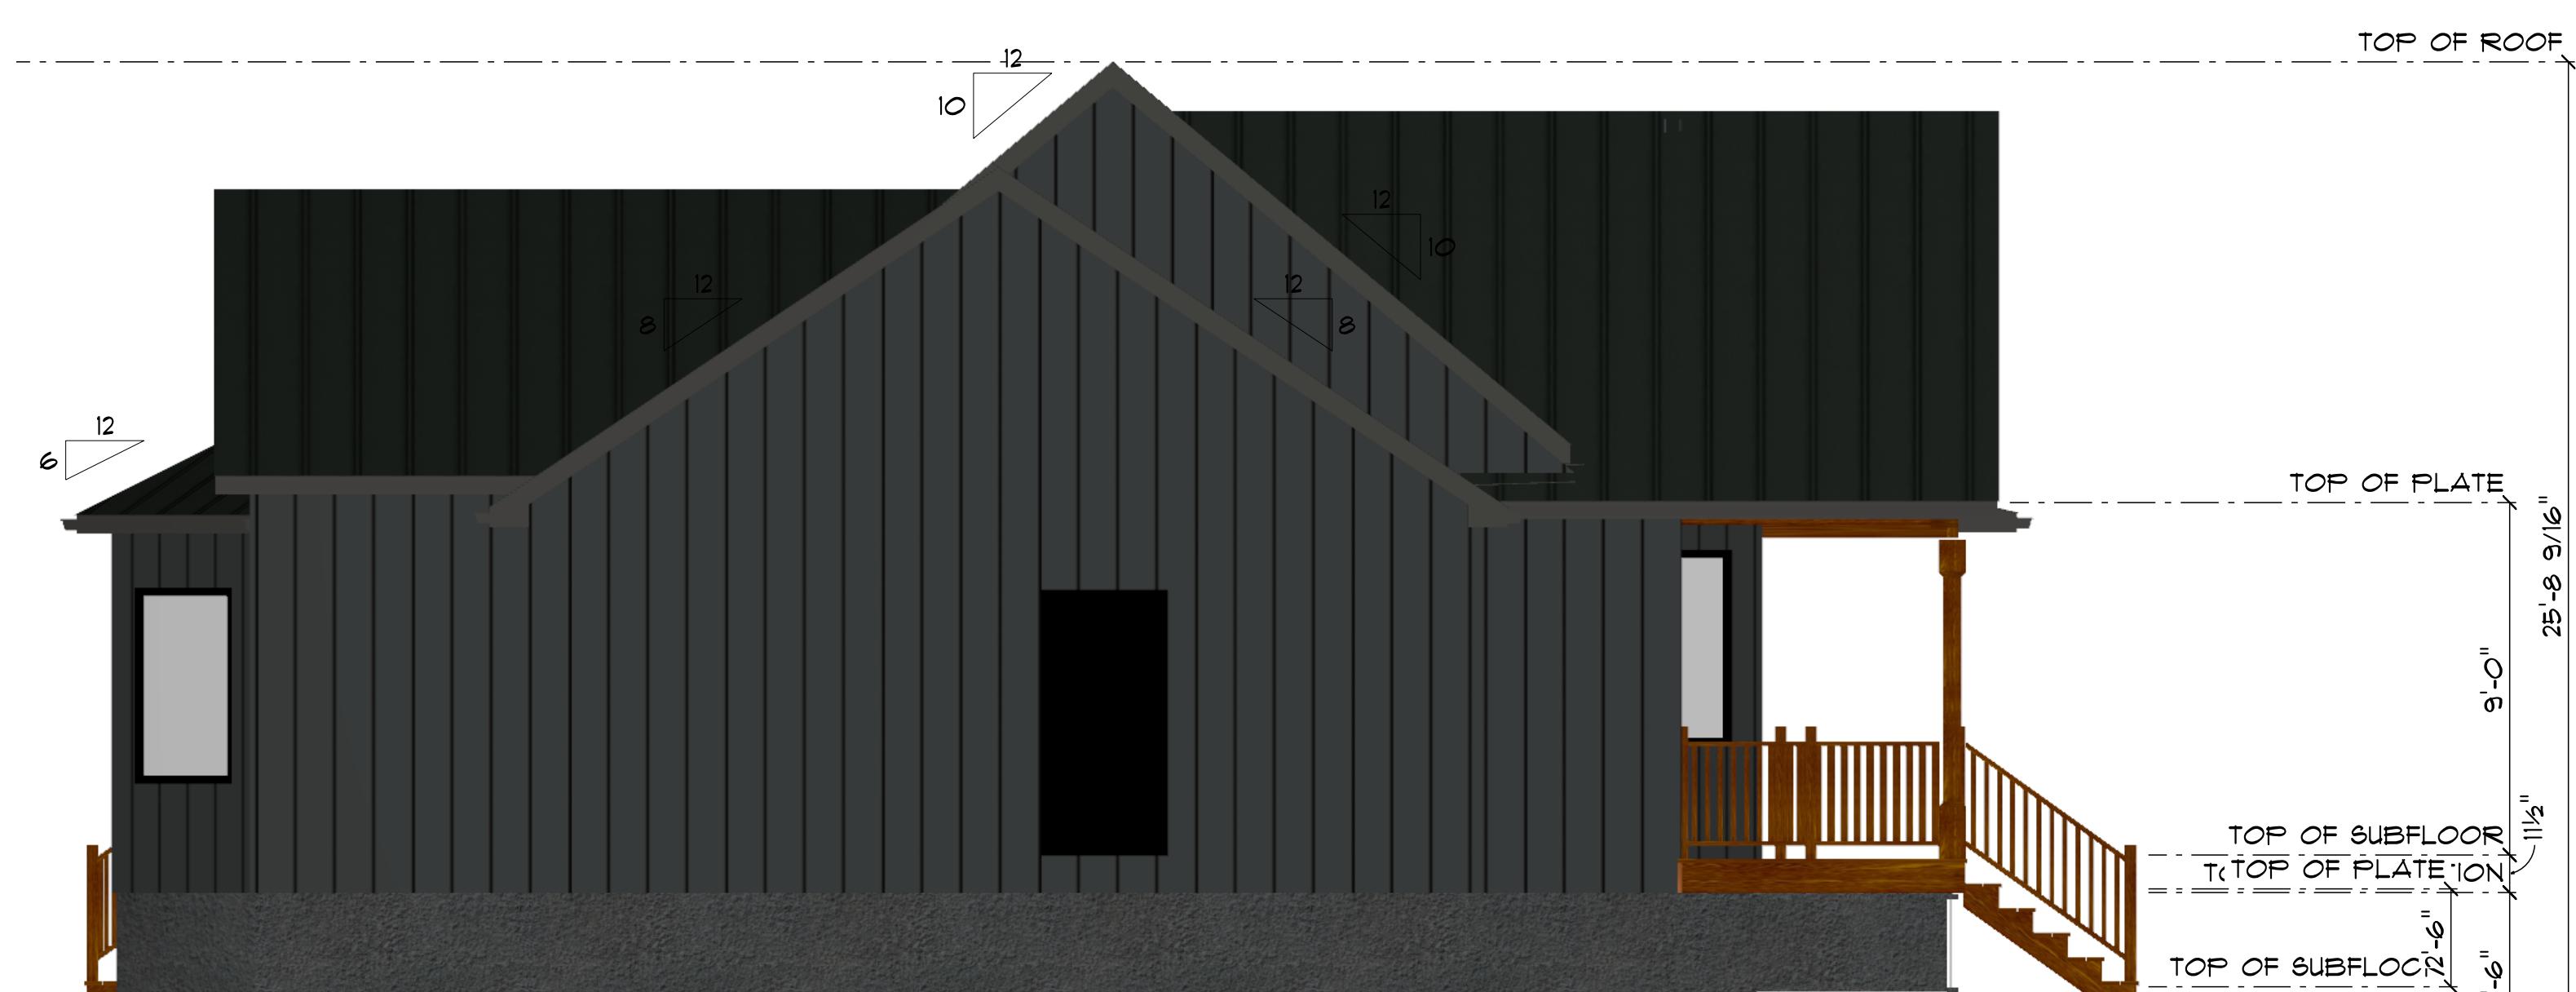

**WEST ELEVATION**

SCALE: 1/4" = 1'-0"



**NORTH ELEVATION**

SCALE: 1/4" = 1'-0"

COPYRIGHT NOTICE:  
ALL DRAFTING DEFICITED IN THESE DRAWINGS ARE DONE WITH  
THE EXPRESS PERMISSION OF THE CLIENT. B R DRAFTING AND  
DESIGN LLC RESERVES THE RIGHT TO MAKE COPIES, SELL OR  
DISTRIBUTE COPIES, PREPARE DERIVATIVE WORKS, AND  
PUBLICLY DISPLAY THE WORK AS THEY SEE FIT

PRIVATE RESIDENCE  
7834 NC-210  
BUNNLEVEL, NC

B R DRAFTING & DESIGN LLC  
104 SOUTH WHITE STREET SUITE #210  
VAKE FOREST, NC 27587  
OH 40-705-8010 NC 919-635-5500  
info@brdpplans.com / brdpplans.com


**BR**




2

6

LAYOUT

SCALE: 1/4" = 1'-0"  
DRAWN BY: BENJAMIN ROGERS  
DATE: Monday, July 29, 2024

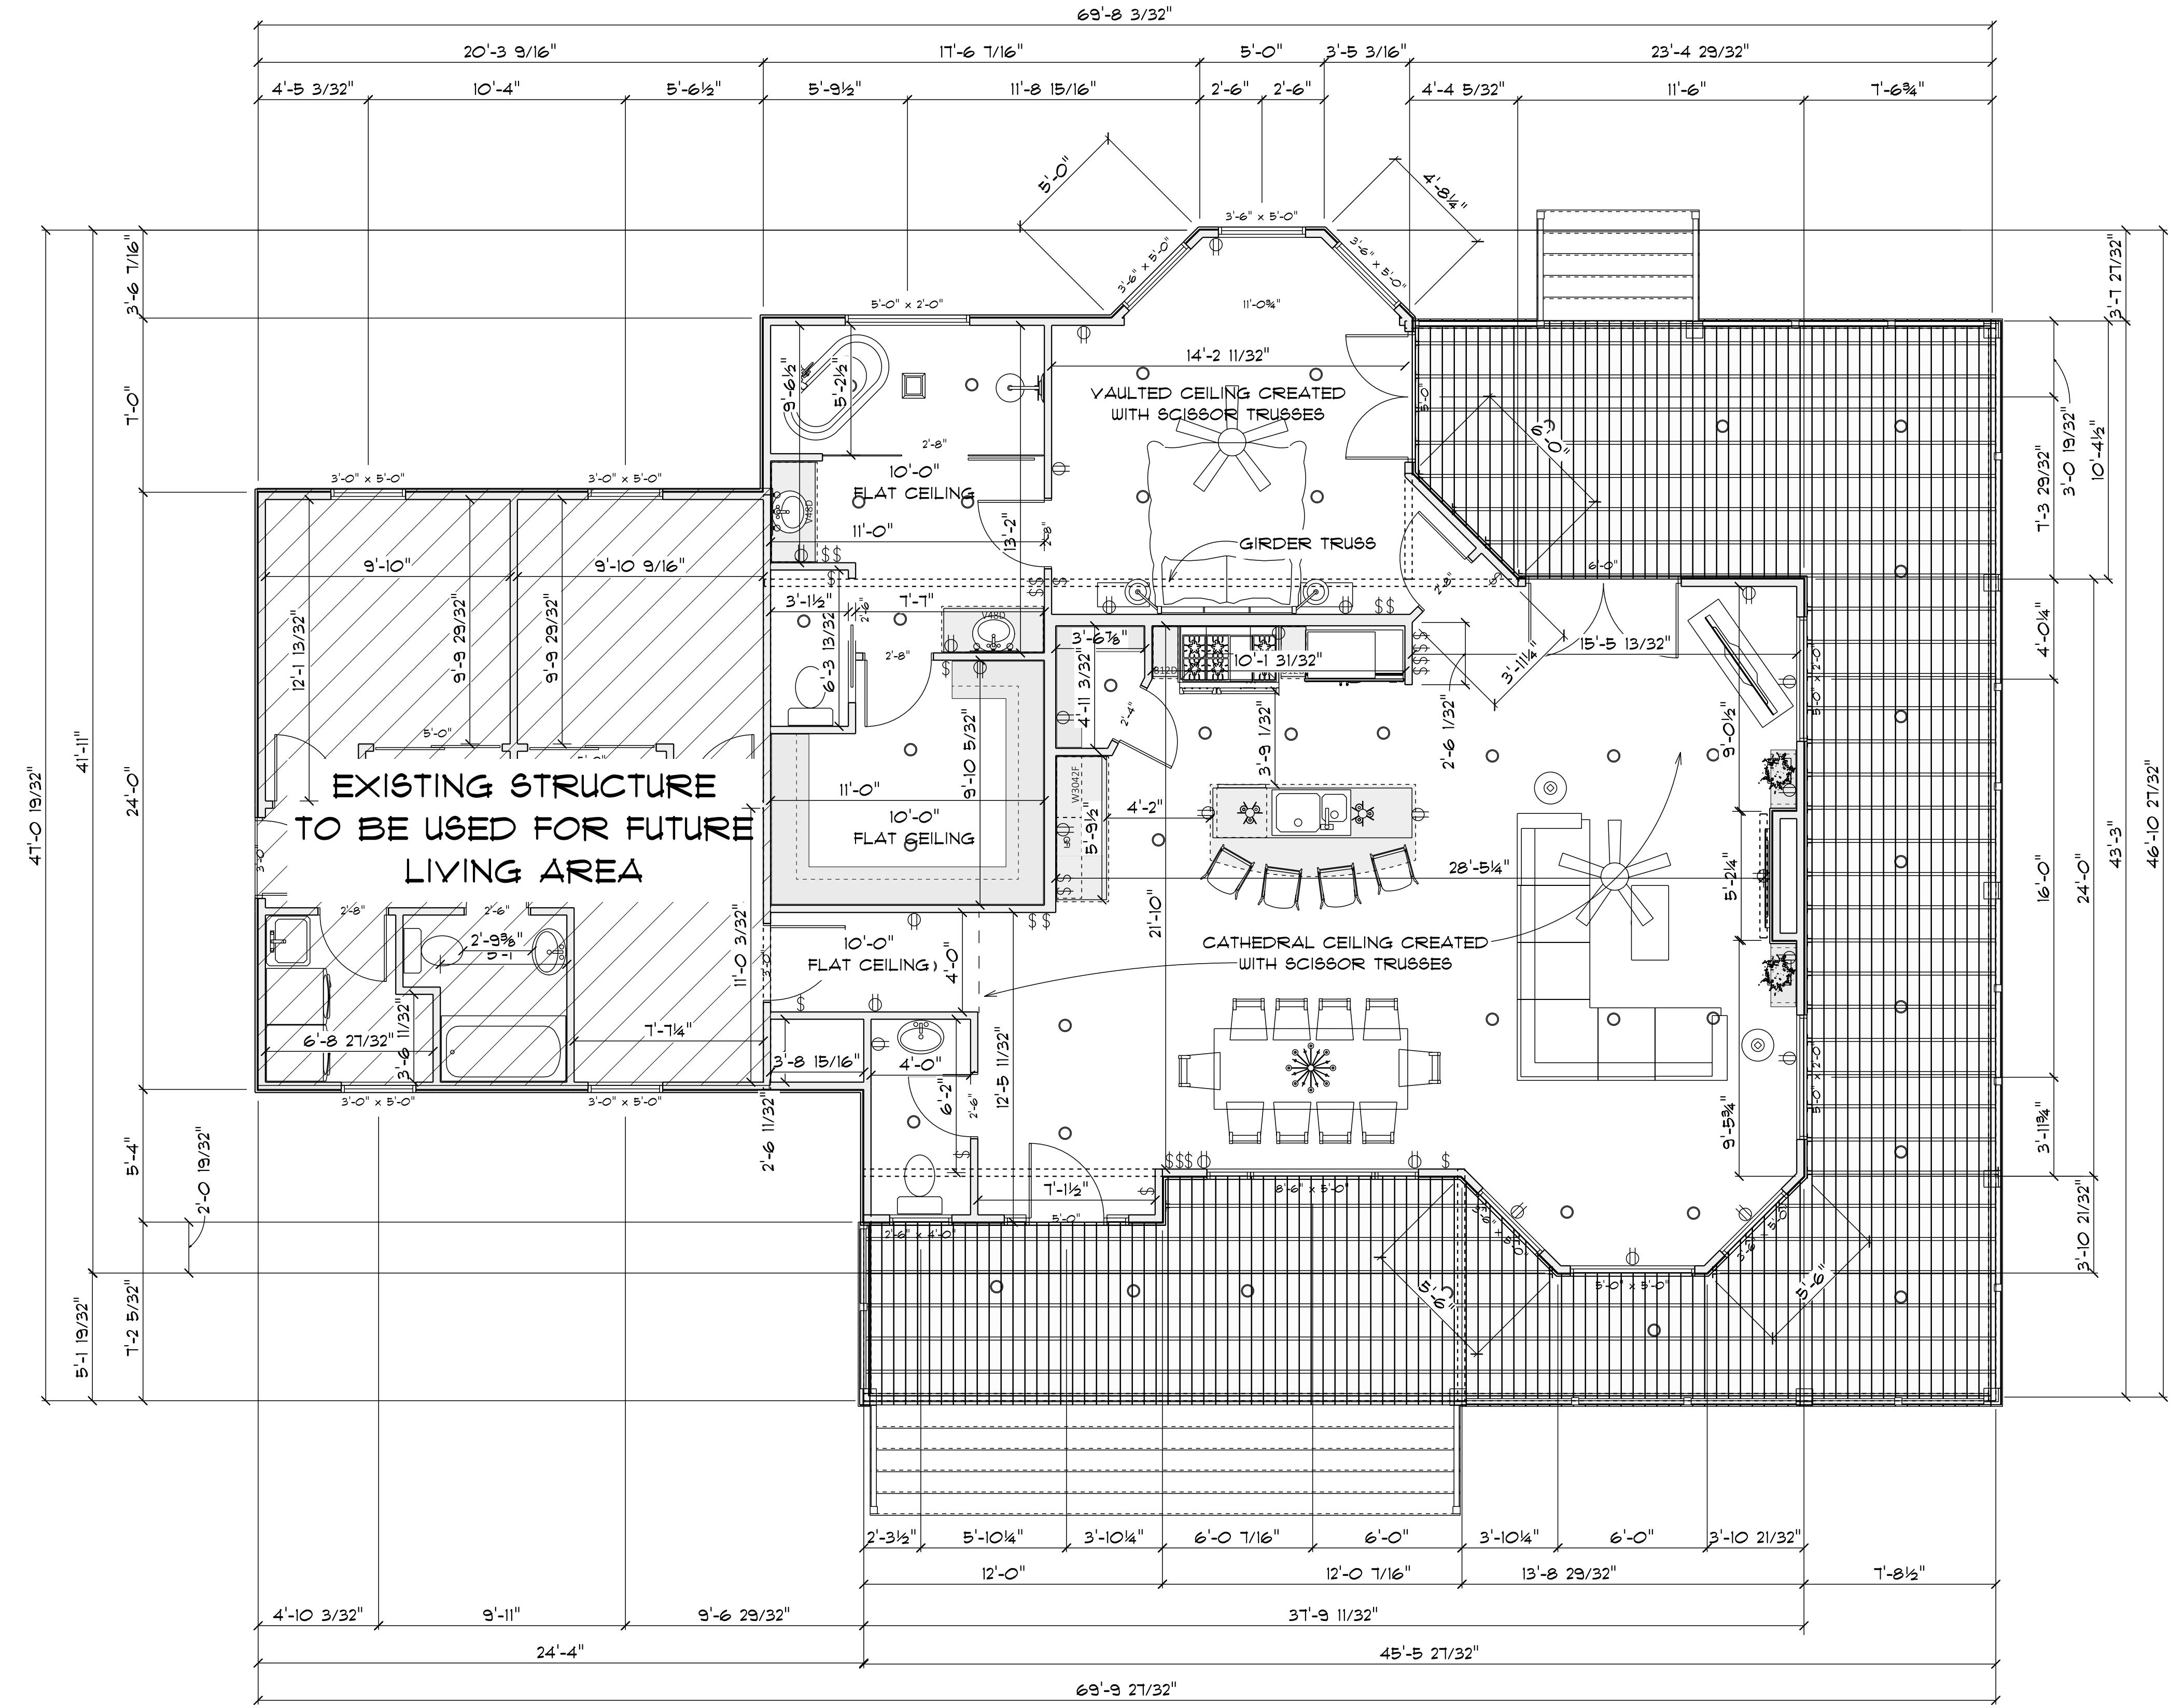

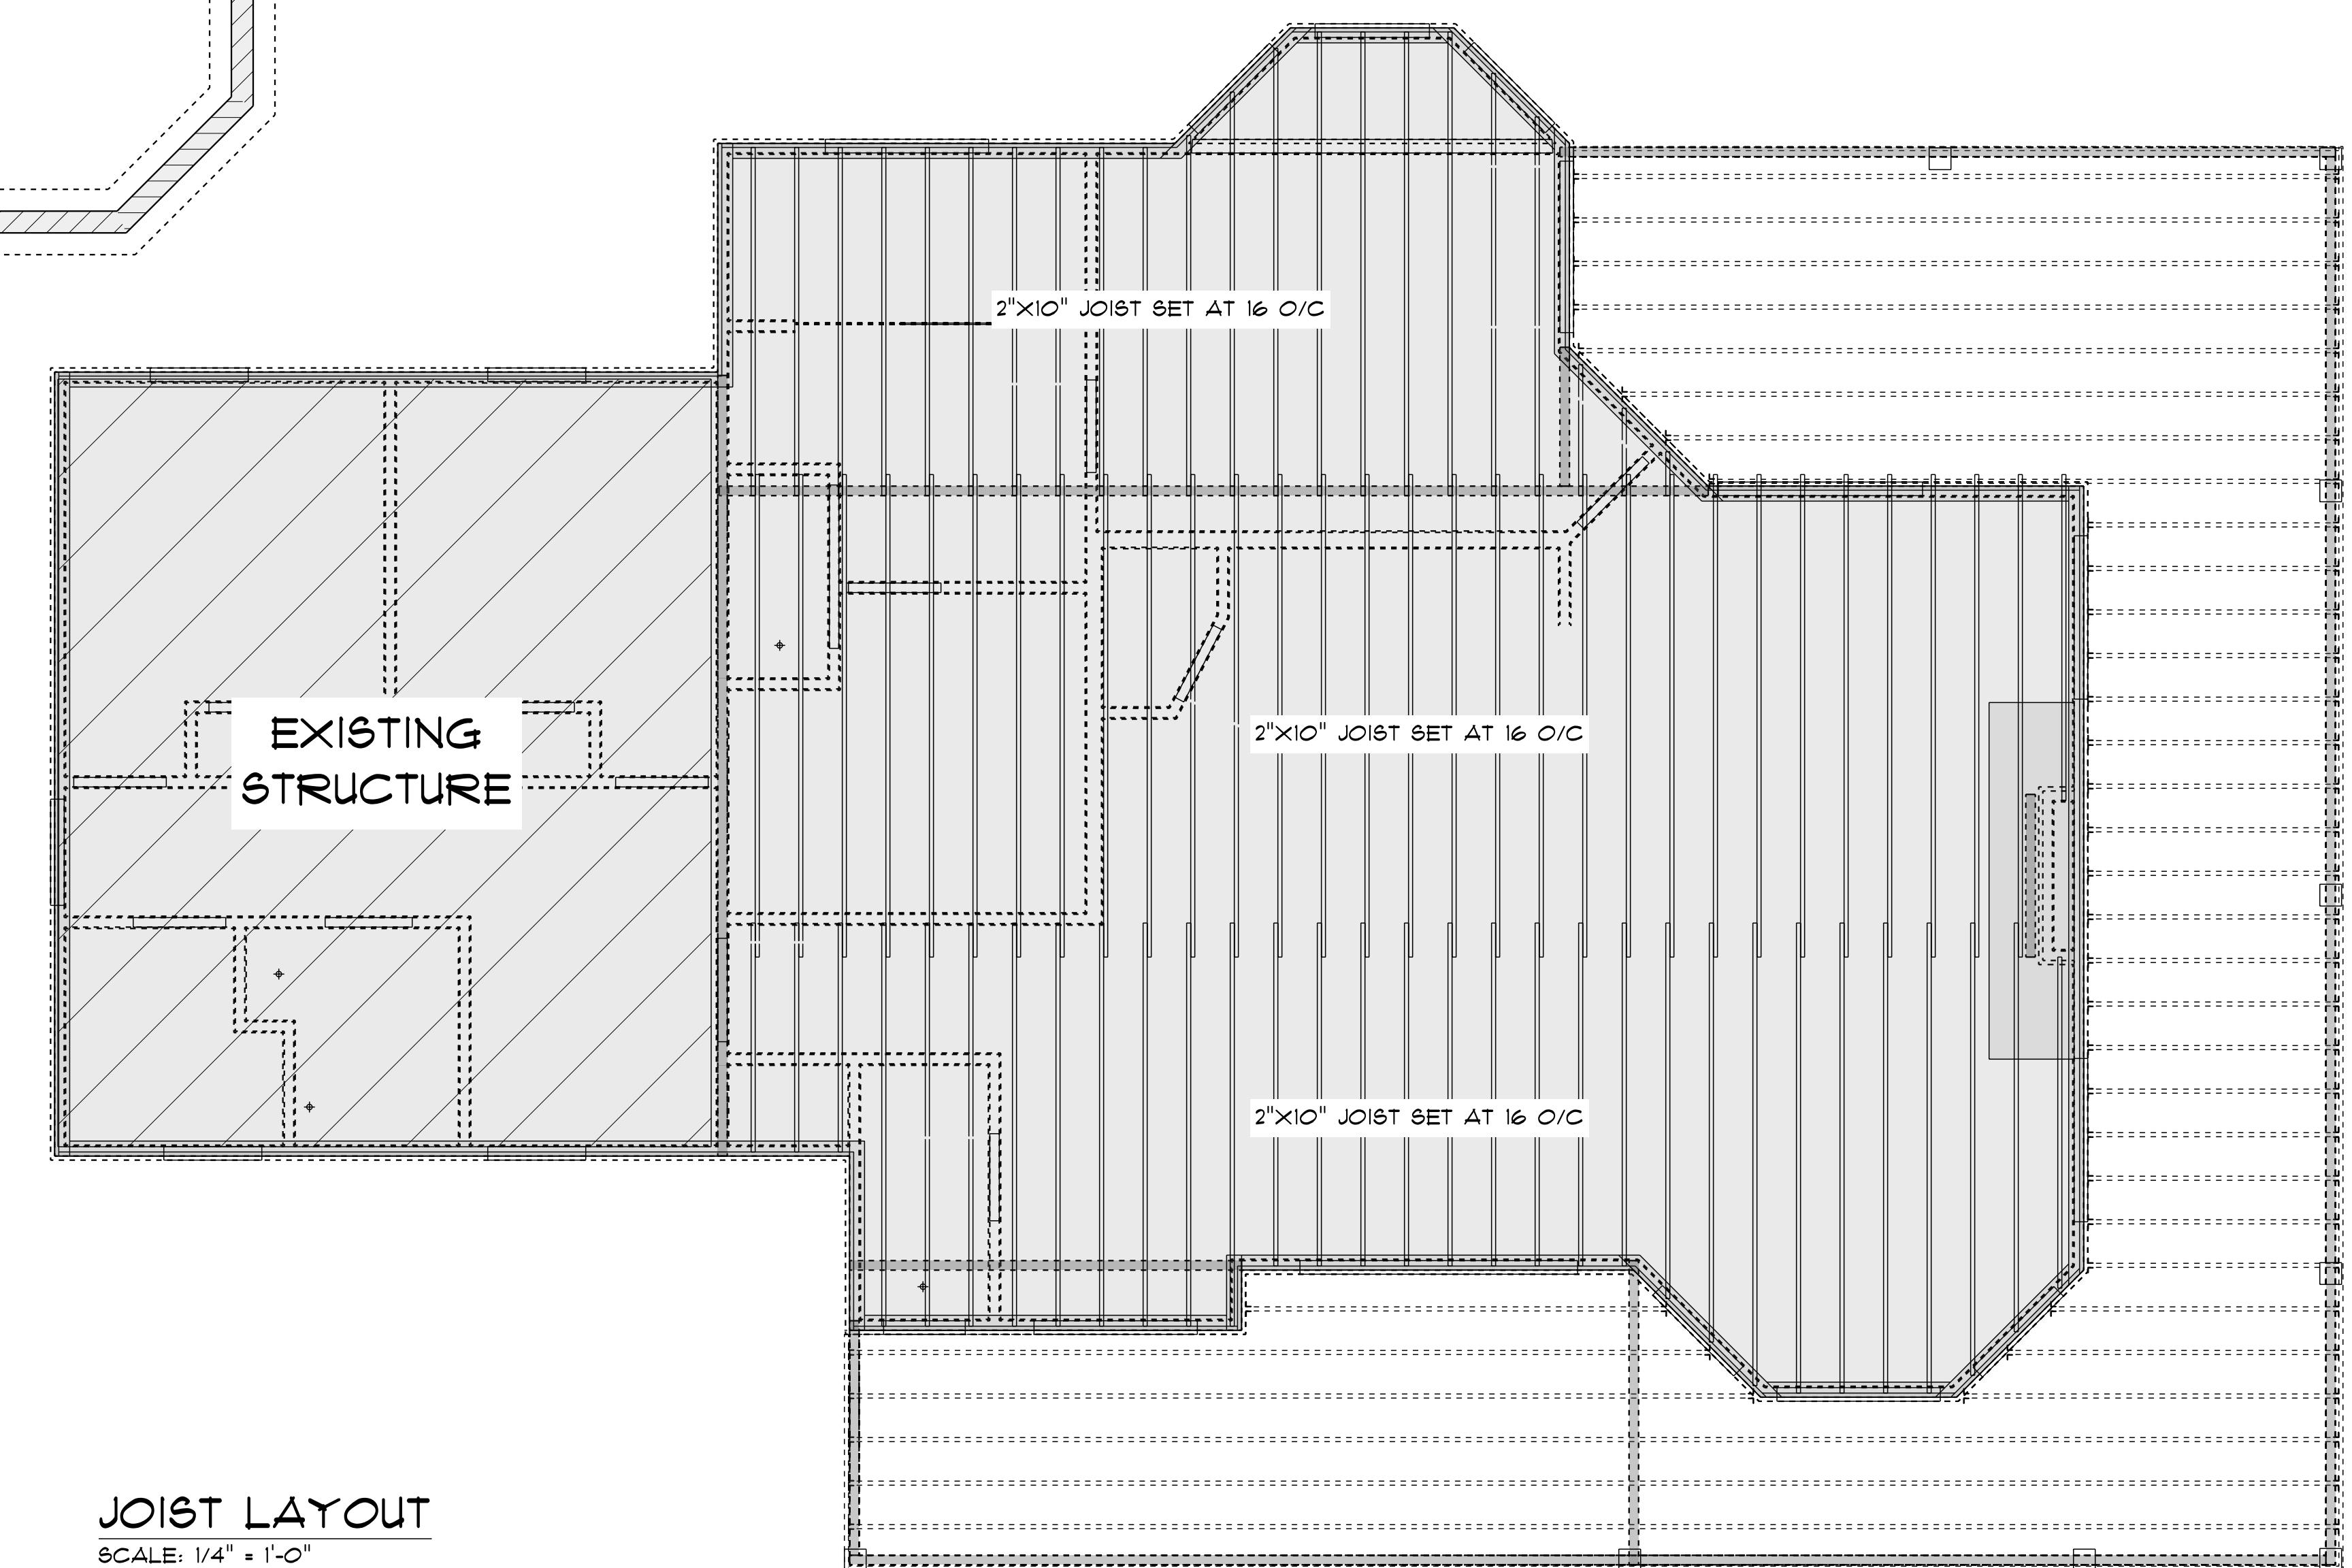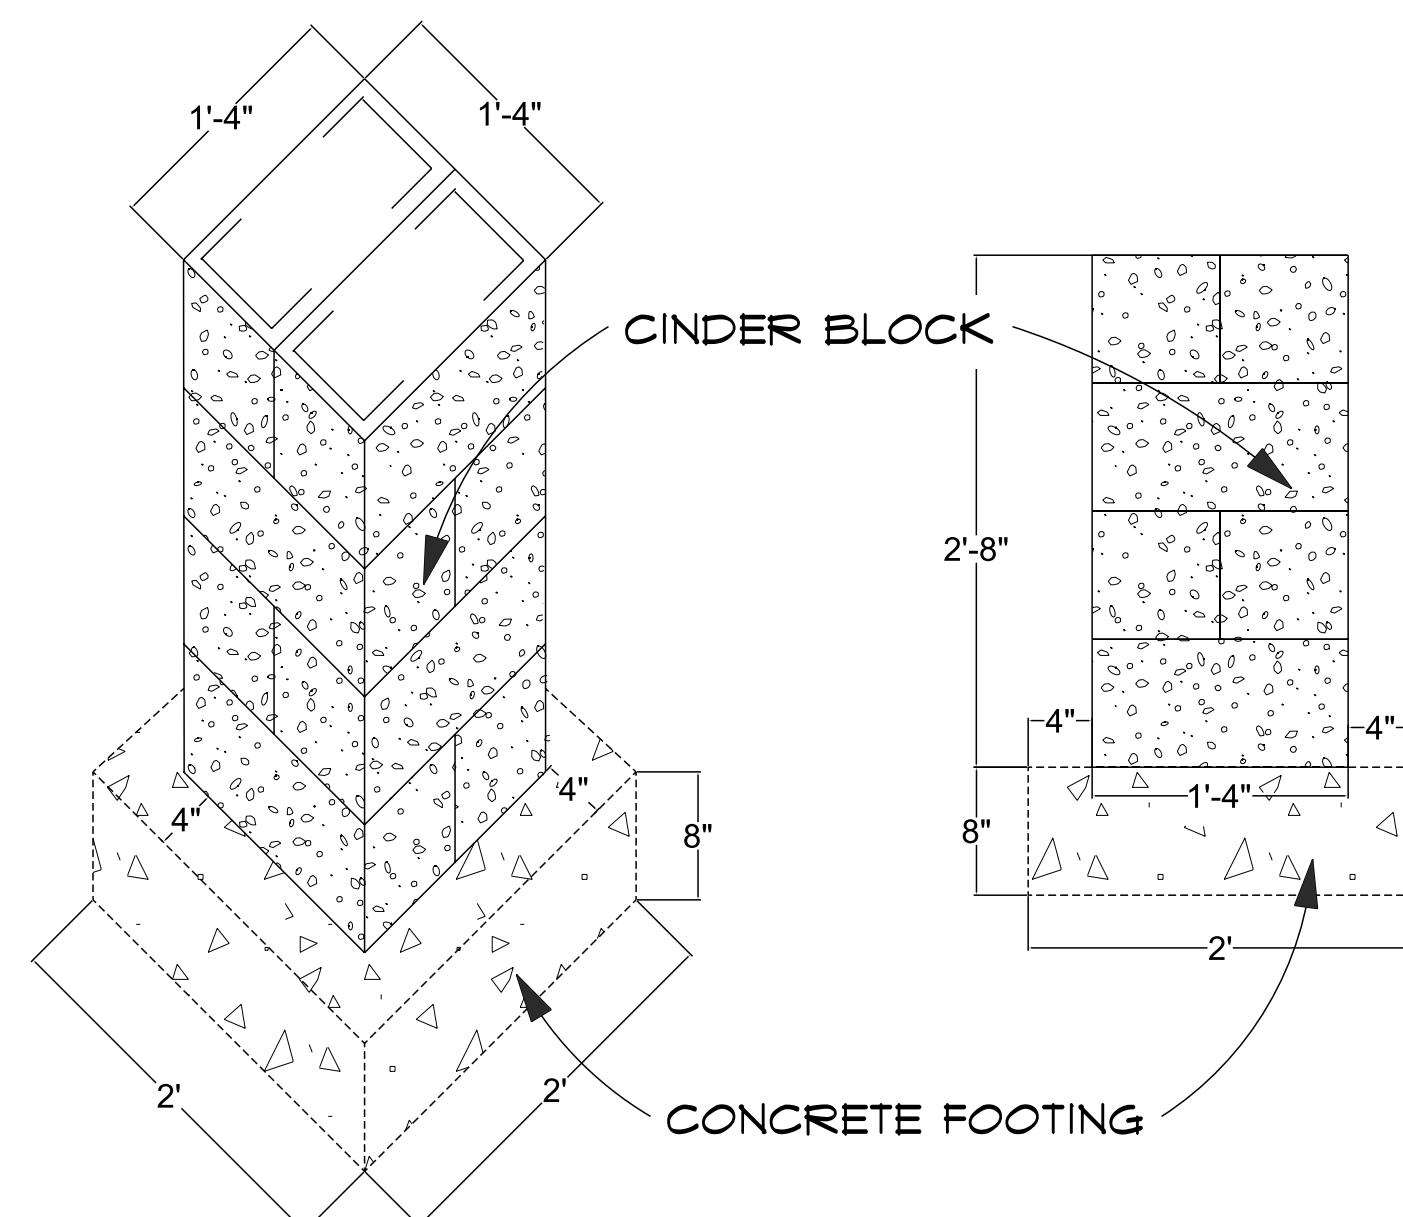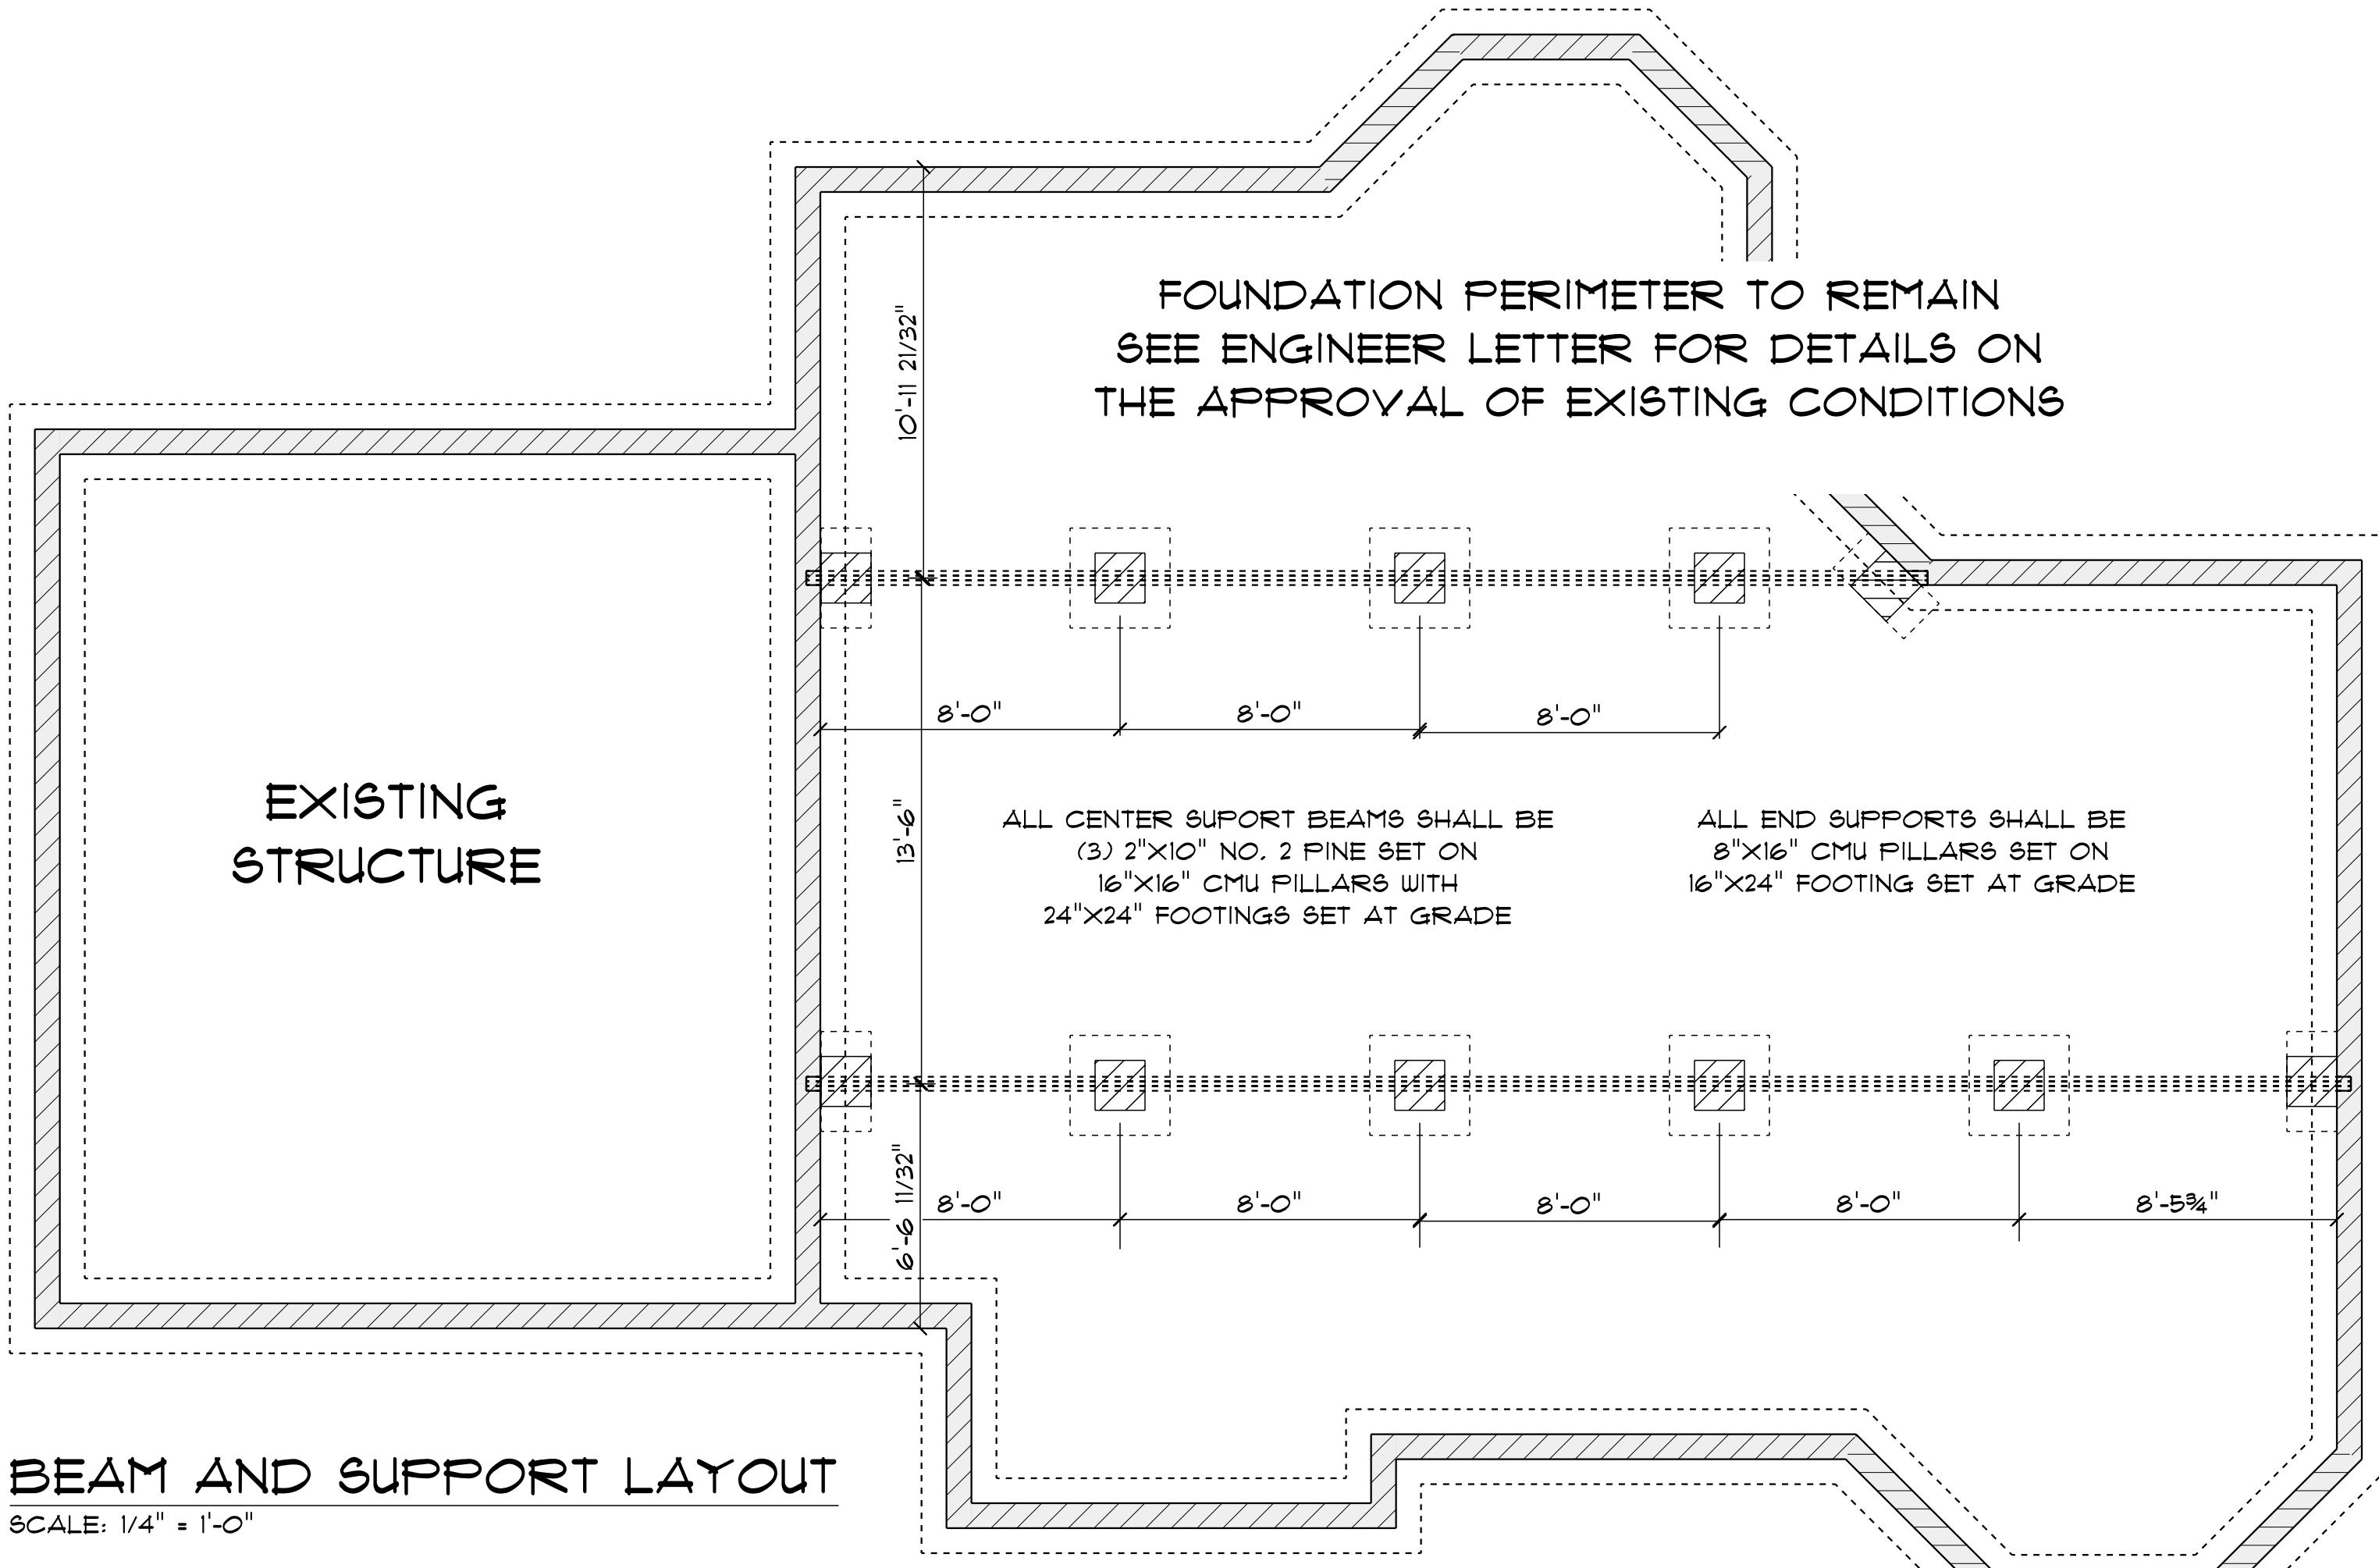

COPYRIGHT NOTICE:  
ALL DRAWING DEPICTED IN THESE DRAWINGS ARE DONE WITH  
THE EXPRESS PERMISSION OF THE CLIENT. B R DRAFTING AND  
DESIGN LLC RESERVES THE RIGHT TO MAKE COPIES, SELL OR  
DISTRIBUTE COPIES, PREPARE DERIVATIVE WORKS, AND  
PUBLICLY DISPLAY THE WORK AS THEY SEE FIT

**PRIVATE RESIDENCE**


B R DRAFTING & DESIGN LLC  
104 SOUTH WHITE STREET SUITE #210  
VAKE FOREST, NC 27587  
OH 40-705-8010 NC 919-635-5500  
info@brddplans.com / brddplans.com

3

6

LAYOUT CONT

SCALE: As Noted  
DRAWN BY: BENJAMIN ROGERS  
DATE: Monday, July 29, 2024

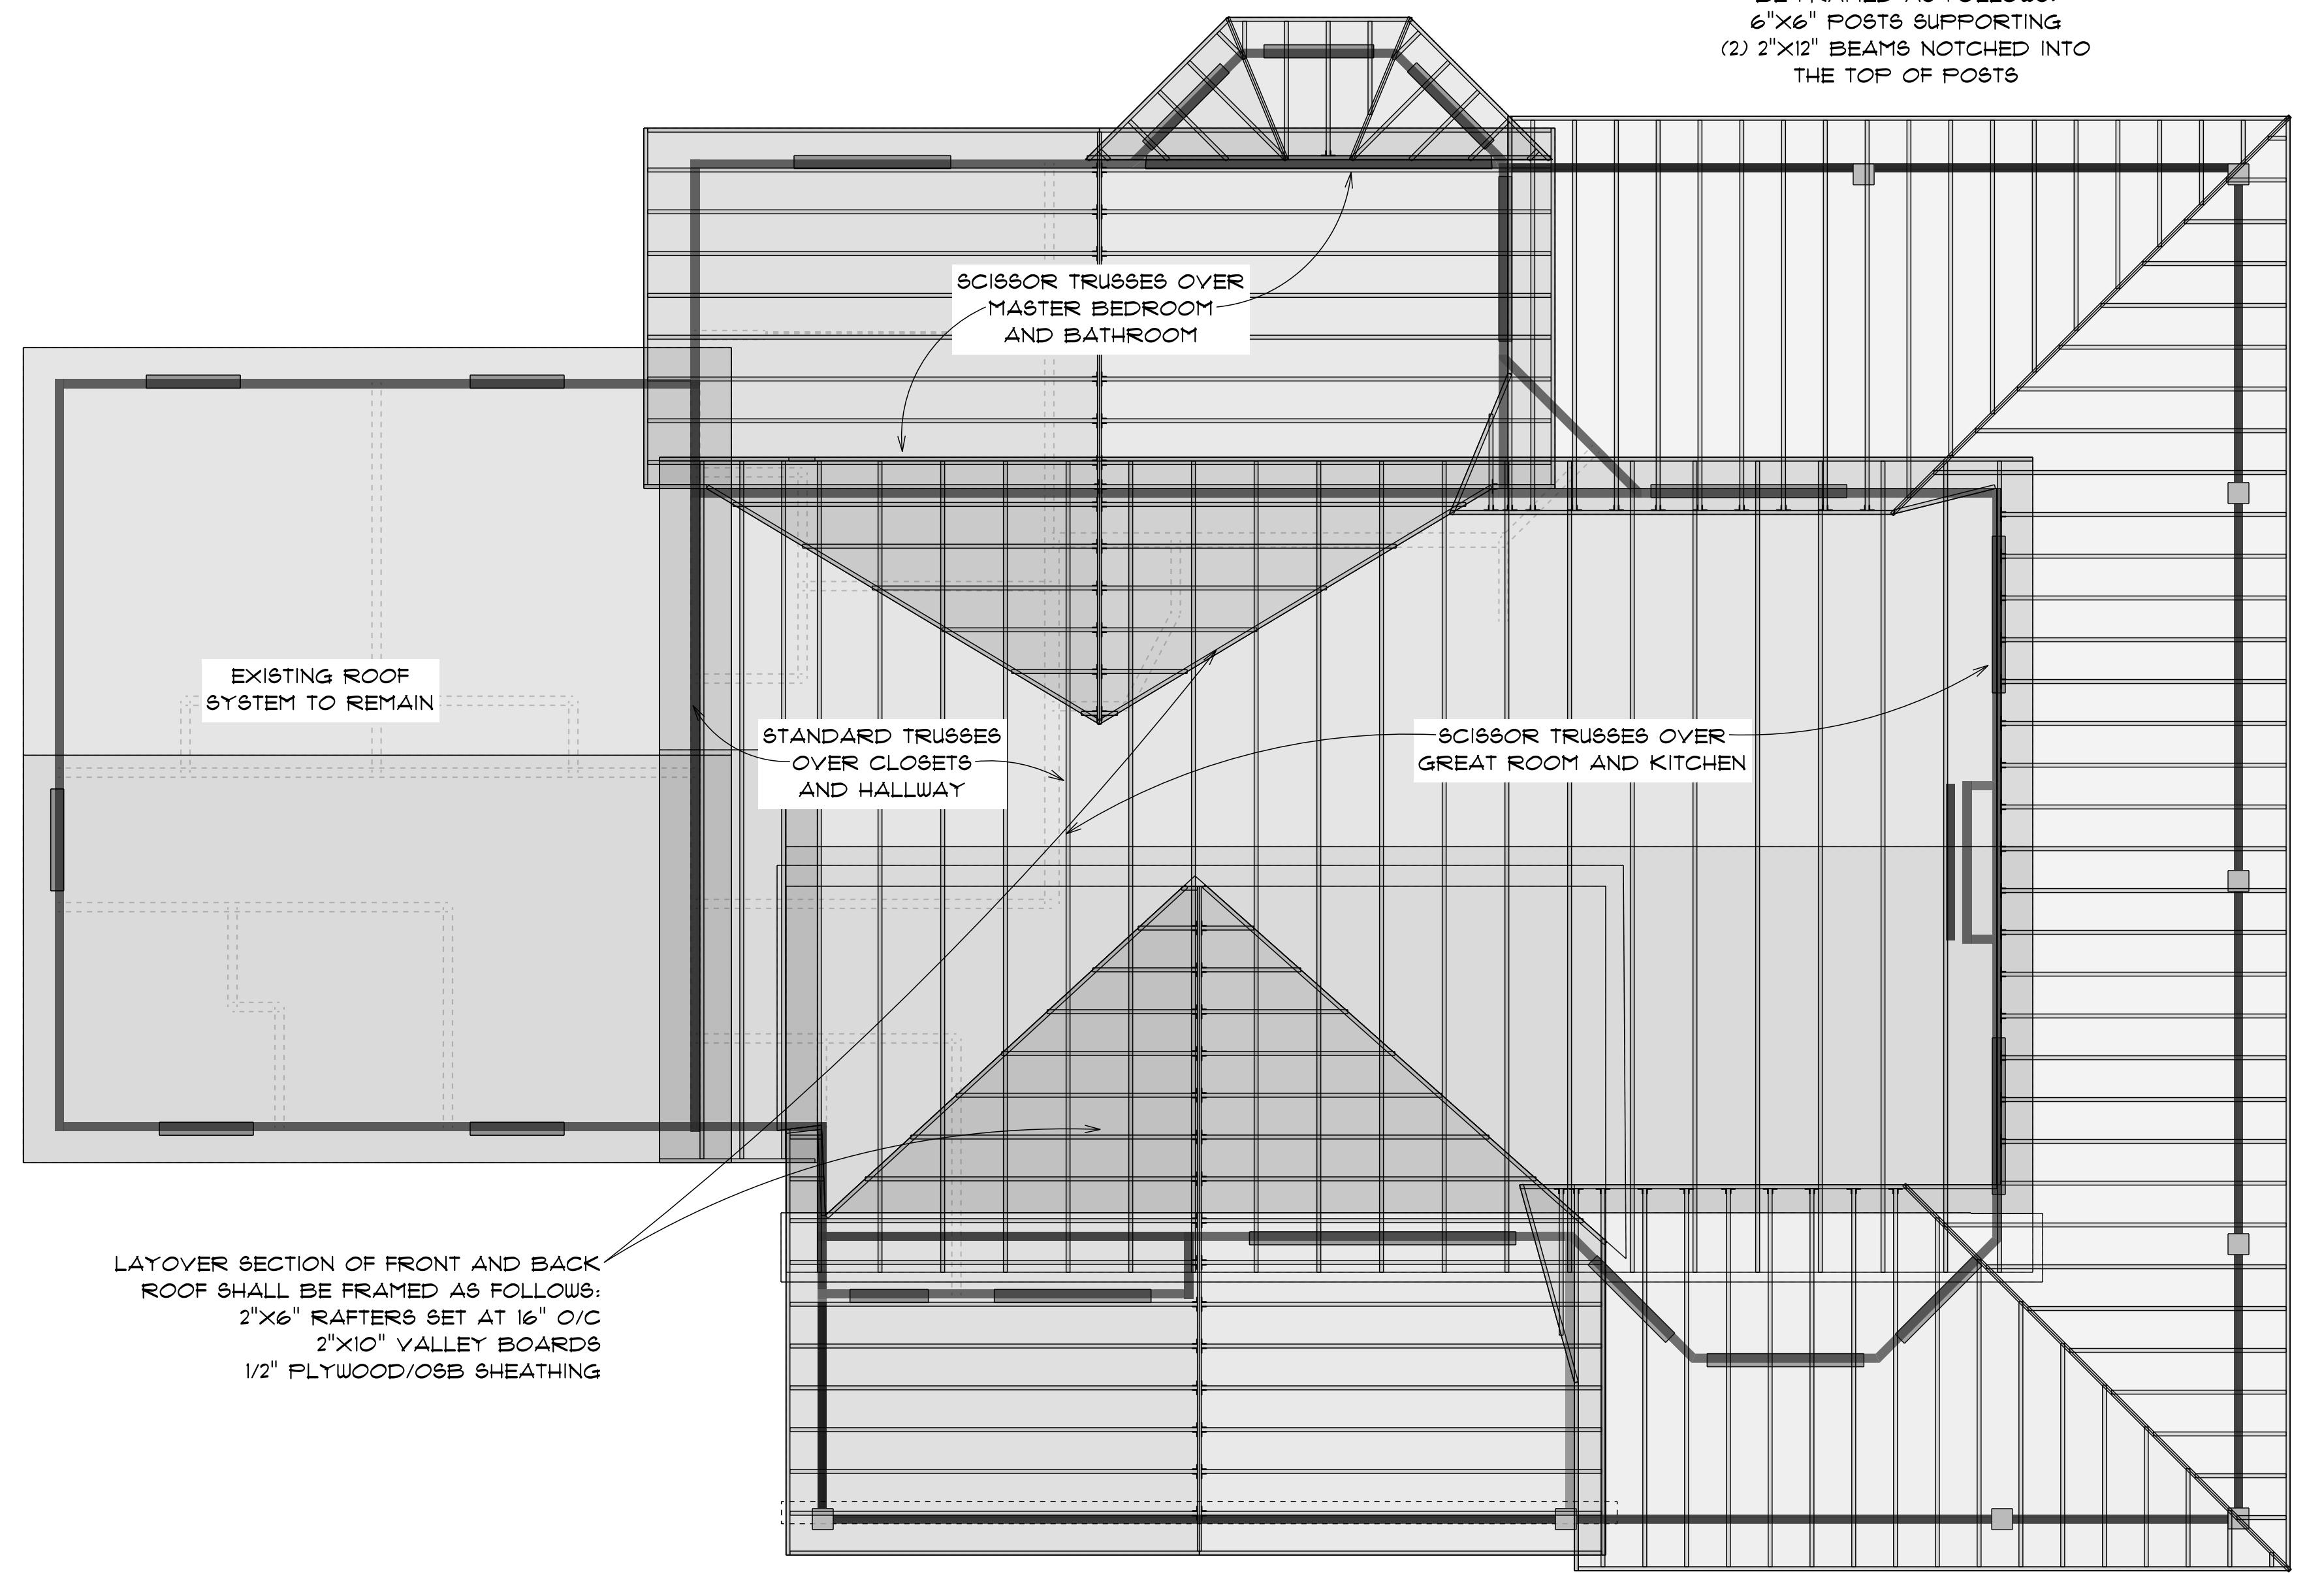

#### ROOF SYSTEM


SCALE: 1/4" = 1'-0"

#### DOOR SCHEDULE

PRODUCT CODE	SIZE	HINGE	REVERSED	COUNT
28X80 COLONIAL A 1	2'-4"	R	NO	1
30X80 COLONIAL A 1	2'-6"	R	NO	2
30X80 COLONIAL POCKET 1	2'-6"	N	NO	1
32X80 COLONIAL A 1	2'-8"	L	NO	2
32X80 COLONIAL A 1	2'-8"	R	NO	4
32X80 GLASS SLIDING (SHOWER DOOR)	2'-8"	L	NO	1
36X80 COLONIAL A 1	3'-0"	L	NO	1
60X96 LH ENTRY - 2 SL	5'-0"	L	NA	1
72X96 GLASS FRENCH DOOR	6'-0"	LR	NO	1
60X96 GLASS FRENCH DOOR	5'-0"	LR	NO	1


#### WINDOW SCHEDULE

PRODUCT CODE	SIZE	COUNT
30X48 CASEMENT	12'-6" x 4'-0"	1
36X60 CASEMENT	13'-0" x 5'-0"	4
42X60 CASEMENT	13'-6" x 5'-0"	5
60x24 AWNING	5'-0" x 2'-0"	2
60X24 TRANSOM	5'-0" x 2'-0"	1
60X60 CASEMENT	15'-0" x 5'-0"	1
102X60 PICTURE 3	8'-6" x 5'-0"	1

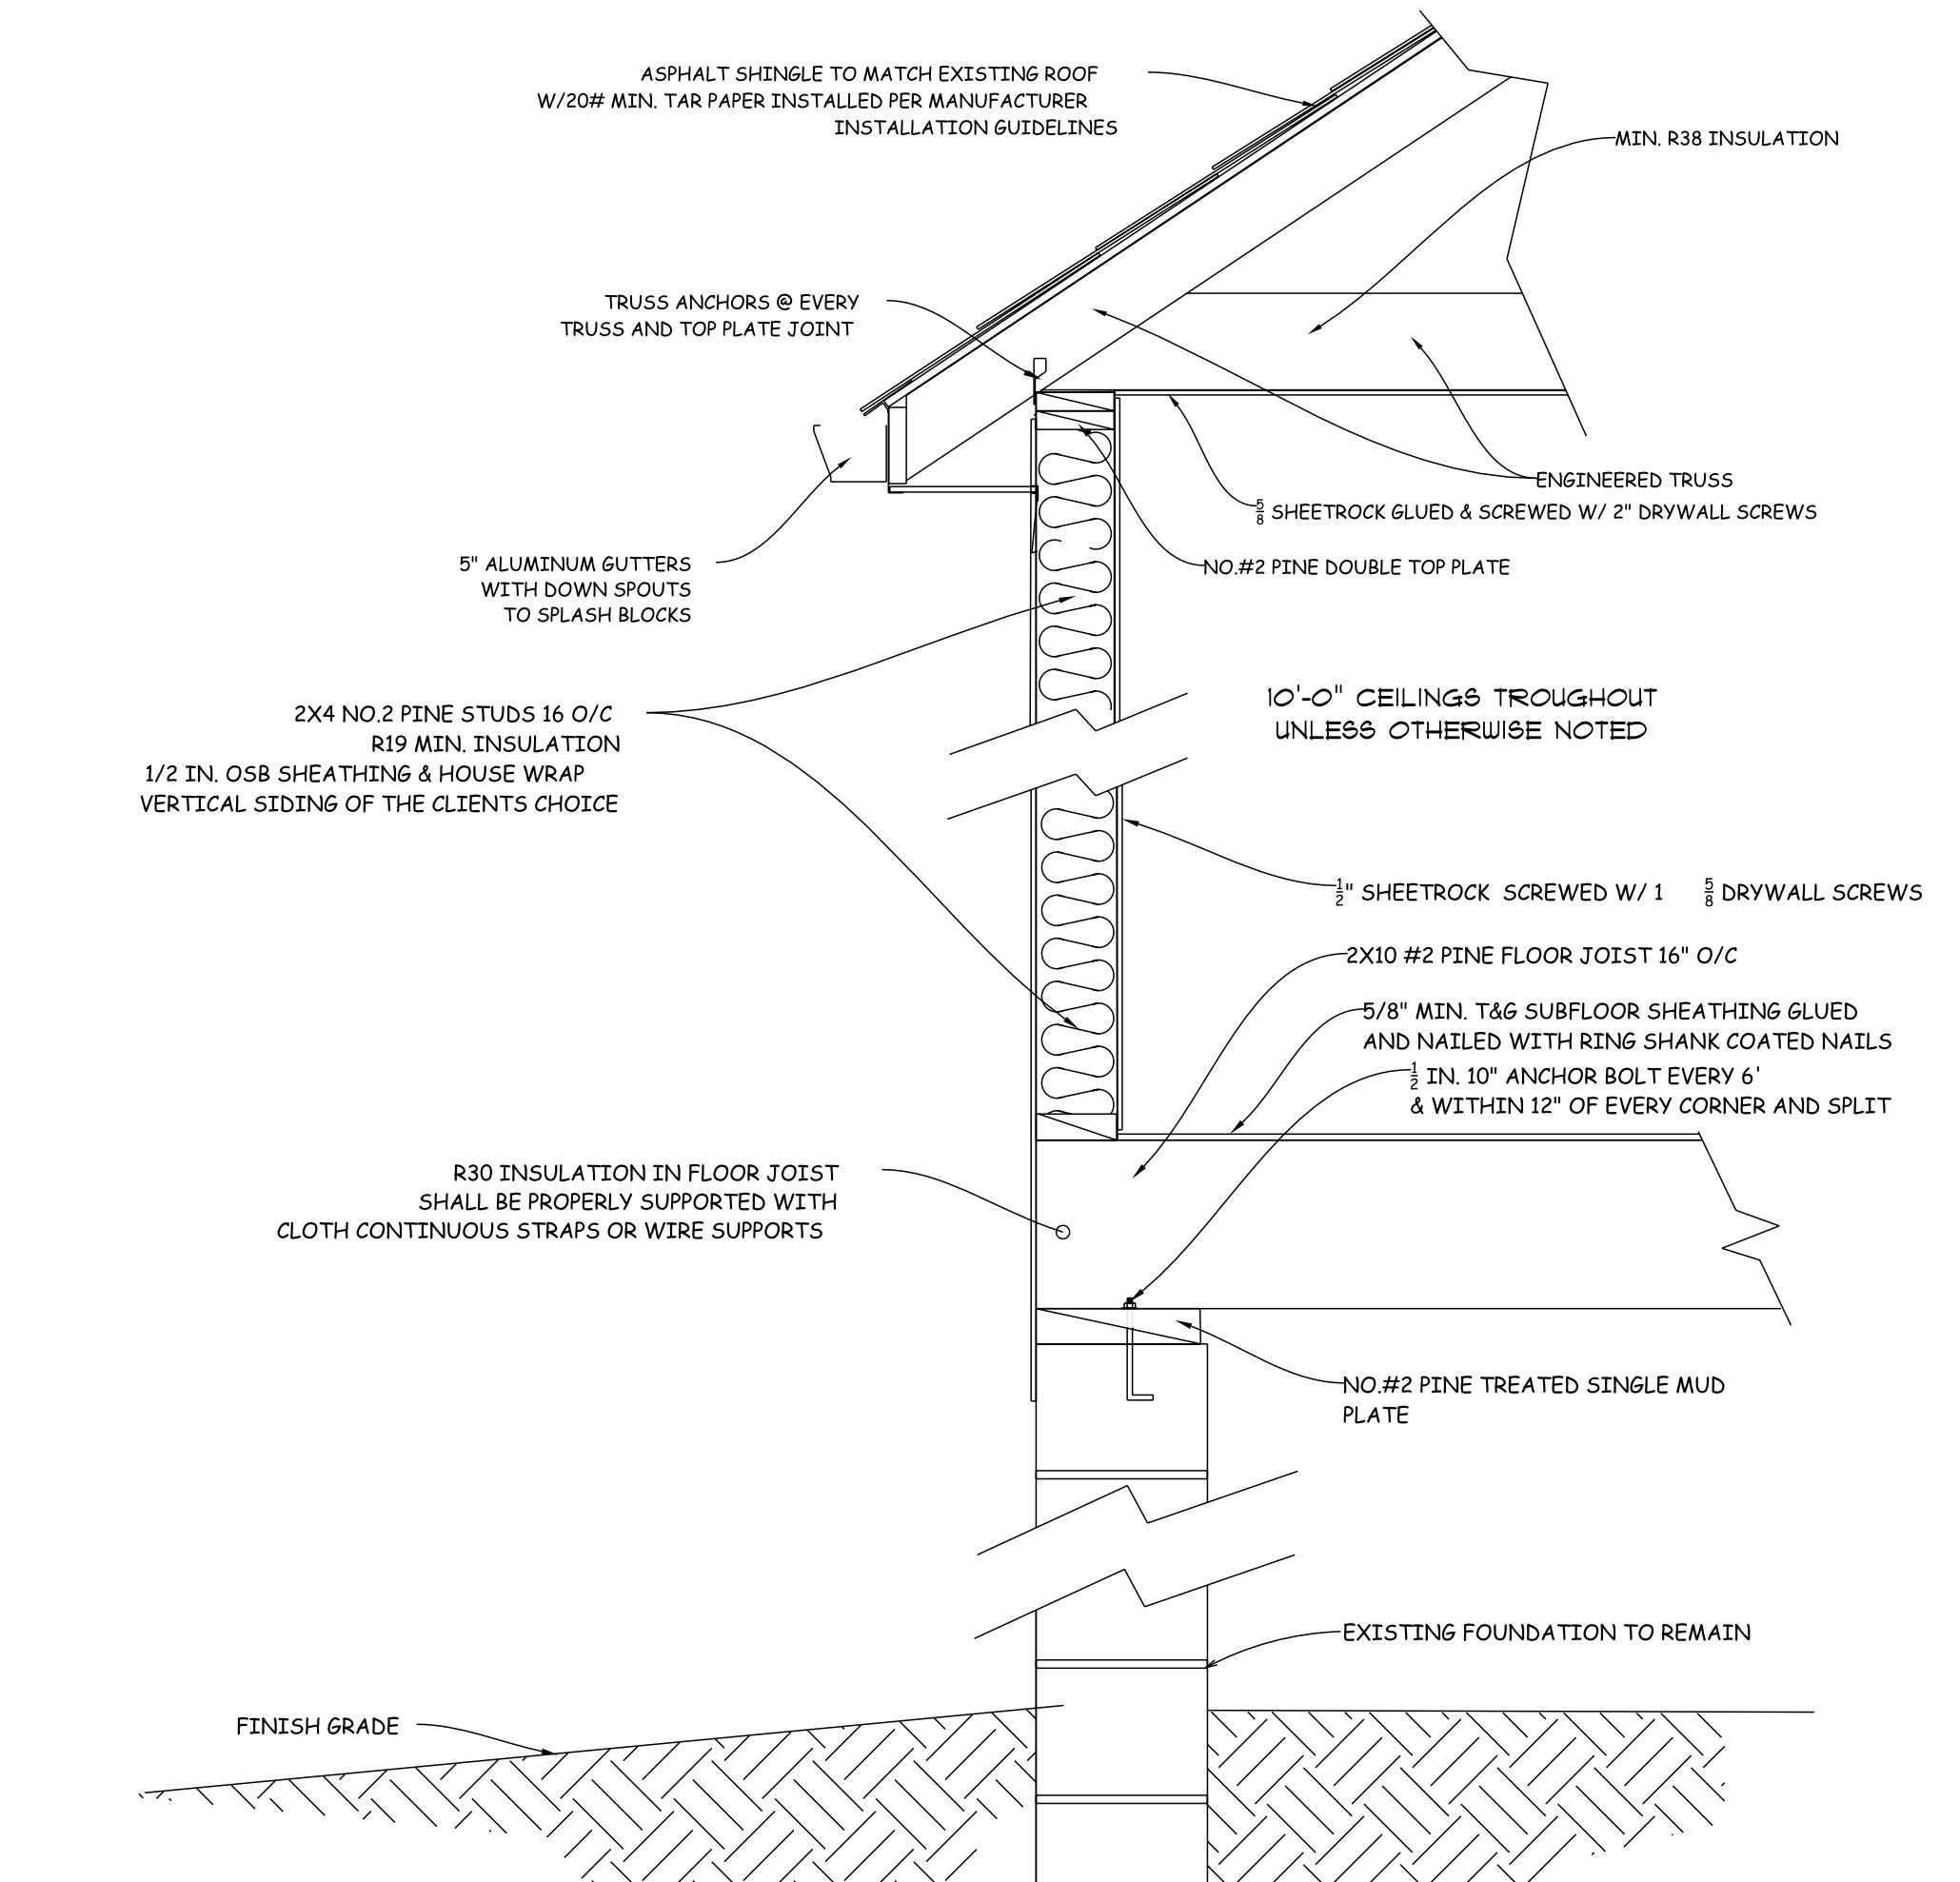

#### WALL DETAIL

SCALE: NOT TO SCALE

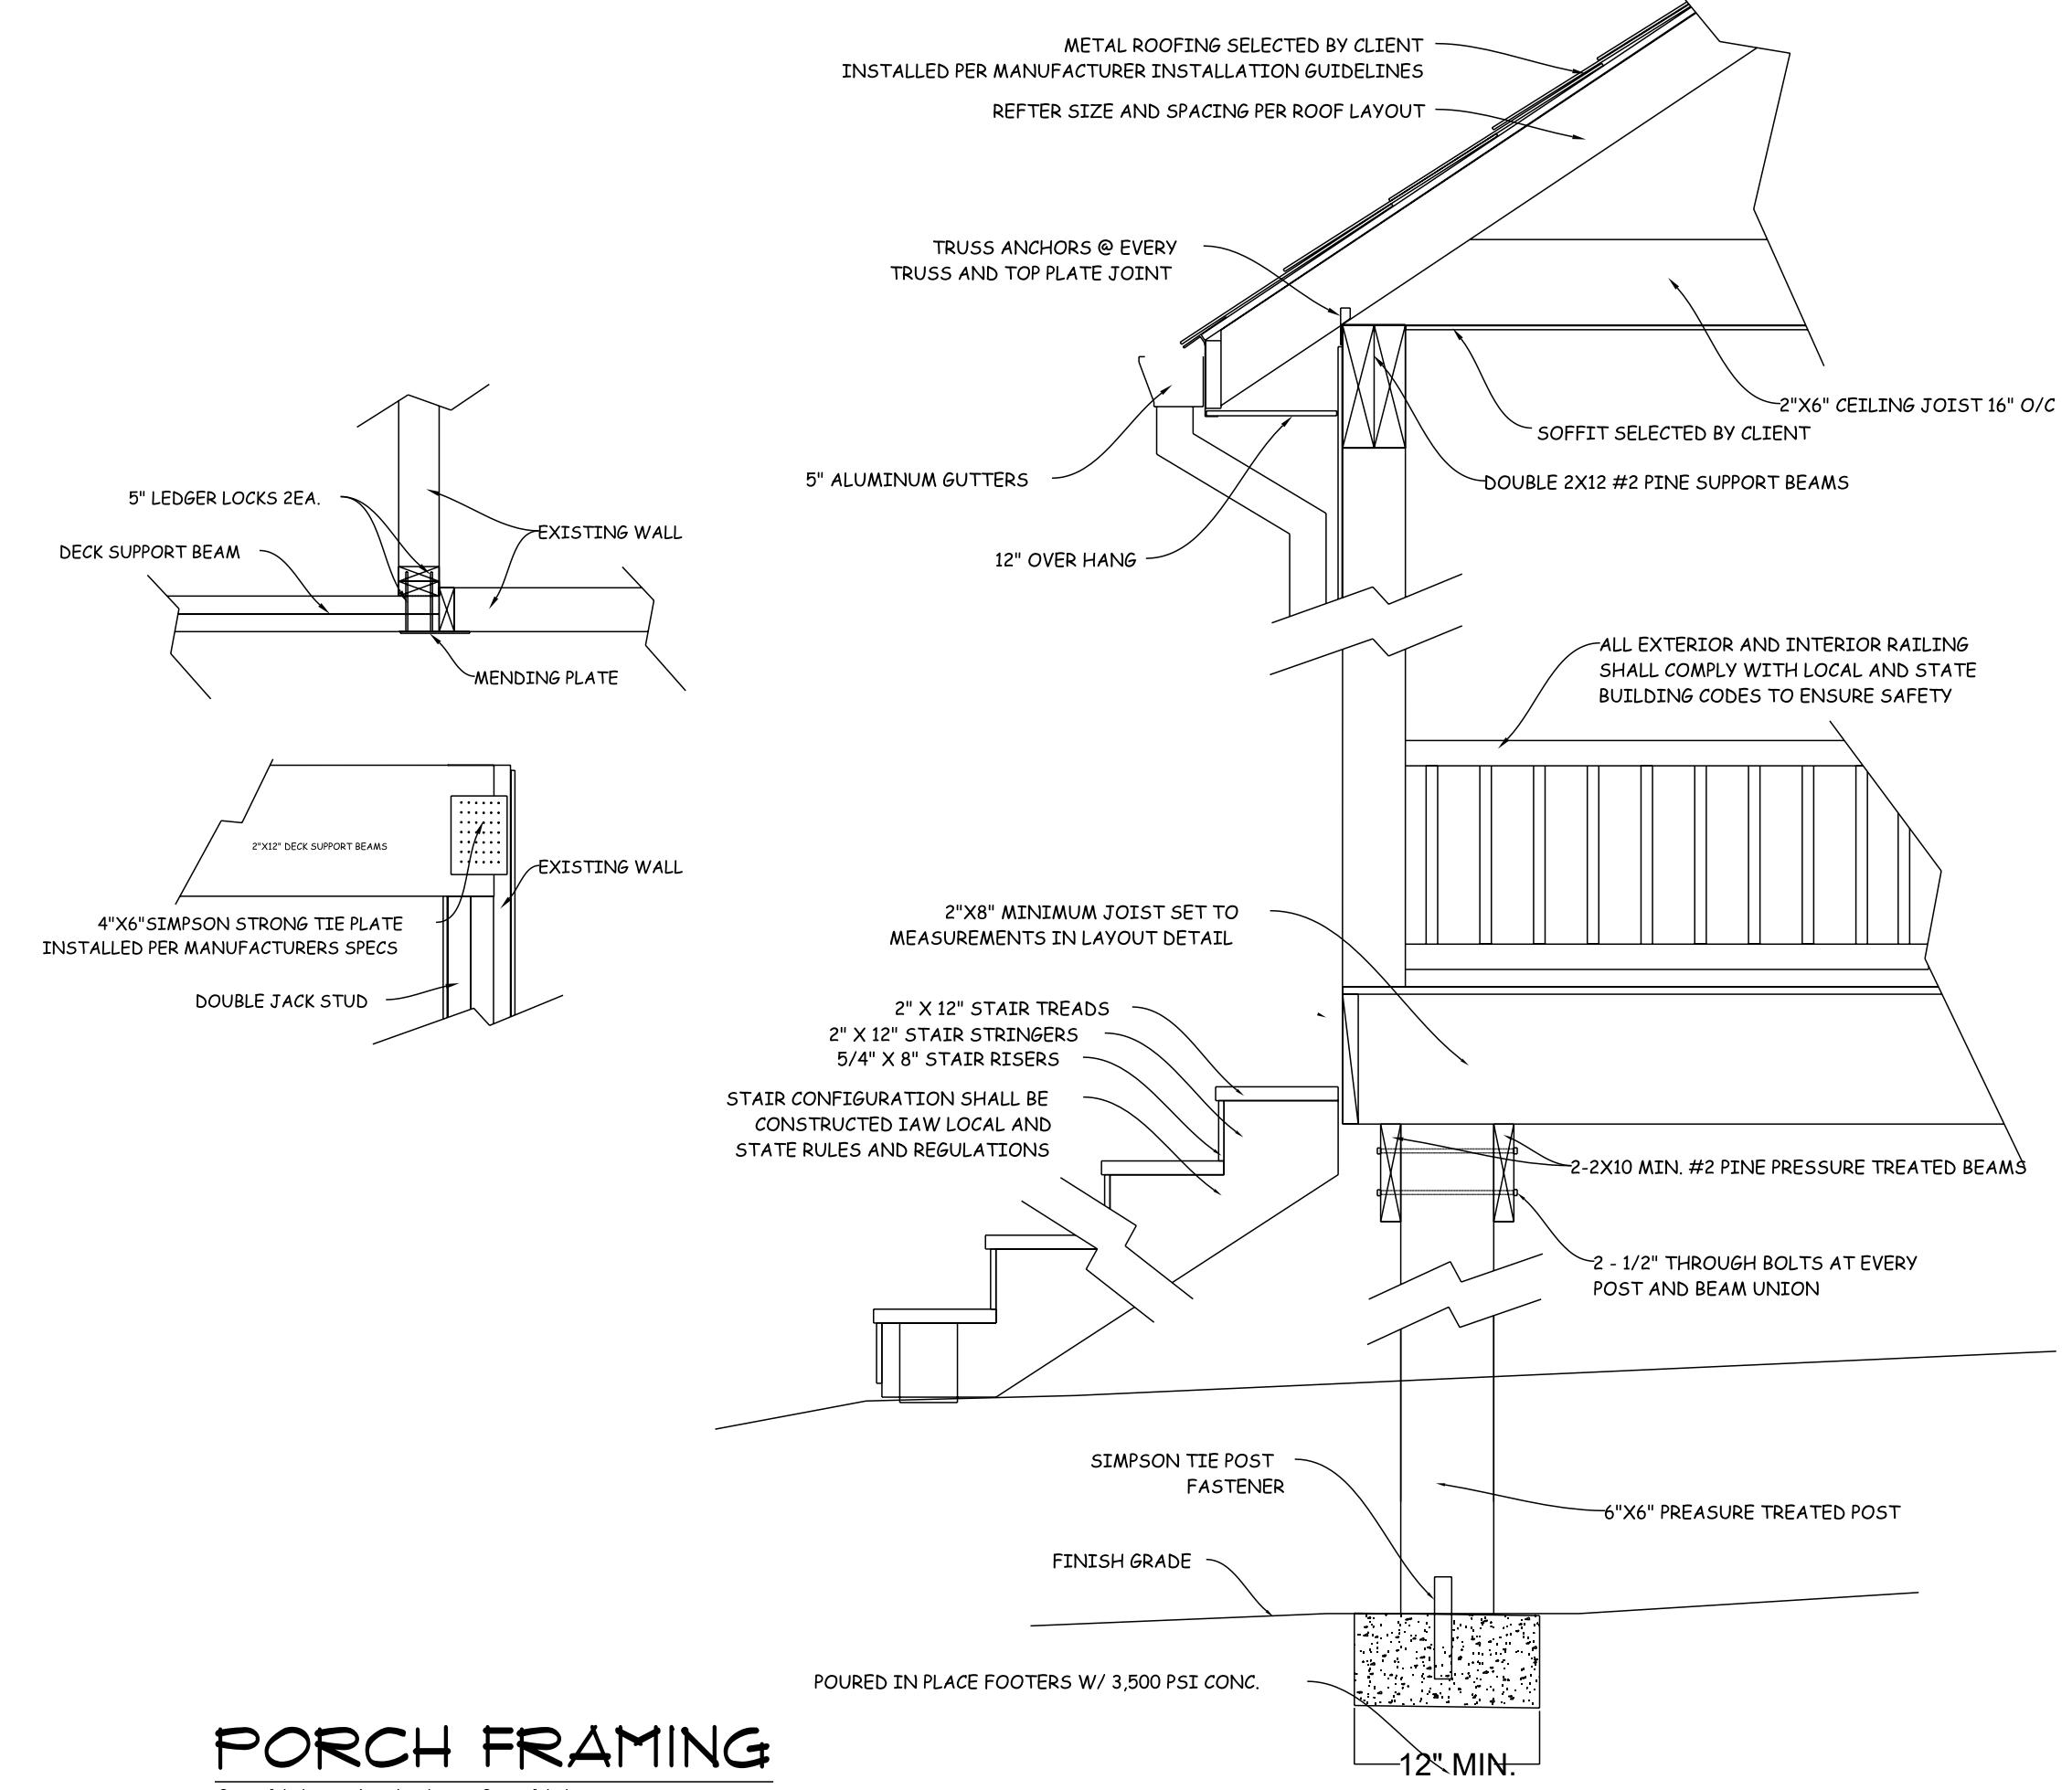

#### PORCH FRAMING



SCALE: NOT TO SCALE


COPYRIGHT NOTICE:  
ALL DRAFTING DEFICITED IN THESE DRAWINGS ARE DONE WITH  
THE EXPRESS PERMISSION OF THE CLIENT. B R DRAFTING AND  
DESIGN LLC RESERVES THE RIGHT TO MAKE COPIES, SELL OR  
DISTRIBUTE COPIES, PREPARE DERIVATIVE WORKS, AND  
PUBLICLY DISPLAY THE WORK AS THEY SEE FIT

PRIVATE RESIDENCE  
7834 NC-210  
BUNNLEVEL, NC

B R DRAFTING & DESIGN LLC  
104 SOUTH WHITE STREET SUITE #210  
VAKE FOREST, NC 27587  
OH 440-705-8010 NC 919-635-5500  
info@brddplans.com / brddplans.com

5 / 6  
3D RENDER

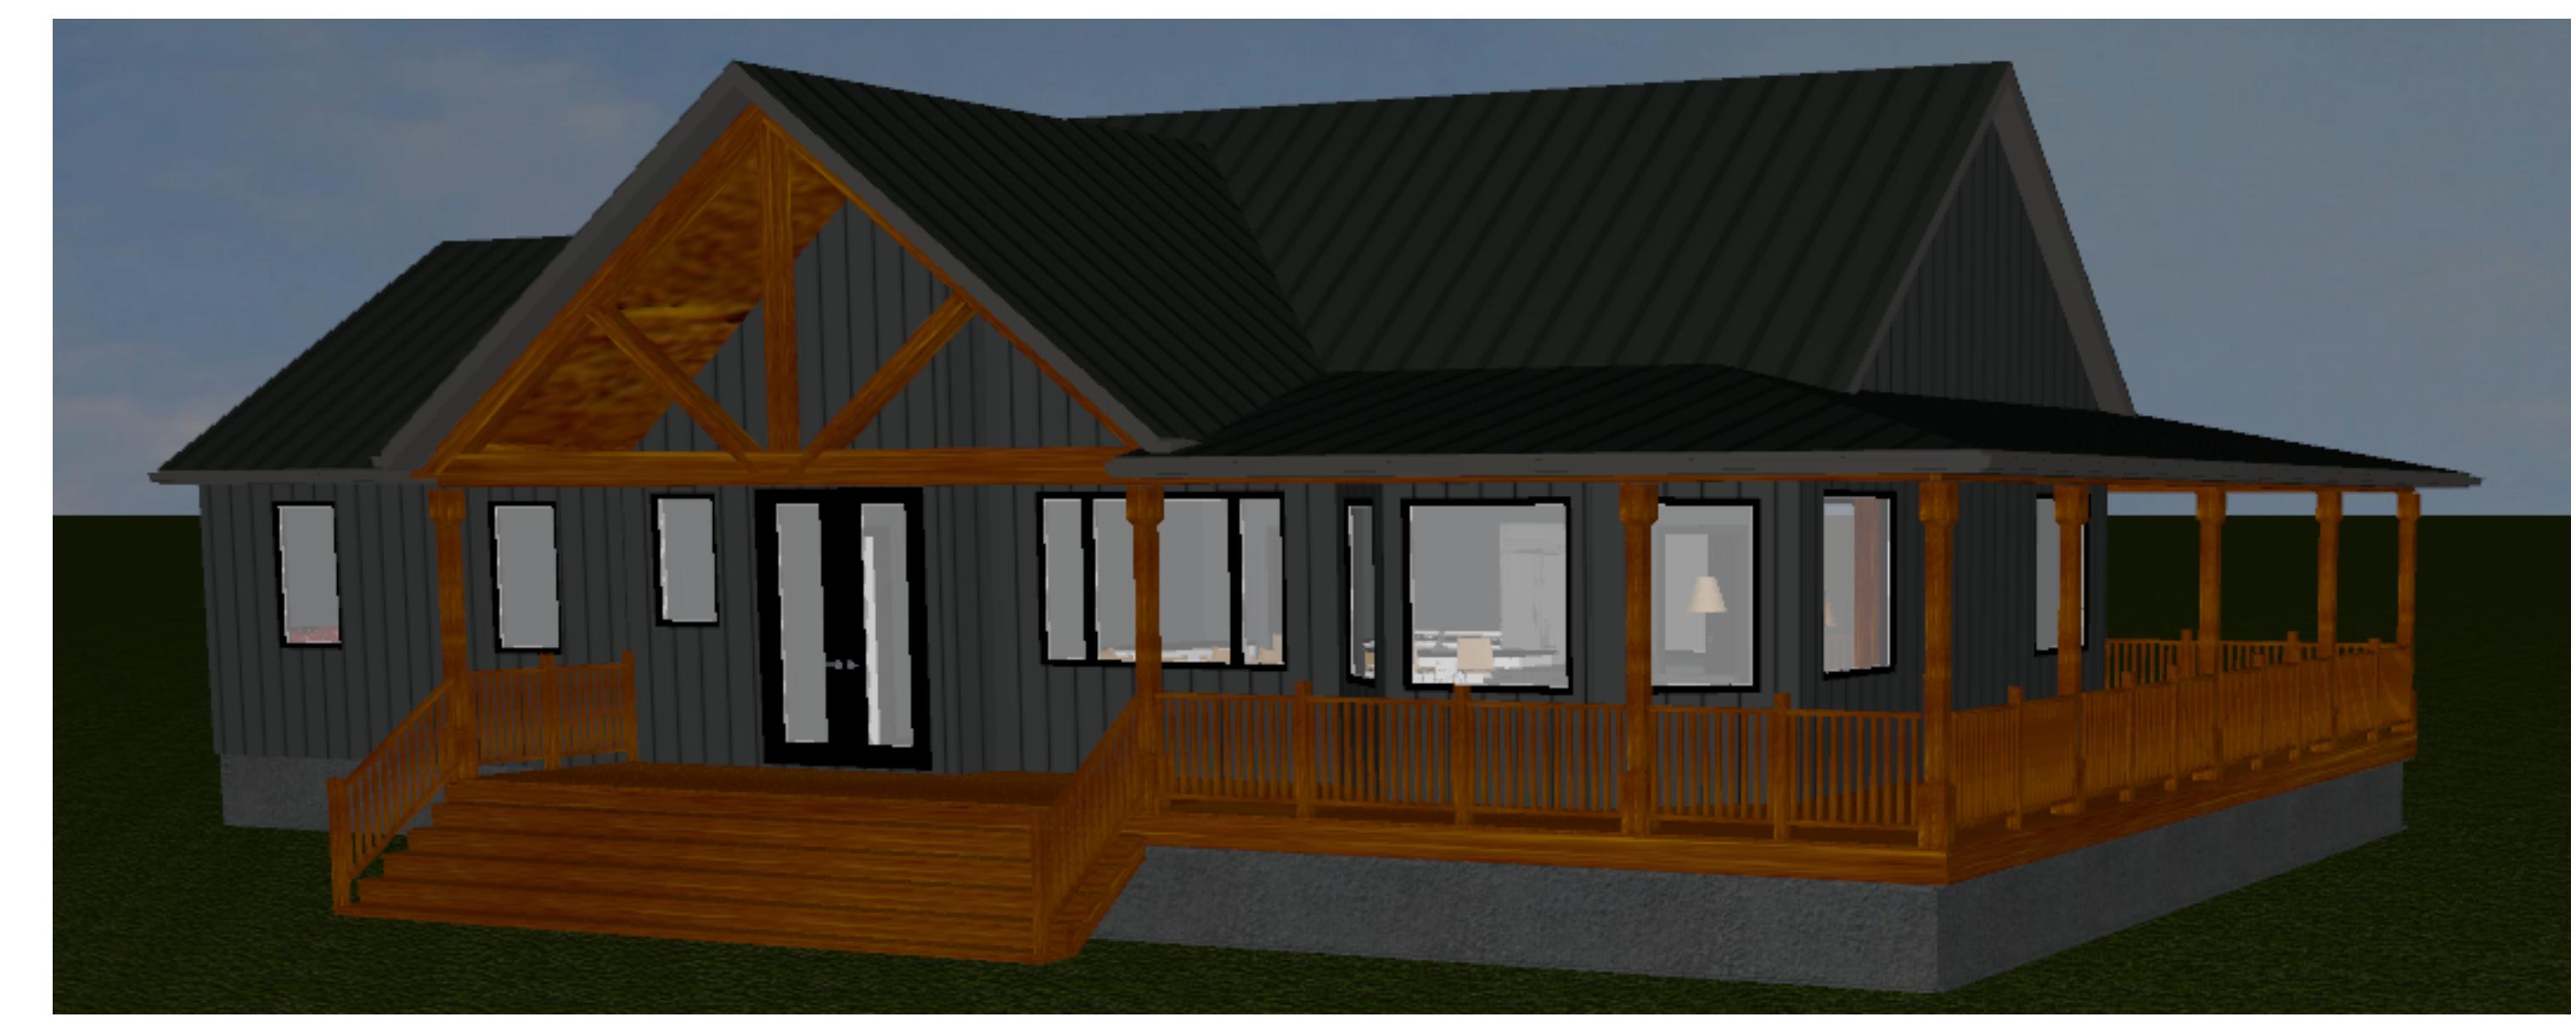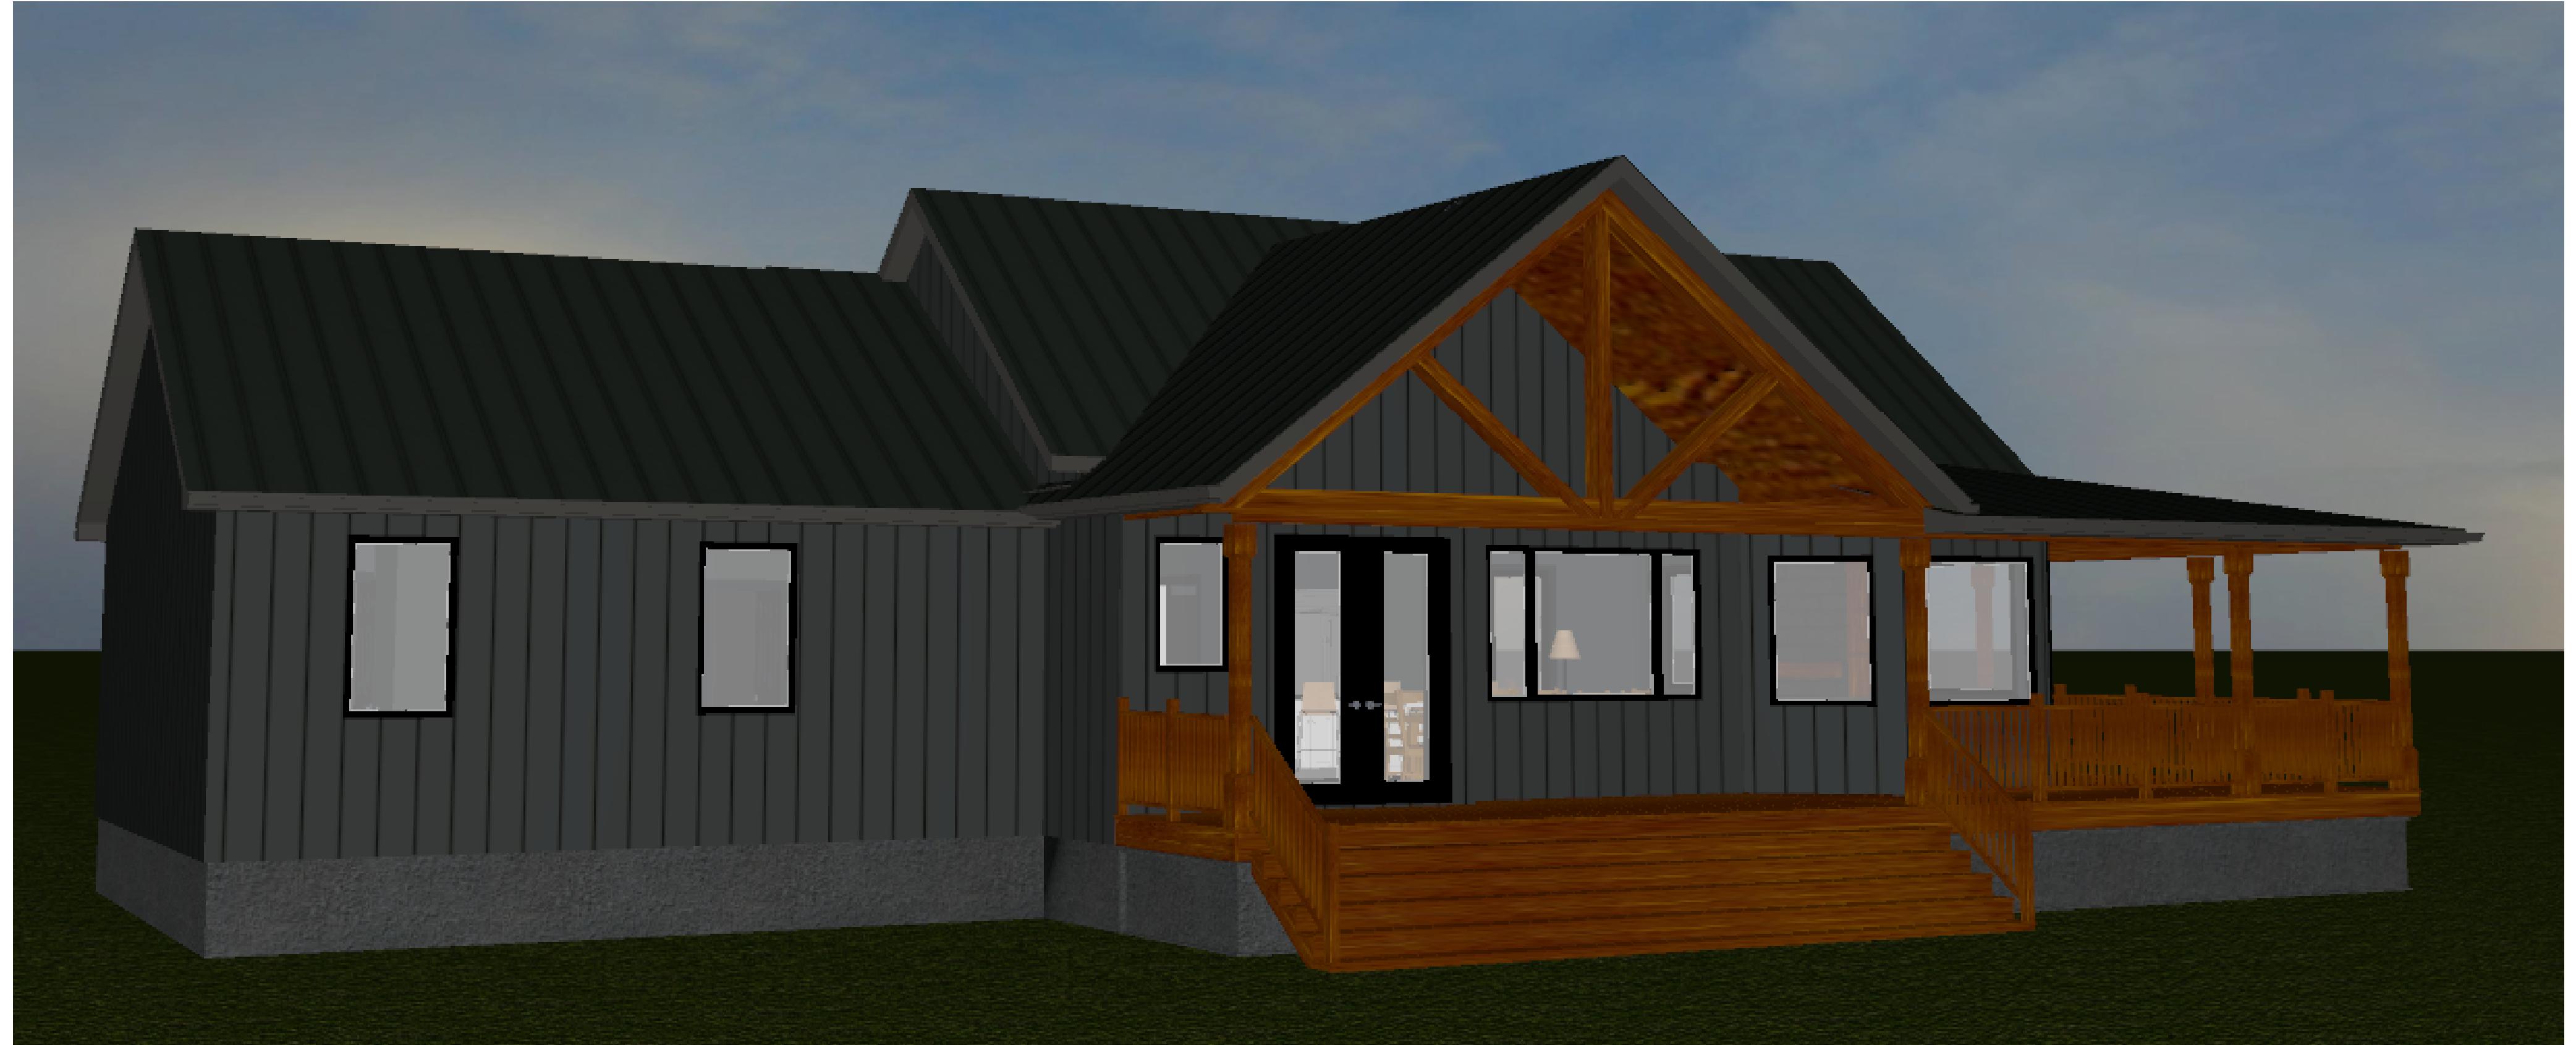

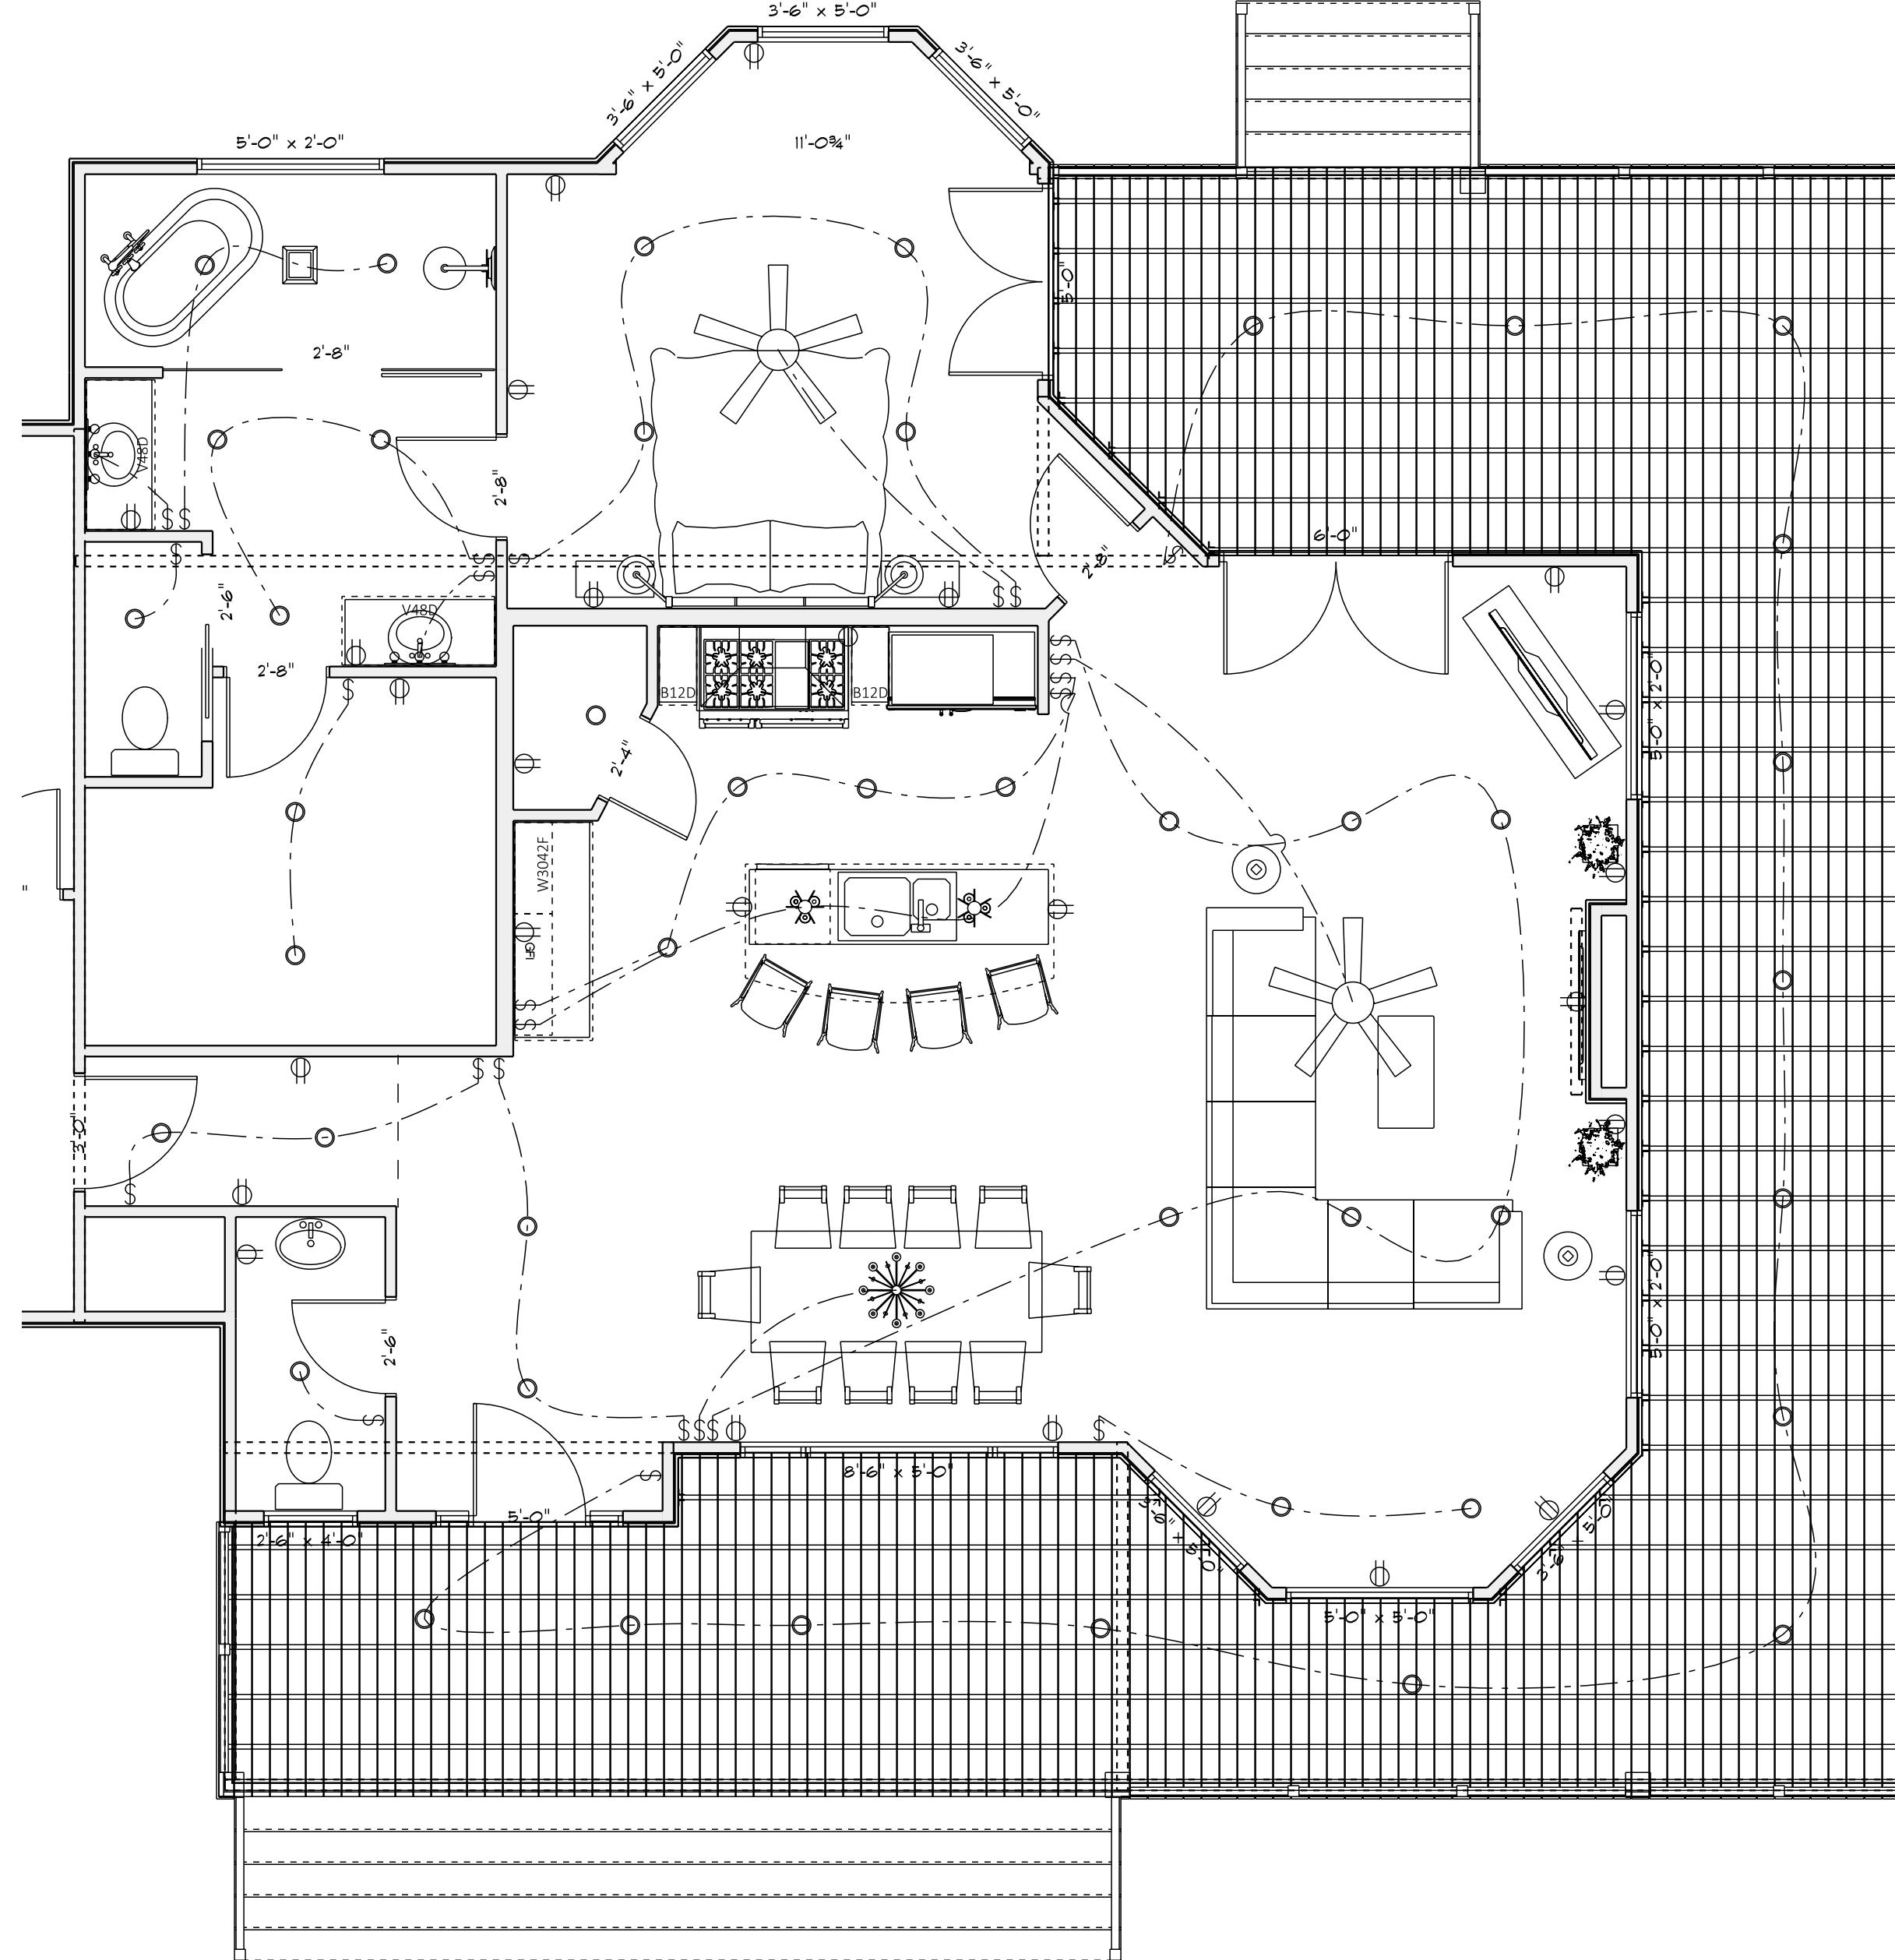

**ELECTRICAL**  
SCALE: 1/4" = 1'-0"

<b>ELECTRICAL LEGEND</b>		
<b>ELECTRICAL</b>	<b>COUNT</b>	<b>SYMBOL</b>
can light 6inch	44	○
ceiling classic	1	*
ceiling fan 5 bladed 04	2	★
ceiling light 22	2	※
combination fan and light-square	1	□
outlet	26	◎
outlet gfi	1	◎
switch - rocker style	25	\$
vanity bar light 02	2	●●●