Tobacco Ro Cypro ELEVAT



FRONT DOOR STYLE PER PURCHASE ORDER

INCLUDED OPTIONS:

1st FLOOR SCREENED PORCH TRIPLE SLIDING DOOR GOURMET KITCHEN FIXED WINDOWS @ BREAK FIREPLACE W/ BUILT-INS FLOOR RECEPTACLE @ FA FLOOR RECEPTACLE @ ST BOX OAK STAIRS OPEN RAIL FRENCH DOORS @ STUDY BENCH @ MUD ROOM OWNERS DELUXE BATH 3RD CAR GARAGE

2nd FLOOR 2ND SINK @ BATH 2 BEDROOM 4 UNFINISHED STORAGE

	_	07	▶			(F)	919-	-556	7 7 7 7 7 7 7 7 7 7 7 7 7 7 7 7 7 7 7	8	
								NOSOIVAD			
				DATE	08/12/2021	I	I		I	1	
		3-CA FRONT OPTI	LOAD	DESCRIPTION	SEE COVERSHEET	1	1	1	1	1	1 1
				REV.#	1	2	3	4	5	9	~ 8
KFAST F AMILY R TUDY	ROOM				7040 - THF CYPRESS II - RH		I F FAMILY			" Chant ID'	OVEL DILGEL D
(SQUARE ELEVA	FOOTA	AGE		Ú H H		UNIC				2200
	HRST FLOOR SECOND FLOOR REAR DECK FRONT PORCH 2-CAR GARAGE	UNHEATED 0 162 214 497	HEATED 1981 1080 0 0 0		1T - 020C					-	
	SUBTOTAL S	873	3061				DRA\ outh		BY: igns		
	TOTAL UNDER ROOF	39	934				SSUE 06/3				
	OPT				CUR	REN	IT RI	EVIS	SION	DATE	à
		UNHEATED 0	HEATED 216					ALE = 1'-			
	OPT. BED #4					_		-			-
	OPT. BED #4 OPT. 3 CAR GARAGE OPT. SCREENED PORCH	265 162	0					IEET	ſ	_	


General Floor Plan Notes

General Floor Plan Notes shall apply unless noted otherwise on plan.


Wall Heights: Typically 9'-1 1/2" at first floor and

NOTE:

Wain regims. Typically 7: 172 anish too and 8:-1 1/2" at second floor and attics UN.O. All walls are constructed using a double top plate. Splices at Double Top Plate do not need to occur at Vertical Studs but must be at least 24" apart from Joint in other Top Plate layer. Special wall heights are noted EXACT LOCATION OF FLOOR RECEPTACLES @ FAMILY ROOM & on plans where they occur. STUDY TO BE 2. Wall Thickness is typically 4" at exterior walls, 3 1/2" at interior. 2x6 frame shall be used at walls that back up to plumbing fixtures. Walls greater than 10' high shall be framed with 2x6 framing or greater and will be noted as a special condition where it occurs **DETERMINED AT PRE-CON MEETING** on plan Typical header height shall be 8'-0" AFF at First Floor, and 7'-4" AFF at Second Floor U.N.O. 4. Jacks: Openings up to 3'-4" wide shall have (1) 2x4 jack stud SPF on each side. Openings greater than 3'-4" wide shall have (2) 2x4 jack studs SPF on each 5. Soffits, Coffered Ceilings, Trey Ceilings and other Soma, contracting an elements are shown on the floor plans and are denoted as single dashed lines. Unless specifically call out as included, Kitchens <u>do</u> <u>not</u> include soffits over wall cabinetry. . Door & Window Frames, where occurring near corners, shall be a minimum of 4 1/2" from corner. Except for walk-in closets with doors near a corner at closets shall be centered on closet Windows: Shall have at least (1) window in each sleeping room, that meets egress. Shall be provided with tempered glass at hazardows glazing areas. False windows shall be installed with obscure Closets for clothing or coat storage shall be equipped with 1 rod/shelf. Closets for linen shall have 5 open equal shelves. Closets for pantries shall have 5 equal wood shelves, painted. . Stair treads shall be a min of 9" deep, risers shall be a maximum of 8 1/4", unless noted otherwise, per the current North Carolina Residential Code 10. Handrails and Guards at stairs shall be 34" above the finished surface of the ramp surface of the stair. Handrails at landings and overlooks of multilevel spaces shall be 36" above finished floor. Guards (pickets or balisters) shall be spaced with no more than 4" between guards. 11. Attic Access shall be provided at all attic area with a height greater than 30°. Minimum clear attic access shall be 20° x 30°. Pull down stairs and access doors in knee walls meeting minimum criteria are also acceptable. 12.Garage Door to Living Space shall be 2'-8" x 6'-8" minimum size and shall be 20 minute fire rated and weather sealed. 13. Garage Walls, as a minimum, shall be separated from living space by installing 1/2" gypsum board on the garage side of the wall. With habitable space above, the inside of all garage walls require 1/2" GWB supporting 5/8" type X GWB on ceiling. **Tobacco Road** Lot 107

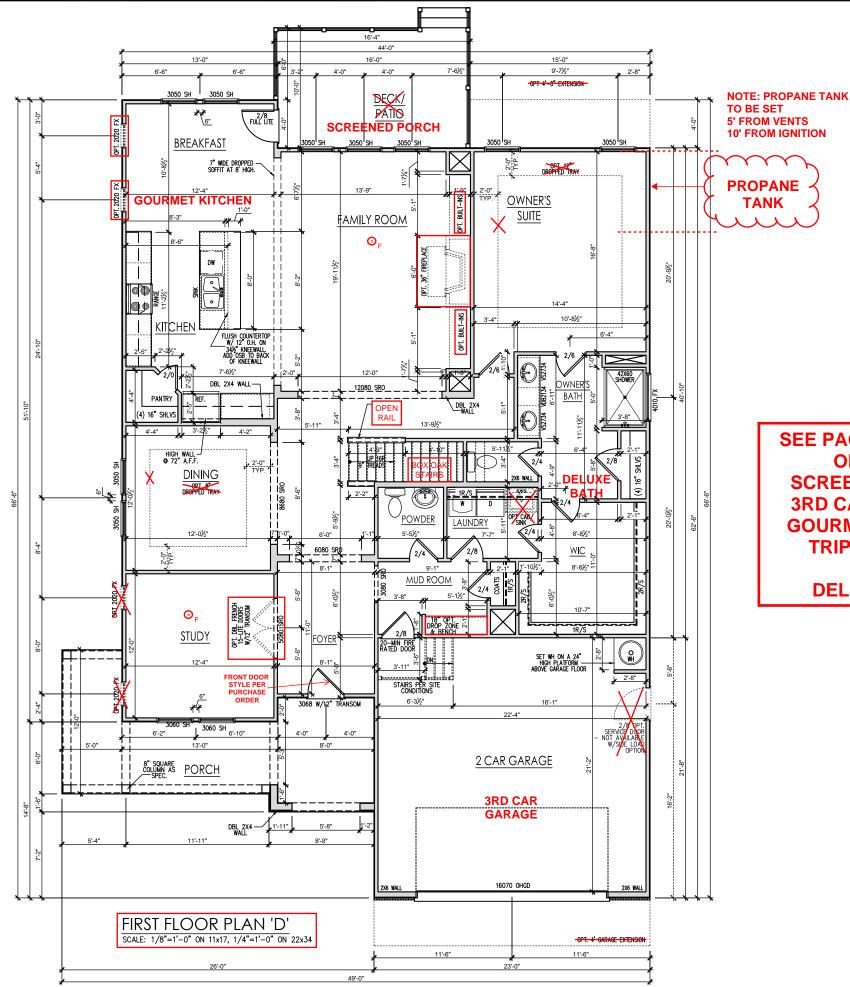


SEE PAGE 2.1.1d FOR **OPTIONS:** SCREENED PORCH **3RD CAR GARAGE GOURMET KITCHEN TRIPLE SLIDER** & **DELUXE BATH**

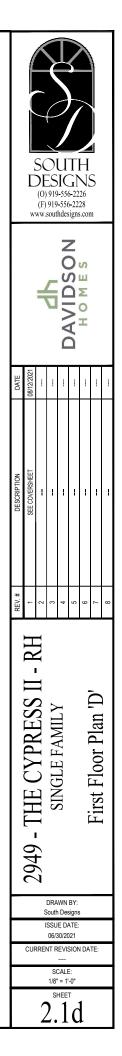


General Floor Plan Notes

General Floor Plan Notes shall apply unless noted otherwise on plan.


- Wall Heights: Typically 9'-1 1/2" at first floor and 8'-1 1/2" at second floor and attics U.N.O. All walls are constructed using a double top plate. Splices at Double Top Plate do not need to occur at Vertical Studs but must be at least 24" apart from Joint in other Top Plate layer. Special wall heights are noted on plans where they occur.
- 2. Wall Thickness is typically 4" at exterior walls, 3 1/2" at interior. 2x6 frame shall be used at walls that back up to plumbing fixtures. Walls greater than 10' high shall be framed with 2x6 framing or greater and will be noted as a special condition where it occurs on plan.
- Typical header height shall be 8'-0" AFF at First Floor, and 7'-4" AFF at Second Floor U.N.O.
- Jacks: Openings up to 3'-4" wide shall have (1) 2x4 jack stud SPF on each side. Openings greater than 3'-4" wide shall have (2) 2x4 jack studs SPF on each side.
- Soffits, Coffered Ceilings, Trey Ceilings and other significant ceiling plan elements are shown on the floor plans and are denoted as single dashed lines. Unless specifically call out as included, Kitchens <u>do</u> <u>not</u> include soffits over wall cabinetry.
- Door & Window Frames, where occurring near corners, shall be a minimum of 4 1/2" from corner. Except for walk-in closets with doors near a corner doors at closets shall be centered on closet.
- Windows: Shall have at least (1) window in each sleeping room, that meets egress. Shall be provided with tempered glass at hazardous glazing areas. False windows shall be installed with obscure alazing.
- Closets for clothing or coat storage shall be equipped with 1 rod/shelf. Closets for linen shall have 5 open equal shelves. Closets for pantries shall have 5 equal wood shelves, painted.
- Stair treads shall be a min of 9" deep, risers shall be a maximum of 8 1/4", unless noted otherwise, per the current North Carolina Residential Code
- 10. Handrails and Guards at stairs shall be 34" above the finished surface of the ramp surface of the stair. Handrails at landings and overlooks of multilevel spaces shall be 34" above finished floor. Guards (pickets or balisters) shall be spaced with no more than 4" between guards.
- 11. Attic Access shall be provided at all attic area with a height greater than 30°. Minimum clear attic access shall be 20° x 30°. Puil down stairs and access doors in knee walls meeting minimum criteria are also acceptable.
- 12.Garage Door to Living Space shall be 2'-8" x 6'-8" minimum size and shall be 20 minute fire rated and weather sealed.
- 13. Garage Walls, as a minimum, shall be separated from living space by installing 1/2" gypsum board on the garage side of the wall. With habitable space above, the inside of all garage walls require 1/2" GWB supporting 5/8" type X GWB on ceiling.

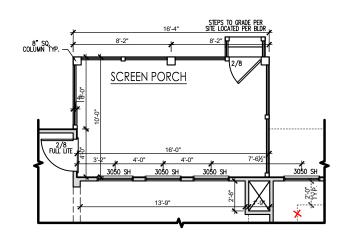





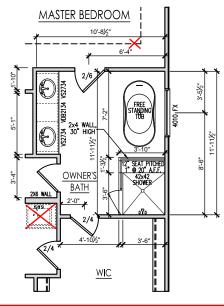




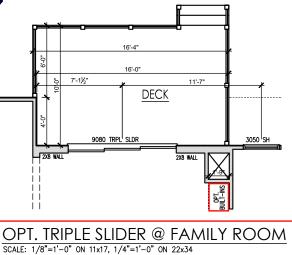

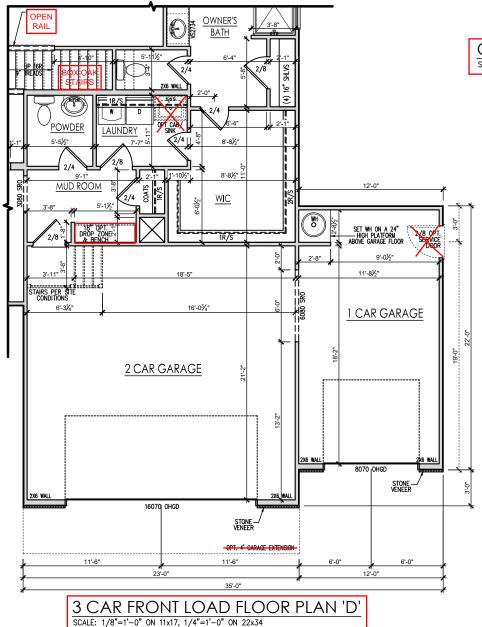

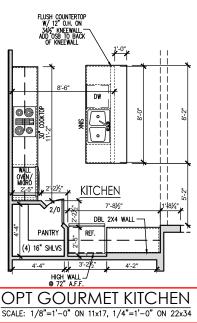


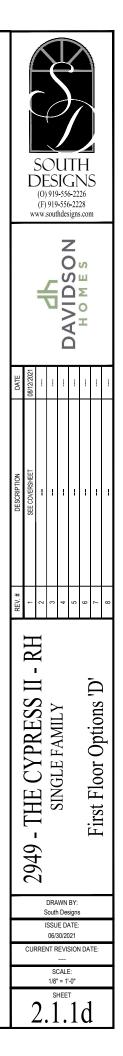


General Floor Plan Notes

General Floor Plan Notes shall apply unless noted otherwise on plan.

- Wall Heights: Typically 9'-1 1/2" at first floor and 8'-1 1/2" at second floor and attics U.N.O. All walls are constructed using a double top plate. Splices at Double Top Plate do not need to occur at Vertical Studs but must be at least 24" apart from Joint in other Top Plate layer. Special wall heights are noted on plans where they occur.
- 2. Wall Thickness is typically 4" at exterior walls, 3 1/2" at interior. 2x6 frame shall be used at walls that back up to plumbing fixtures. Walls greater than 10' high shall be framed with 2x6 framing or greater and will be noted as a special condition where it occurs on plan.
- Typical header height shall be 8'-0" AFF at First Floor, and 7'-4" AFF at Second Floor U.N.O.
- Jacks: Openings up to 3'-4" wide shall have (1) 2x4 jack stud SPF on each side. Openings greater than 3'-4" wide shall have (2) 2x4 jack studs SPF on each side.
- Soffits, Coffered Ceilings, Trey Ceilings and other significant ceiling plan elements are shown on the floor plans and are denoted as single dashed lines. Unless specifically call out as included, Kitchens <u>do</u> <u>not</u> include soffits over wall cabinetry.
- 6. Door & Window Frames, where occurring near corners, shall be a minimum of 4 1/2" from corner. Except for walk-in closets with doors near a corner doors at closets shall be centered on closet.
- Windows: Shall have at least (1) window in each sleeping room, that meets egress. Shall be provided with tempered glass at hazardous glazing areas. False windows shall be installed with obscure alazing.
- Closets for clothing or coat storage shall be equipped with 1 rod/sheft. Closets for linen shall have 5 open equal shelves. Closets for pantries shall have 5 equal wood shelves, painted.
- Stair treads shall be a min of 9" deep, risers shall be a maximum of 8 1/4", unless noted otherwise, per the current North Carolina Residential Code
- 10. Handrails and Guards at stairs shall be 34" above the finished surface of the ramp surface of the stair. Handrails at landings and overlooks of multilevel spaces shall be 34" above finished floor. Guards (pickets or balisters) shall be spaced with no more than 4" between guards.
- 11. Aftic Access shall be provided at all attic area with a height greater than 30". Minimum clear attic access shall be 20" x 30". Pull down stairs and access doors in knee walls meeting minimum criteria are also acceptable.
- 12. Garage Door to Living Space shall be 2'-8" x 6'-8" minimum size and shall be 20 minute fire rated and weather sealed.
- 13. Garage Walls, as a minimum, shall be separated from living space by installing 1/2" gypsum board on the garage side of the wall. With habitable space above, the inside of all garage walls require 1/2" GWB supporting 5/8" type X GWB on ceiling.

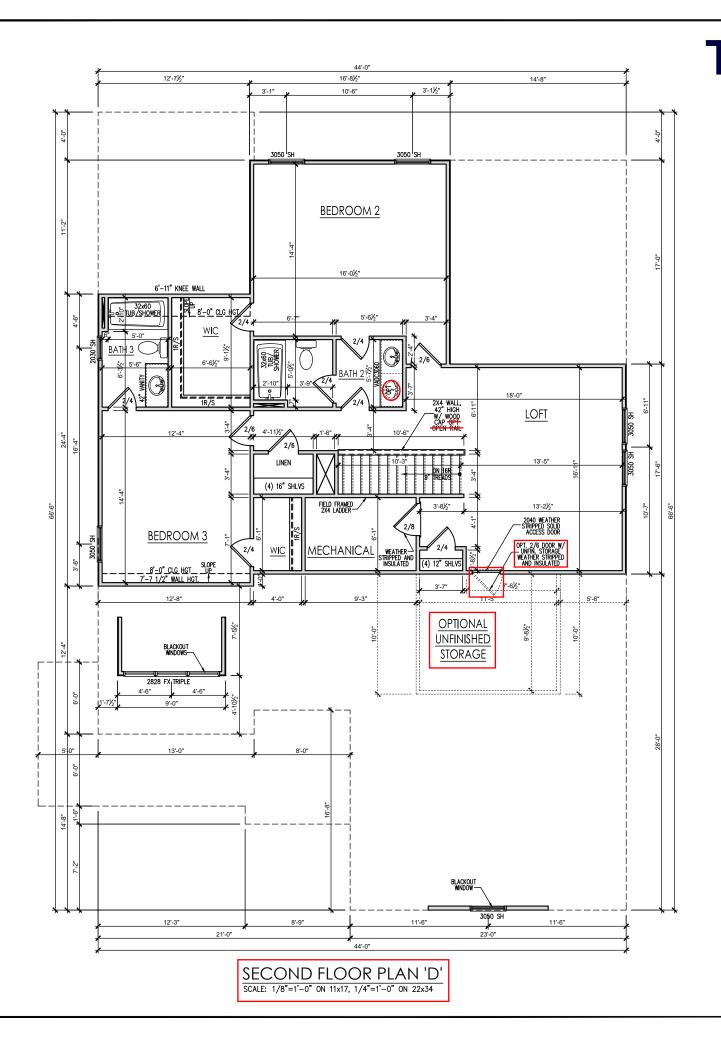

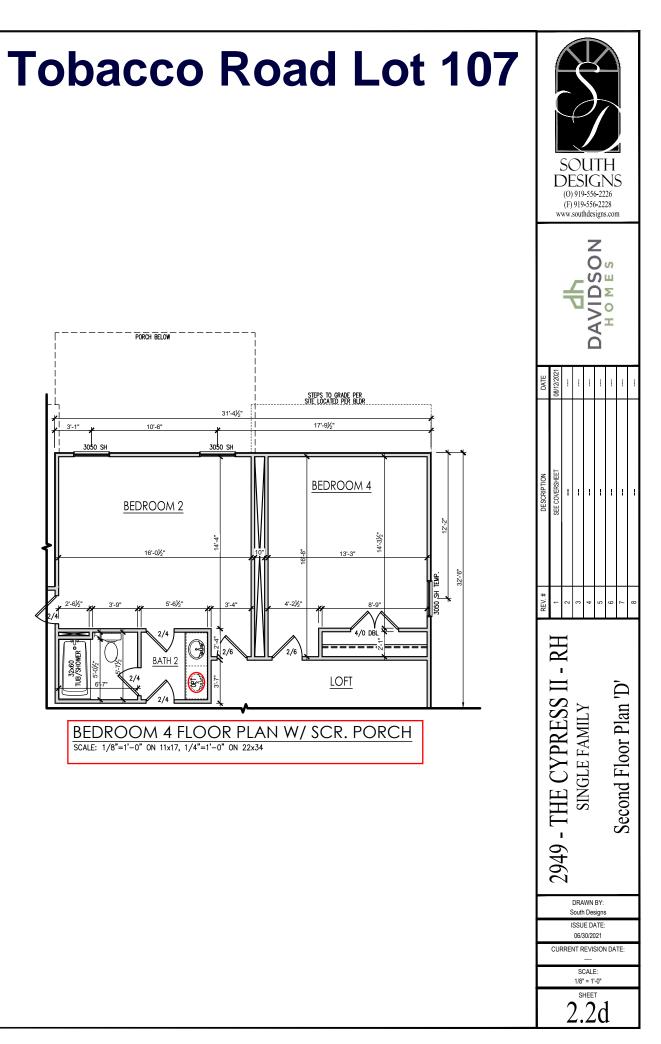


General Elevation Notes


General Elevation Notes shall apply unless noted otherwise on plan.

- Roof shall be finished with architectural composition shingles with slopes as noted on plan.
- Ridge Vent shall be provided and installed on all ridges greater than 6' in length per manufacturer's specifications.
- 3. Soffit Vent shall be continuous soffit vent
- House Wrap, "tyvek" or approved equal shall be installed over entire exterior wall per manufacturer's specifications and recommendations.
- Flashing shall be provided above all door and window openings, above finish wall material changes and at wall surfaces where lower roof areas abut vertical wall surfaces.
- 6. Porch Railings shall be provided at all porch walking surfaces greater than 30° above adjacent finished grade. It shall be 36° high with guards spaced no more than 4° apart. Consult community specifications for material.
- 7. Finish Wall Material shall be as noted on elevation drawings.
- 8. Brick Veneer, if included on elevation shall be tied to wall surface with galvanized corrugated metal ties at a rate of 24" oc harizontally and 14" oc vertically so that no more than 2.675f of brick is supported by (1) tie. Space between face of wall and back face of brick shall be limited to a maximum of 1". Flashing shall be provided behind brick above all wall openings and at base of brick wall. Flashing shall be a minimum of 6 brick shall be instituted to a transitive the time of the shall be a minimum of 6 brick wall. Flashing shall be a minimum of 6 brick wall. Flashing shall be a minimum of 6 brick wall. Flashing shall be a minimum of 6 brick wall. Flashing shall be a brink wall be provided at a rate of 48" oc and shall not be less than 316" in diameter and shall be los loss and 316" in diameter and shall be loss that 316" in diameter and shall be loss than 316" in diameter and shall be loss than 316" in diameter and shall be located immediately above flashing.
- Brick Veneer Support Lintels shall be provided if brick veneer is included on elevation. Lintels shall be provided as listed in the following schedule and shall have a minimum bearing length of 6". Masonry Lintels shall be provided so that deflection is limited to L/600.

Masonry Opening Lintel Schedule

Opening S	Size	Angle
up to 4'-0'		3-1/2" x 3-1/2" x 5/16"
4'-1" to	5'-6"	4" x 3-1/2" x 5/16" LLV
5'-7" to	6'-6"	5" x 3-1/2" x 5/16" LLV
6'-7" to	8'-4"	6" x 3-1/2" x 5/16" LLV
8'-5" to	16'-4"	7" x 4" x 3/8" LLV

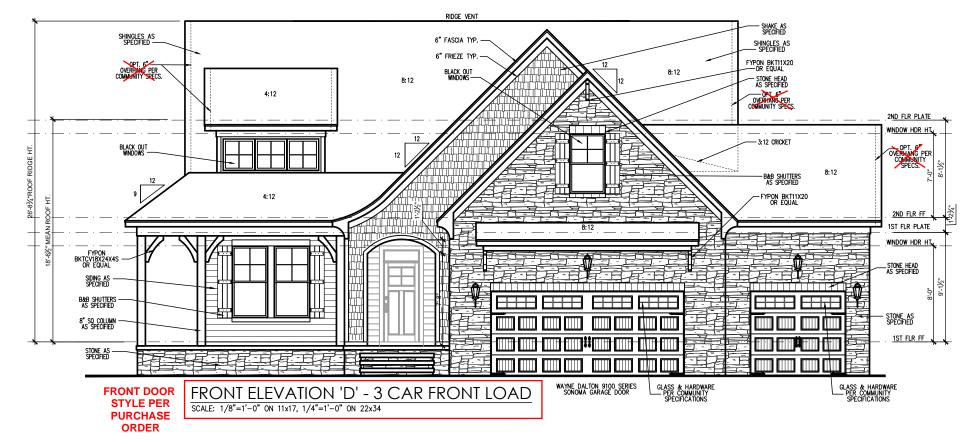

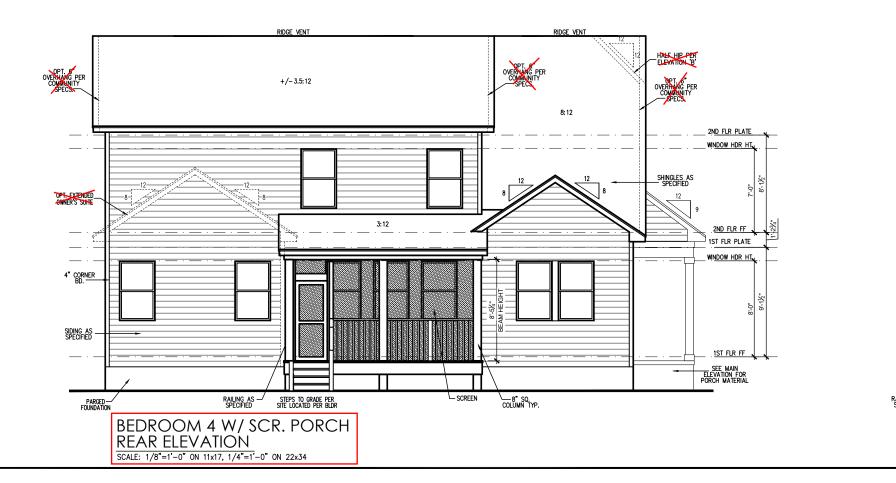



SOUTH DESIGNS (0) 919-556-2228 (F) 919-556-2228 www.southdesigns.com								
	DAVIDSO							
DATE	08/12/2021	-	-	1				I
DESCRIPTION	SEE COVERSHEET			1	-	-	-	-
REV.#	1	2	3	4	5	9	7	8
2949 - THE CYPRESS II - RH SINGLE FAMILY Front & Rear Elevations 'D'								
	DRAWN BY: South Designs							
	CUF		06/3	30/20	ATE:)21 SION		TE:	
	100		S	 CALI	:			_
				- I HEE 1		1		
3.1d								


General Elevation Notes

General Elevation Notes shall apply unless noted otherwise on plan.


- Roof shall be finished with architectural composition shingles with slopes as noted on plan.
- Ridge Vent shall be provided and installed on all ridges greater than 6' in length per manufacturer's specifications.
- 3. Soffit Vent shall be continuous soffit vent
- House Wrap, "tyvek" or approved equal shall be installed over entire exterior wall per manufacturer's specifications and recommendations.
- Flashing shall be provided above all door and window openings, above finish wall material changes and at wall surfaces where lower roof areas abut vertical wall surfaces.
- 6. Porch Railings shall be provided at all porch walking surfaces greater than 30° above adjacent finished grade. It shall be 36° high with guards spaced no more than 4° apart. Consult community specifications for material.
- 7. Finish Wall Material shall be as noted on elevation drawings.
- 8. Brick Veneer, if included on elevation shall be tied to wall surface with galvanized corrugated metal ties at a rate of 24" oc harizontally and 14" oc vertically so that no more than 2.675f of brick is supported by (1) tie. Space between face of wall and back face of brick shall be limited to a maximum of 1". Flashing shall be provided behind brick above all wall openings and at base of brick wall. Flashing shall be a minimum of 6 brick shall be instituted to a transitive the time of the shall be a minimum of 6 brick wall. Flashing shall be a minimum of 6 brick wall. Flashing shall be a minimum of 6 brick wall. Flashing shall be a minimum of 6 brick wall. Flashing shall be a brink wall be provided at a rate of 48" oc and shall not be less than 316" in diameter and shall be los loss and 316" in diameter and shall be loss that 316" in diameter and shall be loss than 316" in diameter and shall be loss than 316" in diameter and shall be located immediately above flashing.
- Brick Veneer Support Lintels shall be provided if brick veneer is included on elevation. Lintels shall be provided as listed in the following schedule and shall have a minimum bearing length of 6". Masonry Lintels shall be provided so that deflection is limited to L/600.

Masonry Opening Lintel Schedule

Openin	g Size	Angle
up to 4'	-0"	3-1/2" x 3-1/2" x 5/16"
4'-1" to	5'-6"	4" x 3-1/2" x 5/16" LLV
5'-7" to	6'-6"	5" x 3-1/2" x 5/16" LLV
6'-7" to	8'-4"	6" x 3-1/2" x 5/16" LLV
8'-5" to	16'-4"	7" x 4" x 3/8" LLV

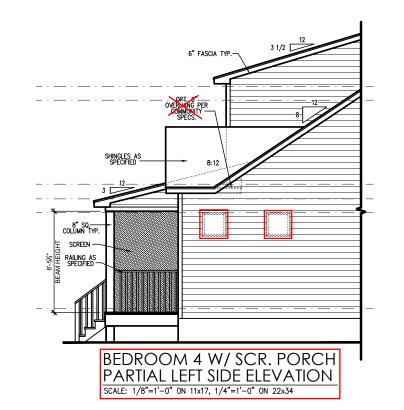



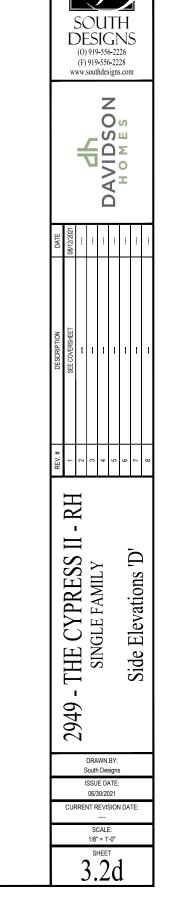

General Elevation Notes

General Elevation Notes shall apply unless noted otherwise on plan.


- Roof shall be finished with architectural composition shingles with slopes as noted on plan.
- Ridge Vent shall be provided and installed on all ridges greater than 6' in length per manufacturer's specifications. 2.

3. Soffit Vent shall be continuous soffit vent

- House Wrap, "tyvek" or approved equal shall be installed over entire exterior wall per manufacturer's specifications and recommendations. 4
- Flashing shall be provided above all door and window openings, above finish wall material changes and at wall surfaces where lower roof areas abut vertical wall surfaces.
- Porch Railings shall be provided at all porch walking surfaces greater than 30° above adjacent finished grade. It shall be 36° high with guards spaced no more than 4° apart. Consult community specifications for material. 6.
- Finish Wall Material shall be as noted on elevation drawings
- Brick Veneer, if included on elevation shall be tied to wall surface with galvanized corrugated metal ties at a rate of 24" oc horizontally and 16" oc vertically so a rate of 24° oc horizontally and 16° oc verifically so that no more than 2.67st of brick is supported by (1) tie. Space between face of wall and back face of brick shall be limited to a maximum of 1°. Flashing shall be provided behind brick above all wall openings and at base of brick wall. Flashing shall be a minimum of 6 -mil poly or other corrosion resistant material and shall be installed so that it laps under the house wrap material a minimum of 2°. Weepholes shall be provided at a rate of 48° oc and shall not be less than 3/16° in diameter and shall be located immediately above flashing.
- Brick Veneer Support Lintels shall be provided if brick veneer is included on elevation. Lintels shall be provided as listed in the following schedule and shall have a minimum bearing length of 6". Masonry Lintels shall be provided so that deflection is limited to L/600.

Masonry Opening Lintel Schedule


Opening S	lize	Angle
up to 4'-0'		3-1/2" x 3-1/2" x 5/16"
4'-1" to	5'-6"	4" x 3-1/2" x 5/16" LLV
5'-7" to	6'-6"	5" x 3-1/2" x 5/16" LLV
6'-7" to	8'-4"	6" x 3-1/2" x 5/16" LLV
8'-5" to	16'-4"	7" x 4" x 3/8" LLV

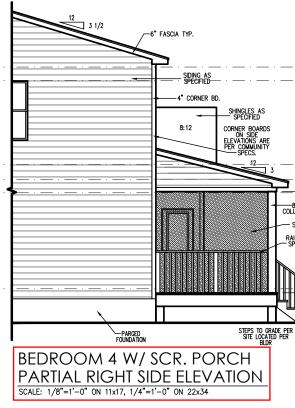




DAVIDSON HOMES						
	DAVIDSON					
DATE 08/12/2021 						
DESCRIPTION SEE COVERSHEET 	-					
REV.# 1 1 1 1 1 1 1 1 1 1 1 1 1 1 1 1 1 1 1	۵ ۵					
2949 - THE CYPRESS II - RH SINGLE FAMILY Side Elevations 'D'						
DRAWN BY: South Designs ISSUE DATE:						
06/30/2021 CURRENT REVISION DATE:	_					
 SCALE: 1/8" = 1'-0"						
3.3d						




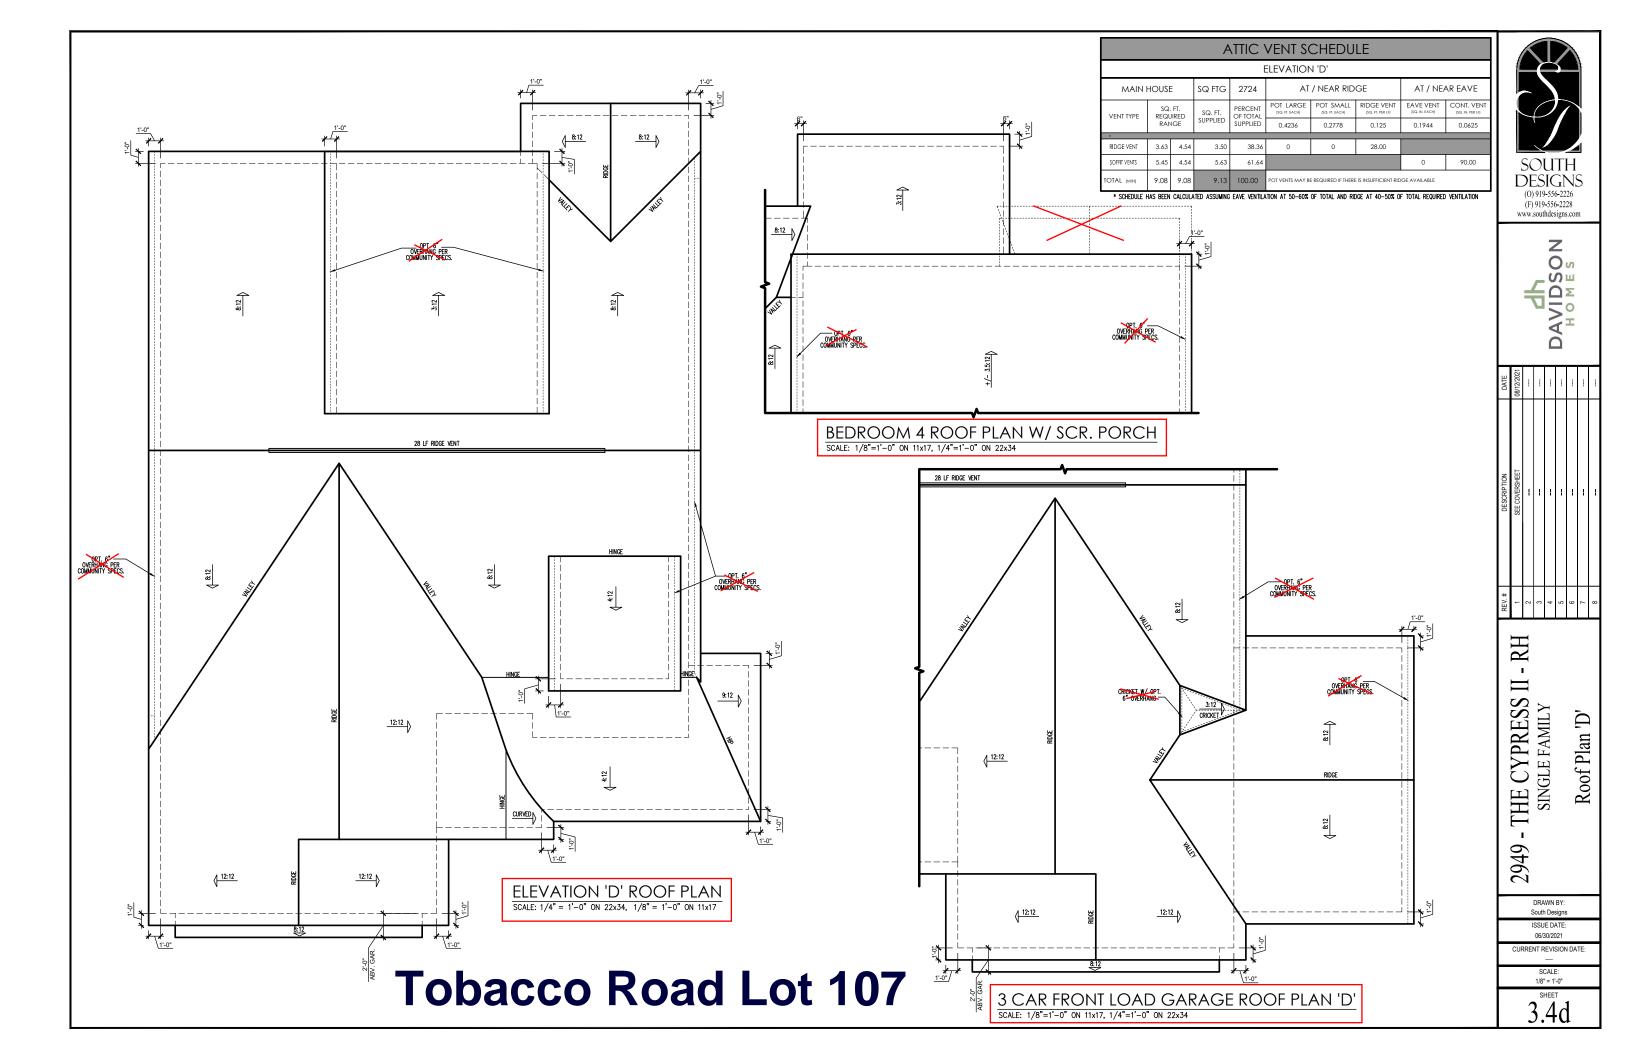

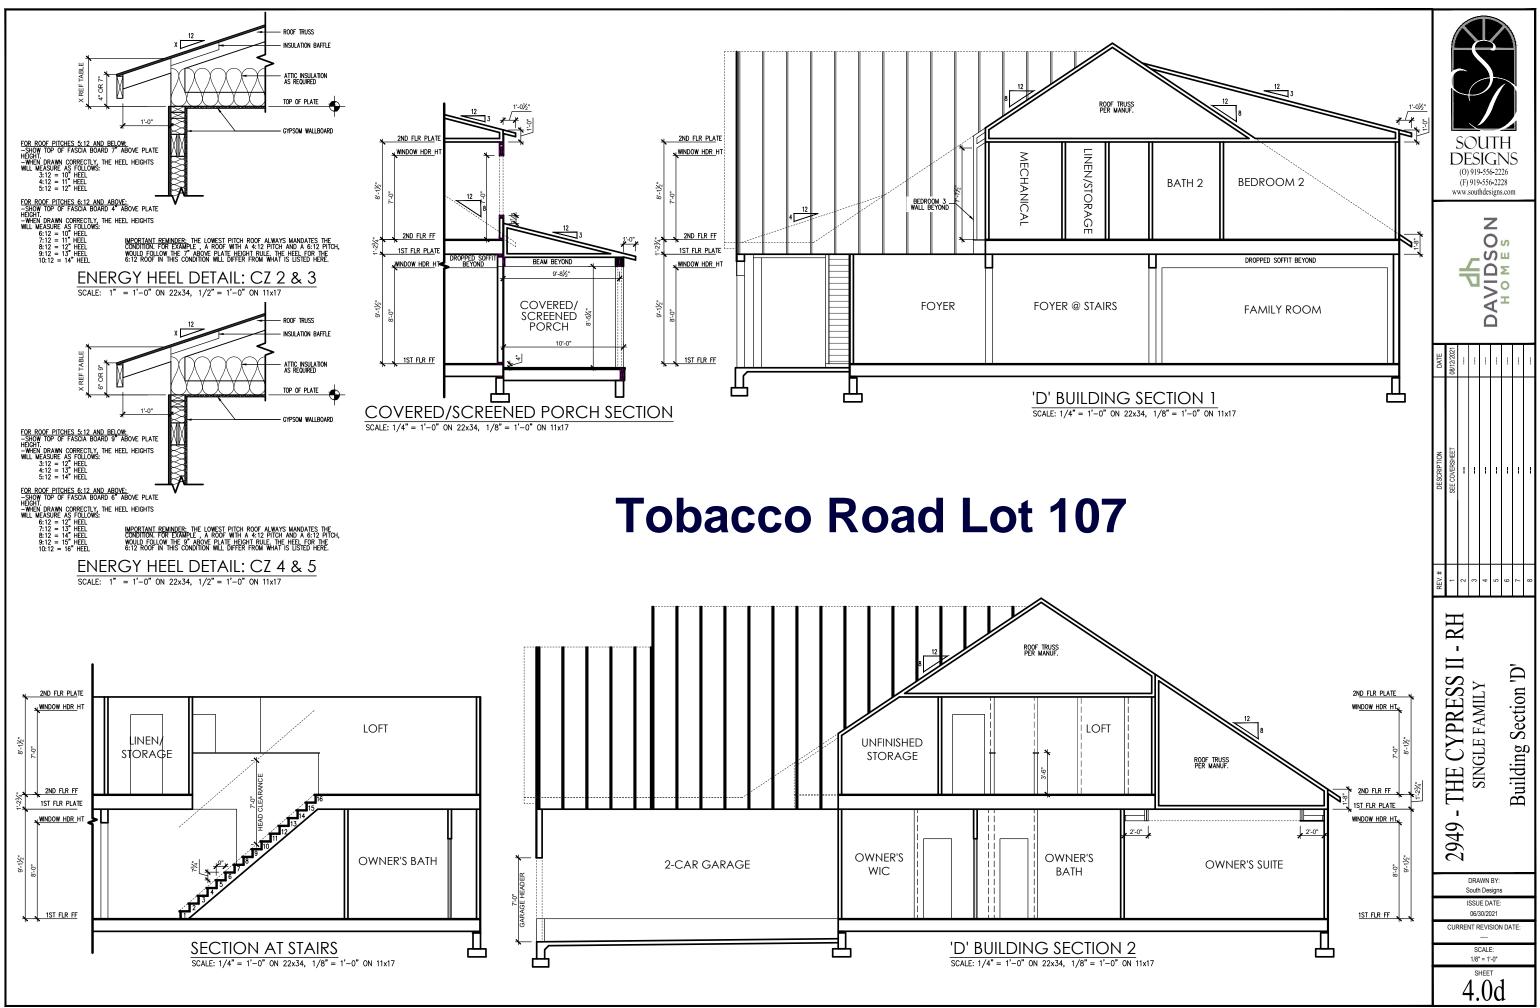

ELECTRICAL SYMBOL KEY

LIGHT	FIXTURES
\$	CEILING SURFACE MOUNT LED LIGHT
₿	RECESSED CAN LIGHT
Ðdw⊳	RECESSED CAN LIGHT WATERPROOF
Ð	RECESSED CAN - EYEBALL
⊕	PENDANT LIGHTING
Ø	WALL SCONCE
φ	WALL MOUNT LIGHT
1P	FLOOD LIGHT
OUTLE	TS
₽	DUPLEX OUTLET
₽	GFI OUTLET
	WATERPROOF GFI OUTLET
-	SWITCHED 1/2 HOT DUPLEX OUTLET
₩ 220v	220V OUTLET
4	TELEPHONE OUTLET
찍	CATV (TELEVISION) OUTLET
÷.	UNDER-COUNTER OR CONCEALED OUTLETS
Ø	CEILING MOUNTED DUP. OUTLET
SWITC	-
\$	SINGLE POLE SWITCH
\$ ³	THREE-WAY SWITCH
\$ ⁴	FOUR-WAY SWITCH
	ELECTRICAL DISCONNECT
	FIXTURES
	EXHAUST FAN
, O	JUNCTION BOX
-Ф _{220V}	JUNCTION BOX 220V
● _{CM} ● _{SE}	CARBON MONOXIDE DETECTOR OR SMOKE DETECTOR
	CARBON MONOXIDE DETECTOR AND SMOKE DETECTOR
	ELECTRIC METER
Elec Panel	ELECTRICAL PANEL
Ψ	DOOR BELL CHIME
6	DOOR BELL PUSH BUTTON
c:::><:::>	CEILING FAN PREWIRE
19 19 19	FLUORESCENT LIGHT

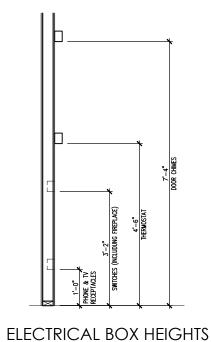


General Power and Lighting:

General Power and Lighting Notes shall apply unless noted otherwise on plans.


All work shall be installed per the current NC Residential Building Code, and the National Electric Code. Alarm devices shall meet NFPA 72.

- Smoke Alarms Shall be provided as a minimum of (1) per floor, including basements (if applicable), (1) in each sleep room, and (1) outside each sleeping area, within the immediate vicinity of sleeping rooms. When more than one alarm is required, the alarm devices shall be interconnected in such a manner that the activation of one alarm will activate all of the alarms. Smoke alarms shall be hard wired to permanent power and shall have battery back-usa.
- 2. Switches For lighting, tans, etc. shall be installed at heights illustrated on this page and shall be located a minimum of 4 1/2" from door openings to allow for the proper installation of door casings. Switches, thermostats, security pads, and other similar devices shall be grouped together and installed thoughtfully for convenience of use and to avoid placement within centers of wall areas.

Note: This plan is a diagram showing approximate locations of convenience outlets based on requirements found in the NC Residential Code and N.E.C. Actual positions may vary from what is shown on plan.

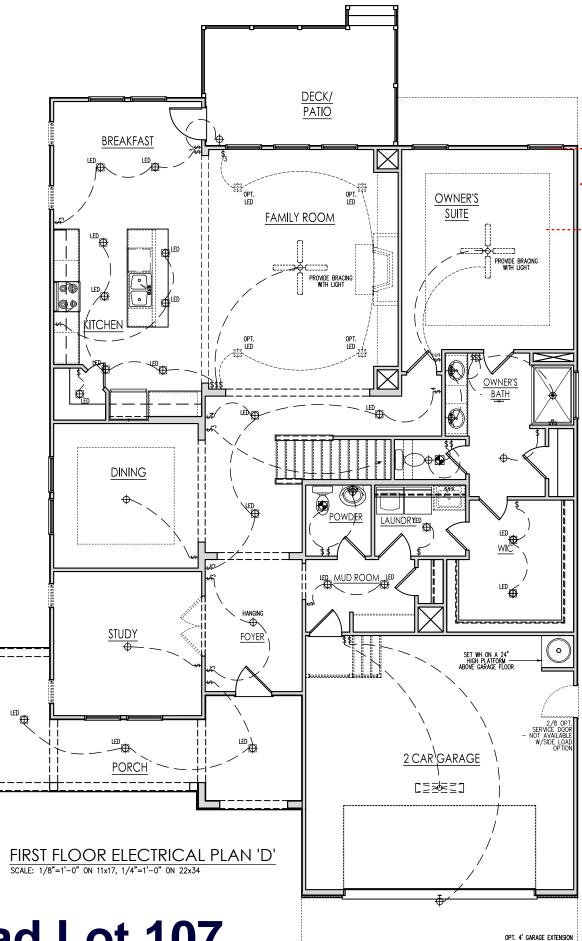


Tobacco Road Lot 107

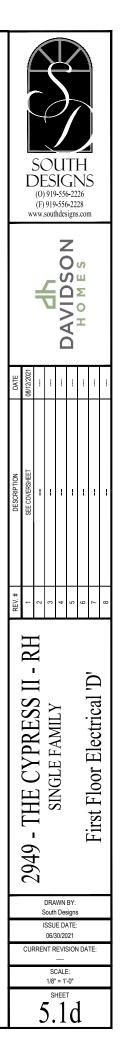





NOTE: PROPANE TANK TO BE SET 5' FROM VENTS 10' FROM IGNITION

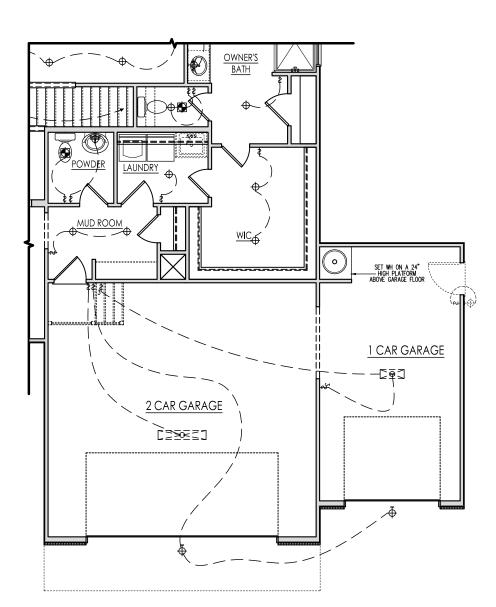



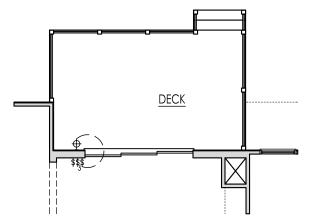


OPT. TRIPLE SLIDER @ FAMILY ROOM SCALE: 1/8"=1'-0" ON 11x17, 1/4"=1'-0" ON 22x34

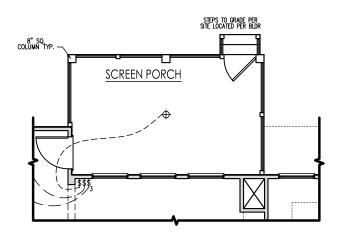

KITCHEN

OPT GOURMET KITCHEN SCALE: 1/8"=1'-0" ON 11x17, 1/4"=1'-0" ON 22x34




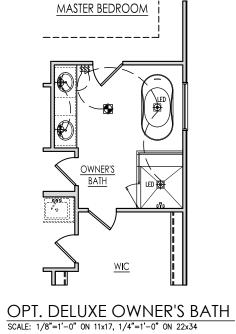


SCREENED PORCH ELECTRICAL SCALE: 1/8"=1'-0" ON 11x17, 1/4"=1'-0" ON 22x34

SOUTH DESIGNS (0) 919-556-2228 www.southdesigns.com								
DATE	08/12/2021	-	-	-		-	-	-
DESCRIPTION	SEE COVERSHEET							
REV. #	1	2	3	4	5	9	7	8
2949 - THE CYPRESS II - RH SINGLE FAMILY First Floor Options Electrical 'D'								
DRAWN BY: South Designs ISSUE DATE:								
_	CUF		06/3	30/20	021		TE:	_
			1/8'	CALE ' = 1'	-0"			
5.1.1d								

ELECTRICAL SYMBOL KEY

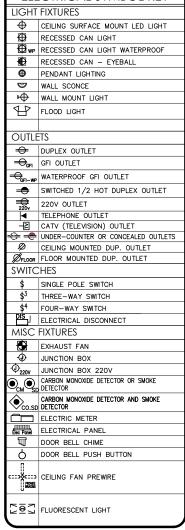

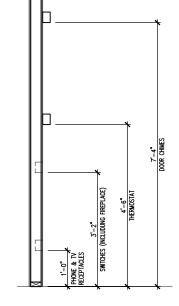

ELECTRICAL BOX HEIGHTS



General Power and Lighting Notes shall apply unless noted otherwise on plans.


All work shall be installed per the current NC Residential Building Code, and the National Electric Code. Alarm devices shall meet NFPA 72.


Smoke Alarms - Shall be provided as a minimum of (1) per floor, including basements (if applicable), (1) in each sleep room, and (1) outside each sleeping area, within the immediate vicinity of sleeping rooms. When more than one alarm is required, the alarm devices shall be interconnected in such a manner that the activation of one alarm will activate all of the alarms. Smoke alarms shall be hard wired to permanent power and shall have pattery back-ups.

2.

Switches - For lighting, fans, etc. shall be installed at heights illustrated on this page and shall be located a minimum of 4 1/2" from door openings to allow for the proper installation of door casings. Switches, thermostats, security pads, and other similar devices shall be grouped together and installed thoughtfully for convenience of use and to avoid placement within centers of wall areas.

Note: This plan is a diagram showing approximate locations of convenience outlets based on requirements found in the NC Residential Code and N.E.C. Actual positions may vary from what is shown on plan.

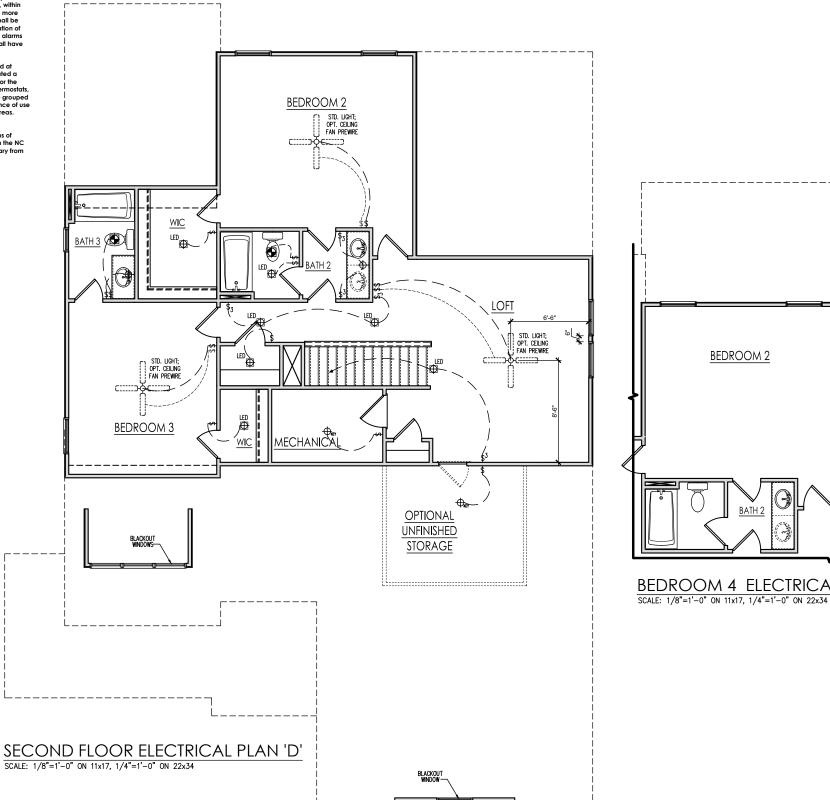

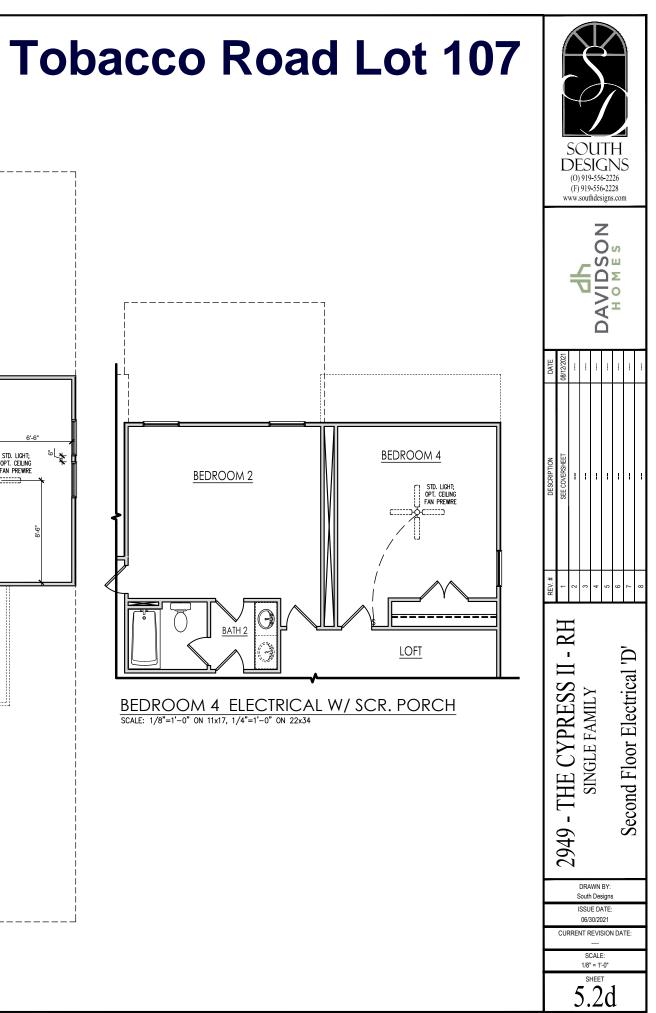



THESE DRAWINGS ARE TO BE USED IN CONJUNCTION WITH AND COORDINATED WITH THE ARCHITECTURAL, CIVIL, MECHANICAL, ELECTRICAL, AND PLUMBING DRAWINGS. THIS COORDINATION IS NOT THE RESPONSIBILITY OF THE STRUCTURAL ENGINEER OF RECORD (SER). SHOULD ANY DISCREPANCIES BECOME APPARENT, THE CONTRACTOR SHALL NOTIFY KSE ENGINEERING, P.C. BEFORE CONSTRUCTION BEGINS. IT IS THE INTENT OF THE ENGINEER LISTED ON THESE DOCUMENTS THAT THESE DOCUMENTS BE ACCURATE, PROVIDING LICENSED PROFESSIONALS CLEAR INFORMATION. EVERY ATTEMPT HAS BEEN MADE TO PREVENT ERROR. THE BUILDER AND ALL SUBCONTRACTORS ARE REQUIRED TO REVIEW ALL OF THE INFORMATION CONTAINED IN THESE DOCUMENTS PRIOR TO THE COMMENCEMENT OF ANY WORK. THE ENGINEER IS NOT RESPONSIBLE FOR ANY PLAN ERRORS, OMISSIONS, OR MISINTERPRETATIONS UNDETECTED AND NOT REPORTED TO THE ENGINEER PRIOR TO CONSTRUCTION. ALL CONSTRUCTION MUST BE IN ACCORDANCE TO THE INFORMATION FOUND IN THESE DOCUMENTS.

(215) 804 - 4449 www.kse-eng.com

CYPRESS II RH

RALEIGH, NORTH CAROLINA

DESIGN SPECIFICATIONS:

DESIGN BUILDING CODE (REFERRED TO HEREIN AS 'THE BUILDING CODE'): • 2018 NORTH CAROLINA RESIDENTIAL CODE. WALL BRACING PER INTERNATIONAL RESIDENTIAL CODE 2015 EDITION.

DESIGN LIVE LOADS:

- ROOF = 20 PSF (LOAD DURATION FACTOR=1.25)
- HABITABLE ATTICS AND ATTICS SERVED WITH FIXED STAIRS = 30 PSF
- FLOOR = 40 PSF
- FLOOR (SLEEPING AREAS) = 30 PSF
- DECK/BALCONY = 40 PSF STAIRS = 40 PSF

DESIGN DEAD LOADS: • ROOF TRUSS = 17 PSF (TC=7, BC=10)

- FLOOR TRUSS = 15 PSF (TC=10, BC=5)
- FLOOR JOIST = 10 PSF
- STANDARD BRICK = 40 PSF
- QUEEN ANNE BRICK = 25 PSF

NOTE: STRUCTURAL FRAMING HAS NOT BEEN DESIGNED FOR TILE, GRANITE, MARBLE OR OTHER MATERIALS HEAVIER THAN THE ABOVE LOADING UNLESS SPECIFICALLY NOTED ON PLANS..

DESIGN WIND LOADS:

- ULTIMATE WIND SPEED = 120 MPH
- EXPOSURE CATEGORY = B

ASSUMED SOIL BEARING CAPACITY = 2000 PSF

ASSUMED LATERAL SOIL PRESSURE = 45 PCF

FROST DEPTH = 12" MINIMUM

SEISMIC DESIGN CATEGORY = B


ENGINEERED LUMBER SHALL HAVE THE FOLLOWING MINIMUM DESIGN VALUES: • TJI 210 SERIES (SERIES AND SPACING PER PLANS) • LSL: E=1,550,000 PSI, F_B =2,325 PSI, F_V =310 PSI, F_C =900 PSI • LVL: E=2,000,000 PSI, F_B =2,600 PSI, F_V =285 PSI, F_C =750 PSI • PSL: E=2,000,000 PSI, F_B =2,900 PSI, F_V =290 PSI, F_C =625 PSI

THIS PLAN HAS BEEN DESIGNED PER THE 2018 EDITION OF THE NC RESIDENTIAL CODE WHERE FRAMING, FOUNDATION, OR OTHER STRUCTURAL ITEMS DO NOT COMPLY WITH THE PRESCRIPTIVE METHODS OF THE CODE, THOSE ITEMS HAVE BEEN DESIGNED IN ACCORDANCE WITH ACCEPTED ENGINEERING PRACTICE PER NCRC R301.1.3.



UNINHABITABLE ATTICS WITH LIMITED STORAGE = 20 PSF (WHERE SPECIFIED ON PLANS)

NC Firm #C-2101 SEAL SEAL 046096 WGINEER WGINEER

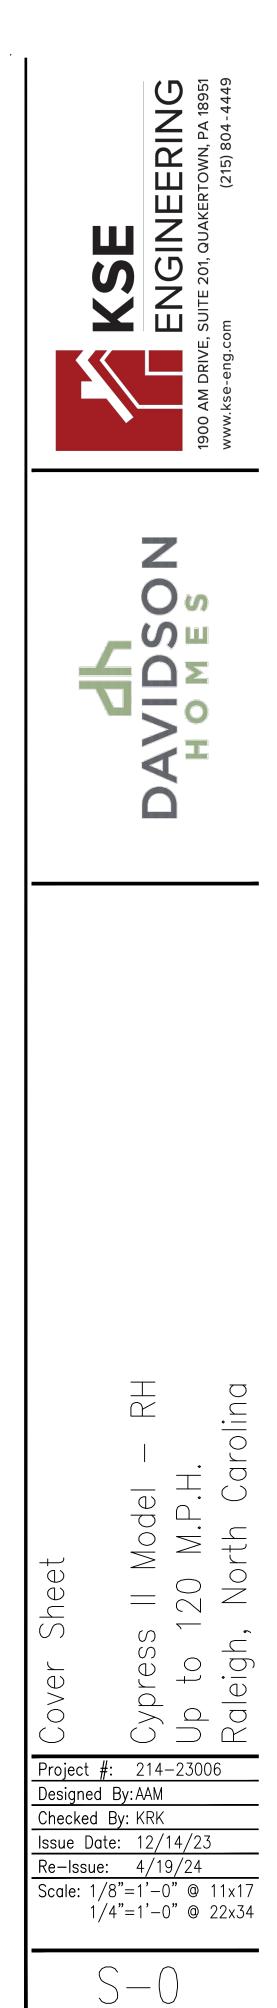

GENERAL STRUCTURAL NOTES:

- 1. THE DESIGN PROFESSIONAL WHOSE SEAL APPEARS ON THESE DRAWINGS IS THE STRUCTURAL ENGINEER OF RECORD (SER) FOR THIS PROJECT. THE SER BEARS THE RESPONSIBILITY OF THE PRIMARY STRUCTURAL ELEMENTS AND THE PERFORMANCE OF THIS STRUCTURE NO OTHER PARTY MAY REVISE, ALTER, OR DELETE ANY STRUCTURAL ASPECTS OF THESE CONSTRUCTION DOCUMENTS WITHOUT WRITTEN CONSENT OF KSE ENGINEERING, P.C. OR THE SER. FOR THE PURPOSES OF THESE CONSTRUCTION DOCUMENTS, THE SER AND KSE ENGINEERING SHALL BE CONSIDERED THE SAME ENTITY.
- THE STRUCTURE IS ONLY STABLE IN ITS COMPLETED FORM. THE CONTRACTOR SHALL PROVIDE ALL REQUIRED TEMPORARY BRACING DURING CONSTRUCTION TO STABILIZE THE STRUCTURE.
- 3. THE SER IS NOT RESPONSIBLE FOR CONSTRUCTION SEQUENCES, METHODS, OR TECHNIQUES IN CONNECTION WITH THE CONSTRUCTION OF THIS STRUCTURE. THE SER WILL NOT BE HELD RESPONSIBLE FOR THE CONTRACTOR'S FAILURE TO CONFORM TO THE CONTRACT DOCUMENTS, SHOULD ANY NON-CONFORMITIES OCCUR.
- 4. THE SER DOES NOT CERTIFY DIMENSIONAL ACCURACY OR ARCHITECTURAL LAYOUT INCLUDING ROOF GEOMETRY. THE SER ASSUMES NO LIABILITY FOR CHANGES MADE TO THESE PLANS BY OTHERS, OR FOR CONSTRUCTION METHODS, OR FOR ANY DEVIATION FROM THE PLANS. THE SER SHALL BE NOTIFIED PRIOR TO CONSTRUCTION IF ANY DISCREPANCIES ARE NOTED ON THE PLANS.
- 5. ANY STRUCTURAL ELEMENTS OR DETAILS NOT FULLY DEVELOPED ON THE CONSTRUCTION DRAWINGS SHALL BE COMPLETED UNDER THE DIRECTION OF A LICENSED PROFESSIONAL ENGINEER. THESE SHOP DRAWINGS SHALL BE SUBMITTED TO KSE ENGINEERING FOR REVIEW BEFORE ANY CONSTRUCTION BEGINS. THE SHOP DRAWINGS WILL BE REVIEWED FOR OVERALL COMPLIANCE AS IT RELATES TO THE STRUCTURAL DESIGN OF THIS PROJECT. VERIFICATION OF THE SHOP DRAWINGS FOR DIMENSIONS, OR FOR ACTUAL FIELD CONDITIONS, IS NOT THE RESPONSIBILITY OF THE SER OR KSE ENGINEERING, P.C.
- 6. VERIFICATION OF ASSUMED FIELD CONDITIONS IS NOT THE RESPONSIBILITY OF THE SER. THE CONTRACTOR SHALL VERIFY THE FIELD CONDITIONS FOR ACCURACY AND REPORT ANY DISCREPANCIES TO KSE ENGINEERING, P.C. BEFORE CONSTRUCTION BEGINS.
- 7. THE SER IS NOT RESPONSIBLE FOR ANY SECONDARY STRUCTURAL ELEMENTS OR NON-STRUCTURAL ELEMENTS, EXCEPT FOR THE ELEMENTS SPECIFICALLY NOTED ON THE STRUCTURAL DRAWINGS.
- 8. THIS STRUCTURE AND ALL CONSTRUCTION SHALL CONFORM TO ALL APPLICABLE SECTIONS OF THE BUILDING CODE AND ANY LOCAL CODES OR RESTRICTIONS.
- 9. DO NOT SCALE DRAWINGS. WRITTEN DIMENSIONS TAKE PRECEDENCE OVER SCALED DIMENSIONS. ALL DIMENSIONS ARE TO FACE OF STUD OR TO FACE OF FRAMING UNLESS OTHERWISE NOTED.
- 10. PROVIDE MOISTURE PROTECTION AND FLASHING PER ARCHITECTURAL DETAILS.

FOUNDATIONS

- 1. FOUNDATIONS SHALL BE CONSTRUCTED IN ACCORDANCE WITH CHAPTER 4 OF THE BUILDING CODE
- 2. CONTRACTOR IS SOLELY RESPONSIBLE FOR VERIFYING THE SUITABILITY OF THE SITE SOIL CONDITIONS AT THE TIME OF CONSTRUCTION. THE BUILDER SHALL FURNISH ANY AND ALL REPORTS RECEIVED FROM THE GEOTECHNICAL ENGINEER ON THE STUDY OF THE PROPOSED SITE TO THE DESIGNER, STRUCTURAL ENGINEER, AND GENERAL CONTRACTOR.
- . MAXIMUM DEPTH OF UNBALANCED FILL AGAINST MASONRY WALLS TO BE AS SPECIFIED IN THE BUILDING CODE.
- 4. THE SER HAS NOT PERFORMED A SUBSURFACE INVESTIGATION. VERIFICATION OF THE ASSUMED VALUE IS THE RESPONSIBILITY OF THE OWNER OR THE CONTRACTOR. SHOULD ANY ADVERSE SOIL CONDITION BE ENCOUNTERED, THE SER MUST BE CONTACTED BEFORE PROCEEDING.
- 5. THE BOTTOM OF ALL FOOTINGS SHALL EXTEND BELOW THE FROST LINE FOR THE REGION IN WHICH THE STRUCTURE IS TO BE CONSTRUCTED, BUT NOT LESS THAN A MINIMUM OF 12" BELOW GRADE. ALL FOOTINGS TO HAVE A MINIMUM PROJECTION OF 2" ON EACH SIDE OF FOUNDATION WALLS. MAXIMUM FOOTING PROJECTION SHALL NOT EXCEED THE THICKNESS OF THE FOOTING.
- 6. WOOD SILL PLATES SHALL BE ANCHORED TO THE FOUNDATION WITH 1/3" ANCHOR BOLTS WITH MINIMUM 7" EMBEDMENT, SPACED A MAXIMUM of 6'-0" O.C. INSTALL MINIMUM 2 ANCHOR BOLTS PER SECTION, 12" MASONRY MAXIMUM FROM CORNERS. $\frac{1}{2}$ " DIAMETER x 8" LONG SIMPSON TITEN HD OR USP SCREW-BOLT+ SCREWS MAY BE SUBSTITUTED ON A 1 FOR 1 BASIS.
- 7. ANY FILL SHALL BE PLACED UNDER THE DIRECTION OR RECOMMENDATION OF A LICENSED PROFESSIONAL ENGINEER. THE RESULTING SOIL SHALL BE COMPACTED TO A MINIMUM OF 95% MAXIMUM DRY DENSITY.
- 8. EXCAVATIONS OF FOOTINGS SHALL BE LINED TEMPORARILY WITH A 6 MIL POLYETHYLENE MEMBRANE IF PLACEMENT OF CONCRETE DOES NOT OCCUR WITHIN 24 HOURS OF EXCAVATION.
- 9. NO CONCRETE SHALL BE PLACED AGAINST ANY SUBGRADE CONTAINING WATER, ICE, FROST, OR LOOSE MATERIAL.
- 10. PROVIDE FOUNDATION WATERPROOFING AND DRAIN WITH POSITIVE SLOPE TO OUTLET AS REQUIRED BY SITE CONDITIONS (SEE ARCHITECTURAL PLANS AND DETAILS).
- 11. NONE OF THE FOUNDATION DESIGNS IN THESE DOCUMENTS ARE SUITABLE FOR INSTALLATION IN SHRINK/SWELL CONDITIONS. REFER TO GEOTECHNICAL ENGINEER FOR APPROPRIATE DESIGN.
- 12. LOTS SHALL BE GRADED TO DRAIN SURFACE WATER AWAY FROM FOUNDATION WALLS. THE GRADE SHALL FALL A MINIMUM OF 6 INCHES WITHIN THE FIRST TEN FEET.
- 13. CRAWL SPACE TO BE GRADED LEVEL AND CLEAR OF ALL DEBRIS.
- 14. PROVIDE MINIMUM 6 MIL APPROVED VAPOR BARRIER. ALL JOINTS TO BE LAPPED MINIMUM 12" AND SEALED.

CONCRETE & REINFORCING

- wood framing 1. SOLID SAWN WOOD FRAMING MEMBERS SHALL CONFORM TO THE CONCRETE SHALL HAVE A NORMAL WEIGHT AGGREGATE AND A MINIMUM SPECIFICATIONS LISTED IN THE LATEST EDITION OF THE "NATIONAL COMPRESSIVE STRENGTH (f'c) = 3,000 PSI MINIMUM AT 28 DAYS PER DESIGN SPECIFICATION FOR WOOD CONSTRUCTION": (NDS). UNLESS CODE (VARIES W/ WEATHER), UNLESS OTHERWISE NOTED ON THE PLAN. OTHERWISE NOTED, ALL WOOD FRAMING MEMBERS ARE DESIGNED TO CONCRETE SHALL BE PROPORTIONED, MIXED, AND PLACED IN BE: ACCORDANCE WITH THE LATEST EDITIONS OF ACI 318: "BUILDING CODE SPRUCE-PINE-FIR (SPF) WITH THE FOLLOWING MINIMUM DESIGN REQUIREMENTS FOR REINFORCED CONCRETE" AND ACI 301: VALUES: E=1,400,000 PSI, $F_{b}=875$ PSI, $F_{v}=135$ PSI "SPECIFICATIONS FOR STRUCTURAL CONCRETE FOR BUILDINGS" 1.1. FRAMING: SPF #2. AIR ENTRAINED CONCRETE MUST BE USED FOR ALL STRUCTURAL 1.2. PLATES: SPF #2. ELEMENTS EXPOSED TO FREEZE/THAW CYCLES AND DEICING CHEMICALS. 1.3. STUDS: SPF STUD GRADE. AIR ENTRAINMENT AMOUNTS (IN PERCENT) SHALL BE WITHIN -1% TO 2. WALL STUD SPACING, (MAXIMUM 10' NOMINAL PLATE HEIGHT): +2% OF 5% FOR FOOTINGS AND EXTERIOR SLABS.
- 1. CONCRETE DESIGN BASED ON ACI 318 AND ACI 318.1 OR ACI 332.
- NO ADMIXTURES SHALL BE ADDED TO ANY STRUCTURAL CONCRETE WITHOUT WRITTEN PERMISSION OF THE SER. WATER ADDED TO CONCRETE ON SITE SHALL NOT EXCEED THAT ALLOWED BY THE MIX DESIGN.
- 5. CONCRETE SLABS-ON-GRADE SHALL BE CONSTRUCTED IN ACCORDANCE WITH ACI 302.1R: "GUIDE FOR CONCRETE SLAB AND SLAB CONSTRUCTION"
- 6. CONTROL OR SAW CUT JOINTS (CUT OR TOOLED) SHALL BE SPACED IN INTERIOR SLABS-ON-GRADE AT A MAXIMUM OF 15'-0" O.C. AND IN EXTERIOR SLABS-ON-GRADE AT A MAXIMUM OF 10'-0" UNLESS OTHERWISE NOTED. CARE SHALL BE TAKEN TO AVOID RE-ENTRANT CORNERS.
- CONTROL OR SAW CUT JOINTS SHALL BE PRODUCED USING CONVENTIONAL CUT OR TOOLED PROCESSES WITHIN 4 TO 12 HOURS AFTER THE SLAB HAS BEEN FINISHED.
- 8. ALL WELDED WIRE FABRIC (W.W.F.) FOR CONCRETE SLABS-ON-GRADE SHALL BE PLACED AT MID-DEPTH OF SLAB. THE W.W.F. SHALL BE SECURELY SUPPORTED DURING THE CONCRETE POUR. FIBROUS CONCRETE REINFORCEMENT, OR POLYPROPYLENE FIBERS MAY BE USED IN LIEU OF W.W.F. APPLICATION OF POLYPROPYLENE FIBERS PER CUBIC YARD OF CONCRETE SHALL BE PER MANUFACTURER AND COMPLY WITH ASTM C1116, ANY LOCAL BUILDING CODE REQUIREMENTS AND SHALL MEET OR EXCEED CURRENT INDUSTRY STANDARD
- POLYPROPYLENE REINFORCING TO BE 100% VIRGIN, CONTAINING NO REPROCESSED OLEFIN MATERIALS AND SPECIFICALLY MANUFACTURED FOR USE AS CONCRETE SECONDARY REINFORCEMENT
- 10. STEEL REINFORCING BARS SHALL BE NEW BILLET STEEL CONFORMING TO ASTM A615, GRADE 60.
- 11. DETAILING, FABRICATION, AND PLACEMENT OF REINFORCING STEEL SHALL BE IN ACCORDANCE WITH THE LATEST EDITION OF ACI 315: "MANUAL OF STANDARD PRACTICE FOR DETAILING CONCRETE STRUCTURES".
- 12. HORIZONTAL FOOTING AND WALL REINFORCEMENT SHALL BE CONTINUOUS AND SHALL HAVE 90° BENDS, OR CORNER BARS WITH
- THE SAME SIZE/SPACING AS THE HORIZONTAL REINFORCEMENT. 13. PROVIDE REINFORCEMENT LAP AS NOTED BELOW, UNLESS NOTED OTHERWISE:
 - #4 BARS 30" LENGTH
 - #5 BARS 38" LENGTH
 - #6 BARS 45" LENGTH
- 14. WHERE REINFORCING DOWELS ARE REQUIRED, THEY SHALL BE EQUIVALENT IN SIZE AND SPACING TO THE VERTICAL REINFORCEMENT. THE DOWEL SHALL EXTEND 48 BAR DIAMETERS VERTICALLY AND 20 BAR DIAMETERS INTO THE FOOTING. SEE KSE FOUNDATION DETAILS.
- 15. WHERE FOOTING BOTTOMS ARE TO BE STEPPED AT SLOPING GRADE CONDITIONS, PROVIDE CONTINUOUS REINFORCING WITH Z BARS (TO MATCH FOOTING REINFORCING) AS REQUIRED.
- 16. BAR SUPPORT ACCESSORIES SHALL BE PROVIDED IN ACCORDANCE WITH THE LATEST ACI MANUAL OF STANDARD PRACTICE FOR DETAILING REINFORCED CONCRETE STRUCTURES, EXCEPT THAT REINFORCING SHALL BE CHAIRED ON THE BOTTOM AND/OR THE SIDES ON BOLSTERS SPACED NOT MORE THAN 4 FEET ON CENTER. NO ROCKS, CMU, CLAY TILE, OR BRICK SHALL BE USED TO SUPPORT REINFORCING.
- 17. FOR GRADE SUPPORTED SLABS, SLAB REINFORCING SHALL BE HELD IN PLACE BY BAR SUPPORTS AND ACCESSORIES AS DESCRIBED IN THE CRSI MANUAL OF STANDARD PRACTICE. BAR SUPPORTS SHALL BE SPACED A MAXIMUM OF 4'-0" O.C. BOTH WAYS IN STRAIGHT LINES ON THE MESH GRID.

- 1. ALL MASONRY SHALL CONFORM TO ASTM C-90, F'_m =1500 PSI. ALL BRICK SHALL CONFORM TO ASTM C-216, F'm=1500 PSI. ALL MORTAR SHALL BE TYPE 'S' (TYPE 'M' BELOW GRADE) AND CONFORM TO ASTM C-270. COARSE GROUT SHALL CONFORM TO ASTM C-476 WITH A MAXIMUM AGGREGATE SIZE OF $\frac{3}{8}$ " and a minimum compressive strength of 2,000 PSI.
- 2. ALL MASONRY WORK SHALL BE IN ACCORDANCE WITH "BUILDING CODE REQUIREMENTS FOR MASONRY STRUCTURES" ACI 530/ASCE 5/TMS 402 AND "SPECIFICATIONS FOR MASONRY STRUCTURES" ACI 530.1/ ASCE 6/TMS 602.
- THE UNSUPPORTED HEIGHT OF SOLID MASONRY PIERS SHALL NOT EXCEED TEN TIMES THEIR LEAST DIMENSION. UNFILLED HOLLOW PIERS MAY BE USED IF THE UNSUPPORTED HEIGHT IS NOT MORE THAN FOUR TIMES THEIR LEAST DIMENSION.
- 4. EACH CRAWL SPACE PIER SHALL BEAR IN THE MIDDLE THIRD OF ITS RESPECTIVE FOOTING AND EACH GIRDER SHALL BEAR IN THE MIDDLE THIRD OF THE PIERS. PILASTERS TO BE BONDED TO PERIMETER FOUNDATION WALL.
- TOP COURSE OF MASONRY SHALL BE GROUTED SOLID.
- 6. HORIZONTAL WALL JOINT REINFORCEMENT SHALL BE STANDARD 9 GAGE GALVANIZED LADDER OR TRUSS TYPE SPACED AT 16" O.C., UNLESS SHOWN OTHERWISE ON THE DRAWINGS.
- SPLICED WIRE REINFORCEMENT SHALL BE LAPPED AT LEAST 6" AND CONTAIN AT LEAST ONE CROSS WIRE OF EACH PIECE OF REINFORCEMENT WITHIN THE 6". LAP WITH STANDARD 'T' AND 'L' SHAPED PIECES AT INTERSECTIONS AND CORNERS.

- 1 & 2 STORY EXTERIOR AND INTERIOR BEARING: 2x4 @ 16" O.C. OR 2x6 @ 24" O.C., U.N.O. BOTTOM OF 3 STORIES EXTERIOR AND INTERIOR BEARING: 2x6 @ 16" O.C., U.N.O.
- INTERIOR NON-BEARING: 2x @ 24" O.C., U.N.O.
- 3. ALL LUMBER EXPOSED TO WEATHER OR IN CONTACT WITH CONCRETE SHALL BE PRESERVATIVE TREATED SOUTHERN YELLOW PINE #2 OR BETTER.
- 4. ANCHOR SILL PLATES IN ACCORDANCE W/ GENERAL STRUCTURAL NOTES. 5. ALL BEAMS SPECIFIED ARE MINIMUM SIZES ONLY. LARGER MEMBERS MAY BE SUBSTITUTED AS NEEDED FOR EASE OF CONSTRUCTION.
- 6. NAILS SHALL BE COMMON WIRE NAILS UNLESS OTHERWISE NOTED. 7. BOLT HOLES AND LEAD HOLES FOR LAG SCREWS SHALL BE IN ACCORDANCE WITH NDS SPECIFICATIONS.
- 8. INDIVIDUAL STUDS FORMING A COLUMN SHALL BE ATTACHED WITH (2) ROWS 10d NAILS @ 6" O.C. STAGGERED. THE STUD COLUMN SHALL BE FULLY BLOCKED AT ALL FLOOR LEVELS TO ENSURE PROPER LOAD TRANSFER. WALL SHEATHING SHALL BE NAILED TO EDGE OF EACH STUD.
- 9. FACE NAIL ALL MULTI-PLY BEAMS AND HEADERS WITH (2) ROWS 16d COMMON NAILS @ 16" O.C., STAGGERED, OR PER MANUFACTURER'S SPECIFICATIONS FOR ENGINEERED LUMBER. APPLY NAILING FROM BOTH FACES FOR (3) OR MORE PLIES.
- 10. FASTEN 4-PLY BEAMS WITH (1) $\frac{1}{2}$ " DIAMETER THROUGH BOLT W/ NUTS AND WASHERS AT 12" O.C. STAGGERED TOP AND BOTTOM, $1\frac{1}{2}$ " MINIMUM EDGE DISTANCE. (UNLESS OTHERWISE NOTED)
- 11. ALL BEAMS AND HEADERS SHALL HAVE (1)2x JACK STUD & (1)2x KING STUD UNLESS OTHERWISE NOTED. THE NUMBER OF STUDS INDICATED ON PLANS ARE THE TOTAL NUMBER OF JACK STUDS REQUIRED, UNLESS OTHERWISE NOTED.
- 12. PROVIDE KING STUDS AT EACH END OF HEADERS AS NOTED BELOW. (1) STUD UP TO 6' OPENING
- (2) STUDS UP TO 8' OPENING
- (3) STUDS UP TO 9' OPENING 13. ALL BEAMS TO BE CONTINUOUSLY SUPPORTED LATERALLY AND SHALL BEAR FULL WIDTH ON THE SUPPORTING WALLS OR COLUMNS INDICATED
- WITH A MINIMUM OF TWO STUDS, UNLESS OTHERWISE NOTED. ALL BEAM SPLICES SHALL OCCUR OVER SUPPORTS.
- 14. SOLID BLOCKING TO BE PROVIDED AT ALL POINT LOADS THROUGH FLOOR LEVELS TO THE FOUNDATION OR TO OTHER STRUCTURAL COMPONENTS. 15. ALL LUMBER SPECIFIED ON DRAWINGS IS INTENDED FOR DRY USE ONLY
- (MOISTURE CONTENT <19%) UNLESS OTHERWISE NOTED
- 16. ALL WATERPROOFING AND FIRE SAFETY SYSTEMS ARE THE RESPONSIBILITY OF THE CONTRACTOR AND ARE TO BE DESIGNED AND DETAILED BY OTHERS.
- 17. ANY WOOD FRAME INTERIOR BEARING WALL STUDS THAT HAVE HOLES IN THE CENTER OF THE STUD UP TO 1" DIAMETER SHALL HAVE STUD PROTECTION SHIELDS. ALL HOLES OVER 1" IN DIAMETER FOR PLUMBING LINES, ETC. SHALL BE REPAIRED WITH SIMPSON HSS2 OR USP STS1 STUD SHOES, TYPICAL, UNLESS OTHERWISE NOTED.
- 18. BEARING WALLS SHALL BE SHEATHED ON NOT LESS THAN ONE SIDE WITH OSB OR GYPSUM BOARD. BRIDGING SHALL BE INSTALLED NOT GREATER THAN 4 FEET APART MEASURED VERTICALLY FROM EITHER END OF THE STUD IN LIEU OF SHEATHING.
- 19. DIAGONAL BRACING SHALL BE INSTALLED AT EACH END OF BASEMENT BEARING WALLS AND NOT MORE THAN 20' ON CENTER.
- EXTERIOR WOOD FRAMED DECKS:
- DECKS ARE TO BE FRAMED IN ACCORDANCE WITH APPLICABLE BUILDING CODES AND AS REFERENCED ON THE STRUCTURAL PLANS, EITHER THROUGH CODE REFERENCES OR CONSTRUCTION DETAILS. 2. PRESERVATIVE TREATED WOOD FRAMING TO BE SOUTHERN YELLOW
- PINE #2 OR BETTER. 3. GUARD RAILS REQUIRED AT DECKS. DESIGN BY OTHERS TO MEET
- MINIMUM CODE REQUIREMENTS. 4. PROVIDE DECK LATERAL LOAD AND BRACING CONNECTIONS PER BUILDING CODE.
- RAFTER FRAMED ROOF CONSTRUCTION:
- PROVIDE 2x4x4'-0" RAFTER TIES AT 48" O.C.
- 2. RAFTERS SHALL BE SUPPORTED BY PURLINS AND PURLIN BRACES AS SHOWN ON THE PLAN. PURLIN BRACES SHALL NOT BEAR ON ANY CEILING JOIST, STRONGBACK OR HEADER UNLESS SPECIFICALLY SHOWN ON PLAN. RAFTERS MAY BE SPLICED AT PURLIN LOCATIONS.
- 3. CEILING JOISTS SHALL HAVE LATERAL SUPPORT W/ 1x4 FLAT BRACING ON TOP EDGE OF JOIST AT LOOSE JOIST ENDS (WHERE JOISTS NOT FASTENED TO RAFTERS) OR FULL DEPTH BLOCKING. FASTEN END OF BRACING TO RAFTER OR GABLE END FRAMING.
- 4. FASTEN RAFTER AND CEILING JOIST WITH (6) 12d NAILS UNLESS OTHERWISE NOTED.
- 5. PROVIDE VERTICAL 2x6 STRONGBACKS AT CEILING JOISTS @ 8'-0" O.C. TIE STRONGBACK ENDS TO GABLE STUDS OR RAFTERS WHERE POSSIBLE. PROVIDE BLOCKING BETWEEN TOP PLATES AND STRONGBACKS. PROVIDE 2x4 FLAT FASTENED TO EACH JOIST WITH (2) 12d NAILS. FASTEN STRONGBACK TO 2x4 FLAT WITH 12d NAILS @ 12" O.C. AND FASTENED TO EACH JOIST WITH (1) 12d TOENAIL.

WOOD TRUSSES (FLOOR & ROOF)

- 1. THE WOOD TRUSS MANUFACTURER/FABRICATOR IS RESPONSIBLE FOR THE DESIGN OF THE WOOD TRUSSES. SUBMIT SEALED SHOP DRAWINGS AND SUPPORTING CALCULATIONS TO THE SER FOR REVIEW PRIOR TO FABRICATION. THE SER SHALL HAVE A MINIMUM OF (5) DAYS FOR REVIEW. THE REVIEW BY THE SER SHALL BE FOR OVERALL COMPLIANCE OF THE DESIGN DOCUMENTS. THE SER SHALL ASSUME NO RESPONSIBILITY FOR THE CORRECTNESS OF THE STRUCTURAL DESIGN FOR THE WOOD TRUSSES.
- 2. THE WOOD TRUSSES SHALL BE DESIGNED FOR ALL REQUIRED LOADINGS AS SPECIFIED IN THE LOCAL BUILDING CODE, THE ASCE STANDARD "MINIMUM DESIGN LOADS FOR BUILDINGS AND OTHER STRUCTURES." (ASCE 7), AND THE LOADING REQUIREMENTS SHOWN ON THESE SPECIFICATIONS. THE TRUSS DRAWINGS SHALL BE COORDINATED WITH ALL OTHER CONSTRUCTION DOCUMENTS AND PROVISIONS PROVIDED FOR LOADS SHOWN ON THESE DRAWINGS INCLUDING BUT NOT LIMITED TO HVAC EQUIPMENT, PIPING, AND ARCHITECTURAL FIXTURES ATTACHED TO THE TRUSSES.
- 3. THE TRUSSES SHALL BE DESIGNED, FABRICATED, AND ERECTED IN ACCORDANCE WITH THE LATEST EDITION OF THE ANSI/TPI 1: "NATIONAL DESIGN STANDARD FOR METAL PLATE CONNECTED WOOD TRUSS CONSTRUCTION"
- 4. THE TRUSS MANUFACTURER SHALL PROVIDE ADEQUATE BRACING INFORMATION IN ACCORDANCE WITH "BUILDING COMPONENT SAFETY INFORMATION GUIDE TO GOOD PRACTICE FOR HANDLING, INSTALLING, RESTRAINING & BRACING OF METAL PLATE CONNECTED WOOD TRUSSES" (BCSI). THIS BRACING, BOTH TEMPORARY AND PERMANENT, SHALL BE SHOWN ON THE SHOP DRAWINGS. ALSO, THE SHOP DRAWINGS SHALL SHOW THE REQUIRED ATTACHMENTS FOR THE TRUSSES.
- 5. THE CONTRACTOR IS RESPONSIBLE FOR INSTALLING TEMPORARY BRACING AND SHORING FOR THE FLOOR AND ROOF TRUSSES AS REQUIRED DURING CONSTRUCTION. AT A MINIMUM, CONTRACTOR SHALL FOLLOW THE REQUIREMENTS OF THE LATEST BCSI. THE CONTRACTOR SHALL KEEP A COPY OF THE BCSI SUMMARY SHEETS ON SITE.
- THE CONTRACTOR IS RESPONSIBLE FOR INSTALLING ALL PERMANENT 0.C. TRUSS BRACING SHOWN IN THE STRUCTURAL DRAWINGS AND IN THE TRUSS DESIGNS. ALL CONTINUOUS LATERAL BRACING OF WEBS REQUIRES MFCHANICAL FASTENERS: BRACES. REFER TO BCSI SUMMARY SHEET B3 FOR TYPES OF DIAGONAL BRACES TO PROVIDE AT EACH CONTINUOUS LATERAL BRACE LINE. SUCH OR APPROVED EQUIVALENT. DIAGONAL BRACES SHALL NOT BE SPACED MORE THAN 20 FEET O.C. 2. ALL HARDWARE AND FASTENERS IN CONTACT WITH PRESERVATIVE DIAGONAL BRACES SHALL BE FASTENED TO EACH TRUSS WEB WITH A PRESSURE TREATED LUMBER SHALL BE HOT DIPPED GALVANIZED IN MINIMUM OF TWO 10d FACE NAILS. WHERE CONTINUOUS LATERAL ACCORDANCE WITH ASTM A 153, G-185. BRACING CANNOT BE INSTALLED, DUE TO A MINIMUM OF THREE 3. MANY OF THE NEW PRESSURE TREATED WOODS USE CHEMICALS ADJACENT TRUSSES NOT BEING IDENTICAL, THE CONTRACTOR SHALL THAT ARE CORROSIVE TO STEEL. IT IS THE CONTRACTOR'S COORDINATE WITH THE TRUSS SPECIALTY ENGINEER/MANUFACTURER TO RESPONSIBILITY TO VERIFY THE TYPE OF WOOD TREATMENT AND DETERMINE WHAT TYPE OF ALTERNATE BRACE (I.E., T OR L BRACE, ETC.) SELECT APPROPRIATE CONNECTORS THAT WILL RESIST THE IS REQUIRED. APPLICABLE CORROSIVE CHEMICALS.
- 7. ANY CHORDS OR TRUSS WEBS SHOWN ON THESE DRAWINGS HAVE BEEN SHOWN AS A REFERENCE ONLY. THE FINAL DESIGN OF THE TRUSSES SHALL BE PER THE MANUFACTURER.
- 8. TRUSS LAYOUT AND PLACEMENT BY MANUFACTURER TO COINCIDE WITH THE SUPPORT LOCATIONS SHOWN ON THE SEALED STRUCTURAL DRAWINGS. TRUSS PROFILES TO BE SEALED BY THE TRUSS MANUFACTURER. TRUSS PLANS TO BE COORDINATED WITH THE SEALED STRUCTURAL DRAWINGS.
- 9. TRUSS MANUFACTURER TO PROVIDE REQUIRED UPLIFT CONNECTORS FOR ALL TRUSSES
- 10. PROVIDE SIMPSON H2.5A, USP RT7 OR EQUIVALENT AT EACH TRUSS TO TOP PLATE CONNECTION, UNLESS OTHERWISE NOTED.


WOOD STRUCTURAL PANELS:

- 1. FABRICATION AND PLACEMENT OF STRUCTURAL WOOD SHEATHING SHALL BE IN ACCORDANCE WITH THE APA DESIGN/CONSTRUCTION GUIDE "RESIDENTIAL AND COMMERCIAL," AND ALL OTHER APPLICABLE APA STANDARDS.
- 2. ALL REQUIRED WOOD SHEATHING SHALL BEAR THE MARK OF THE APA.
- 3. WOOD WALL SHEATHING SHALL COMPLY WITH THE REQUIREMENTS OF LOCAL BUILDING CODES FOR THE APPROPRIATE STATE AS INDICATED ON THESE DRAWINGS. REFER TO WALL BRACING NOTES IN PLAN SET FOR MORE INFORMATION. EXTERIOR WALLS TO BE FULLY SHEATHED USING $\frac{7}{16}$ " OSB OR PLYWOOD MINIMUM. AT BRACED WALL PANELS, PROVIDE BLOCKING AT ALL SHEET EDGES NOT FALLING ON STUDS OR PLATES.
- ROOF SHEATHING SHALL BE APA RATED SHEATHING EXPOSURE 1 OR 2. ROOF SHEATHING SHALL BE CONTINUOUS OVER TWO SUPPORTS MINIMUM AND ATTACHED TO ITS SUPPORTING ROOF FRAMING WITH 8d NAILS AT 6" O.C. AT PANEL EDGES AND AT 12" O.C. IN PANEL FIELD UNLESS OTHERWISE NOTED ON THE PLANS. SHEATHING SHALL BE APPLIED WITH THE LONG DIRECTION PERPENDICULAR TO FRAMING. SHEATHING SHALL HAVE A SPAN RATING CONSISTENT WITH THE FRAMING SPACING. PROVIDE SUITABLE EDGE SUPPORT BY USE OF PLYWOOD CLIPS OR LUMBER BLOCKING UNLESS OTHERWISE NOTED. PANEL END JOINTS SHALL OCCUR OVER FRAMING. ROOF SHEATHING TO BE $\frac{7}{16}$ " OSB MINIMUM.
- WOOD FLOOR SHEATHING SHALL BE APA RATED SHEATHING EXPOSURE 1 OR 2. ATTACH SHEATHING TO ITS SUPPORTING FRAMING WITH (1) 10d NAIL AT 6" O.C. AT PANEL EDGES AND AT 12" O.C. IN PANEL FIELD UNLESS OTHERWISE NOTED ON THE PLANS. SHEATHING SHALL BE APPLIED PERPENDICULAR TO FRAMING. SHEATHING SHALL HAVE A SPAN RATING CONSISTENT WITH THE FRAMING SPACING. PROVIDE SUITABLE EDGE SUPPORT BY USE OF T&G PLYWOOD OR LUMBER BLOCKING UNLESS OTHERWISE NOTED. PANEL END JOINTS SHALL OCCUR OVER FRAMING.
- 6. SHEATHING SHALL HAVE A $\frac{1}{6}$ " GAP AT PANEL ENDS AND EDGES AS RECOMMENDED IN ACCORDANCE WITH THE APA.

STRUCTURAL FIBERBOARD PANELS:

- STRUCTURAL FIBERBOARD SHEATHING SHALL ONLY BE USED WHERE SPECIFICALLY NOTED ON THE STRUCTURAL PLANS.
- 2. FABRICATION AND PLACEMENT OF STRUCTURAL FIBERBOARD SHEATHING SHALL BE IN ACCORDANCE WITH THE APPLICABLE AFA STANDARDS.
- FIBERBOARD WALL SHEATHING SHALL COMPLY WITH THE REQUIREMENTS OF LOCAL BUILDING CODES FOR THE APPROPRIATE STATE AS INDICATED ON THESE DRAWINGS. REFER TO WALL BRACING NOTES IN PLAN SET FOR MORE INFORMATION.
- 4. SHEATHING SHALL HAVE A 1/8" GAP AT PANEL ENDS AND EDGES AS RECOMMENDED IN ACCORDANCE WITH THE AFA.
- STRUCTURAL STEEL
- STRUCTURAL STEEL SHALL BE FABRICATED AND ERECTED IN ACCORDANCE WITH THE AMERICAN INSTITUTE OF STEEL CONSTRUCTION "CODE OF STANDARD PRACTICE FOR STEEL BUILDINGS AND BRIDGES" AND OF THE MANUAL OF STEEL CONSTRUCTION "LOAD RESISTANCE FACTOR DESIGN" LATEST EDITIONS.
- 2. ALL STEEL SHALL HAVE A MINIMUM YIELD STRESS (F_v) of 50 KSI UNLESS OTHERWISE NOTED. 3. WELDING SHALL CONFORM TO THE LATEST EDITION OF THE
- AMERICAN WELDING SOCIETY'S STRUCTURAL WELDING CODE AWA D1.1. ELECTRODES FOR SHOP AND FIELDING WELDING SHALL BE CLASS E70XX. ALL WELDING SHALL BE PERFORMED BY A CERTIFIED WELDER PER THE ABOVE STANDARDS.
- 4. ALL STEEL BEAMS TO BE SUPPORTED AT EACH END WITH A MINIMUM BEARING LENGTH OF $3\frac{1}{2}$ " and full flange width unless OTHERWISE NOTED. BEAMS MUST BE ATTACHED AT EACH END WITH A MINIMUM OF FOUR 16d NAILS OR (2) $\frac{1}{2}$ " x 4" LAG SCREWS UNLESS OTHERWISE NOTED.
- INSTALL 2x WOOD PLATE ON TOP OF STEEL BEAMS, RIPPED TO MATCH BEAM WIDTH. FASTEN PLATE TO BEAM W/ HILTI X-DNI 52 P8 PINS AT 12" O.C. STAGGERED OR $\frac{1}{2}$ " DIAMETER BOLTS AT 24"

1. ALL METAL HARDWARE AND FASTENERS TO BE SIMPSON STRONG-TIE

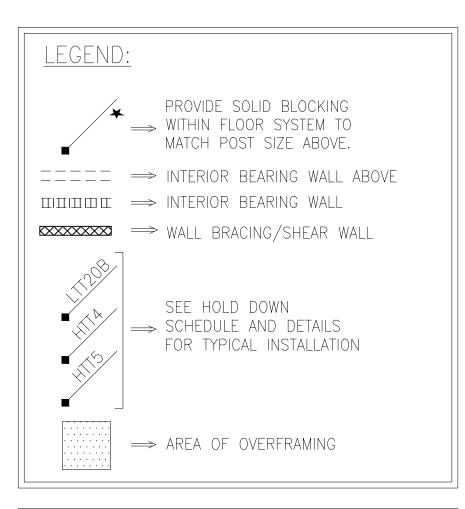

BRICK	VENEER LINTEL SC	HEDULE			
SPAN	LINTEL SIZE	END BEARING			
UP TO 3'-0"	3½"×3½"×¼"	4"			
UP TO 6'-3"	5"x 3½"x5⁄16" L.L.V.	8"			
UP TO 9'-6"	6"x3½"x5⁄16" L.L.V.	12"			
LINTELS ARE NOT DESIGNED TO BE BOLTED TO HEADERS UNLESS SPECIFIED ON UNIT PLANS. SPANS OVER 4'-0" SHALL BE SHORED UP UNTIL CURED.					


NC Firm #C-2101







U и SШ


Notes		Carolina
ral Structural	o 120 M.P.H.	gh, North
Project #: Designed B		Ralei
<u>Checked By</u> Issue Date: <u>Re-Issue:</u> Scale: 1/8' 1/4'	3/6/23	11x17 22x34
S	-0.1	

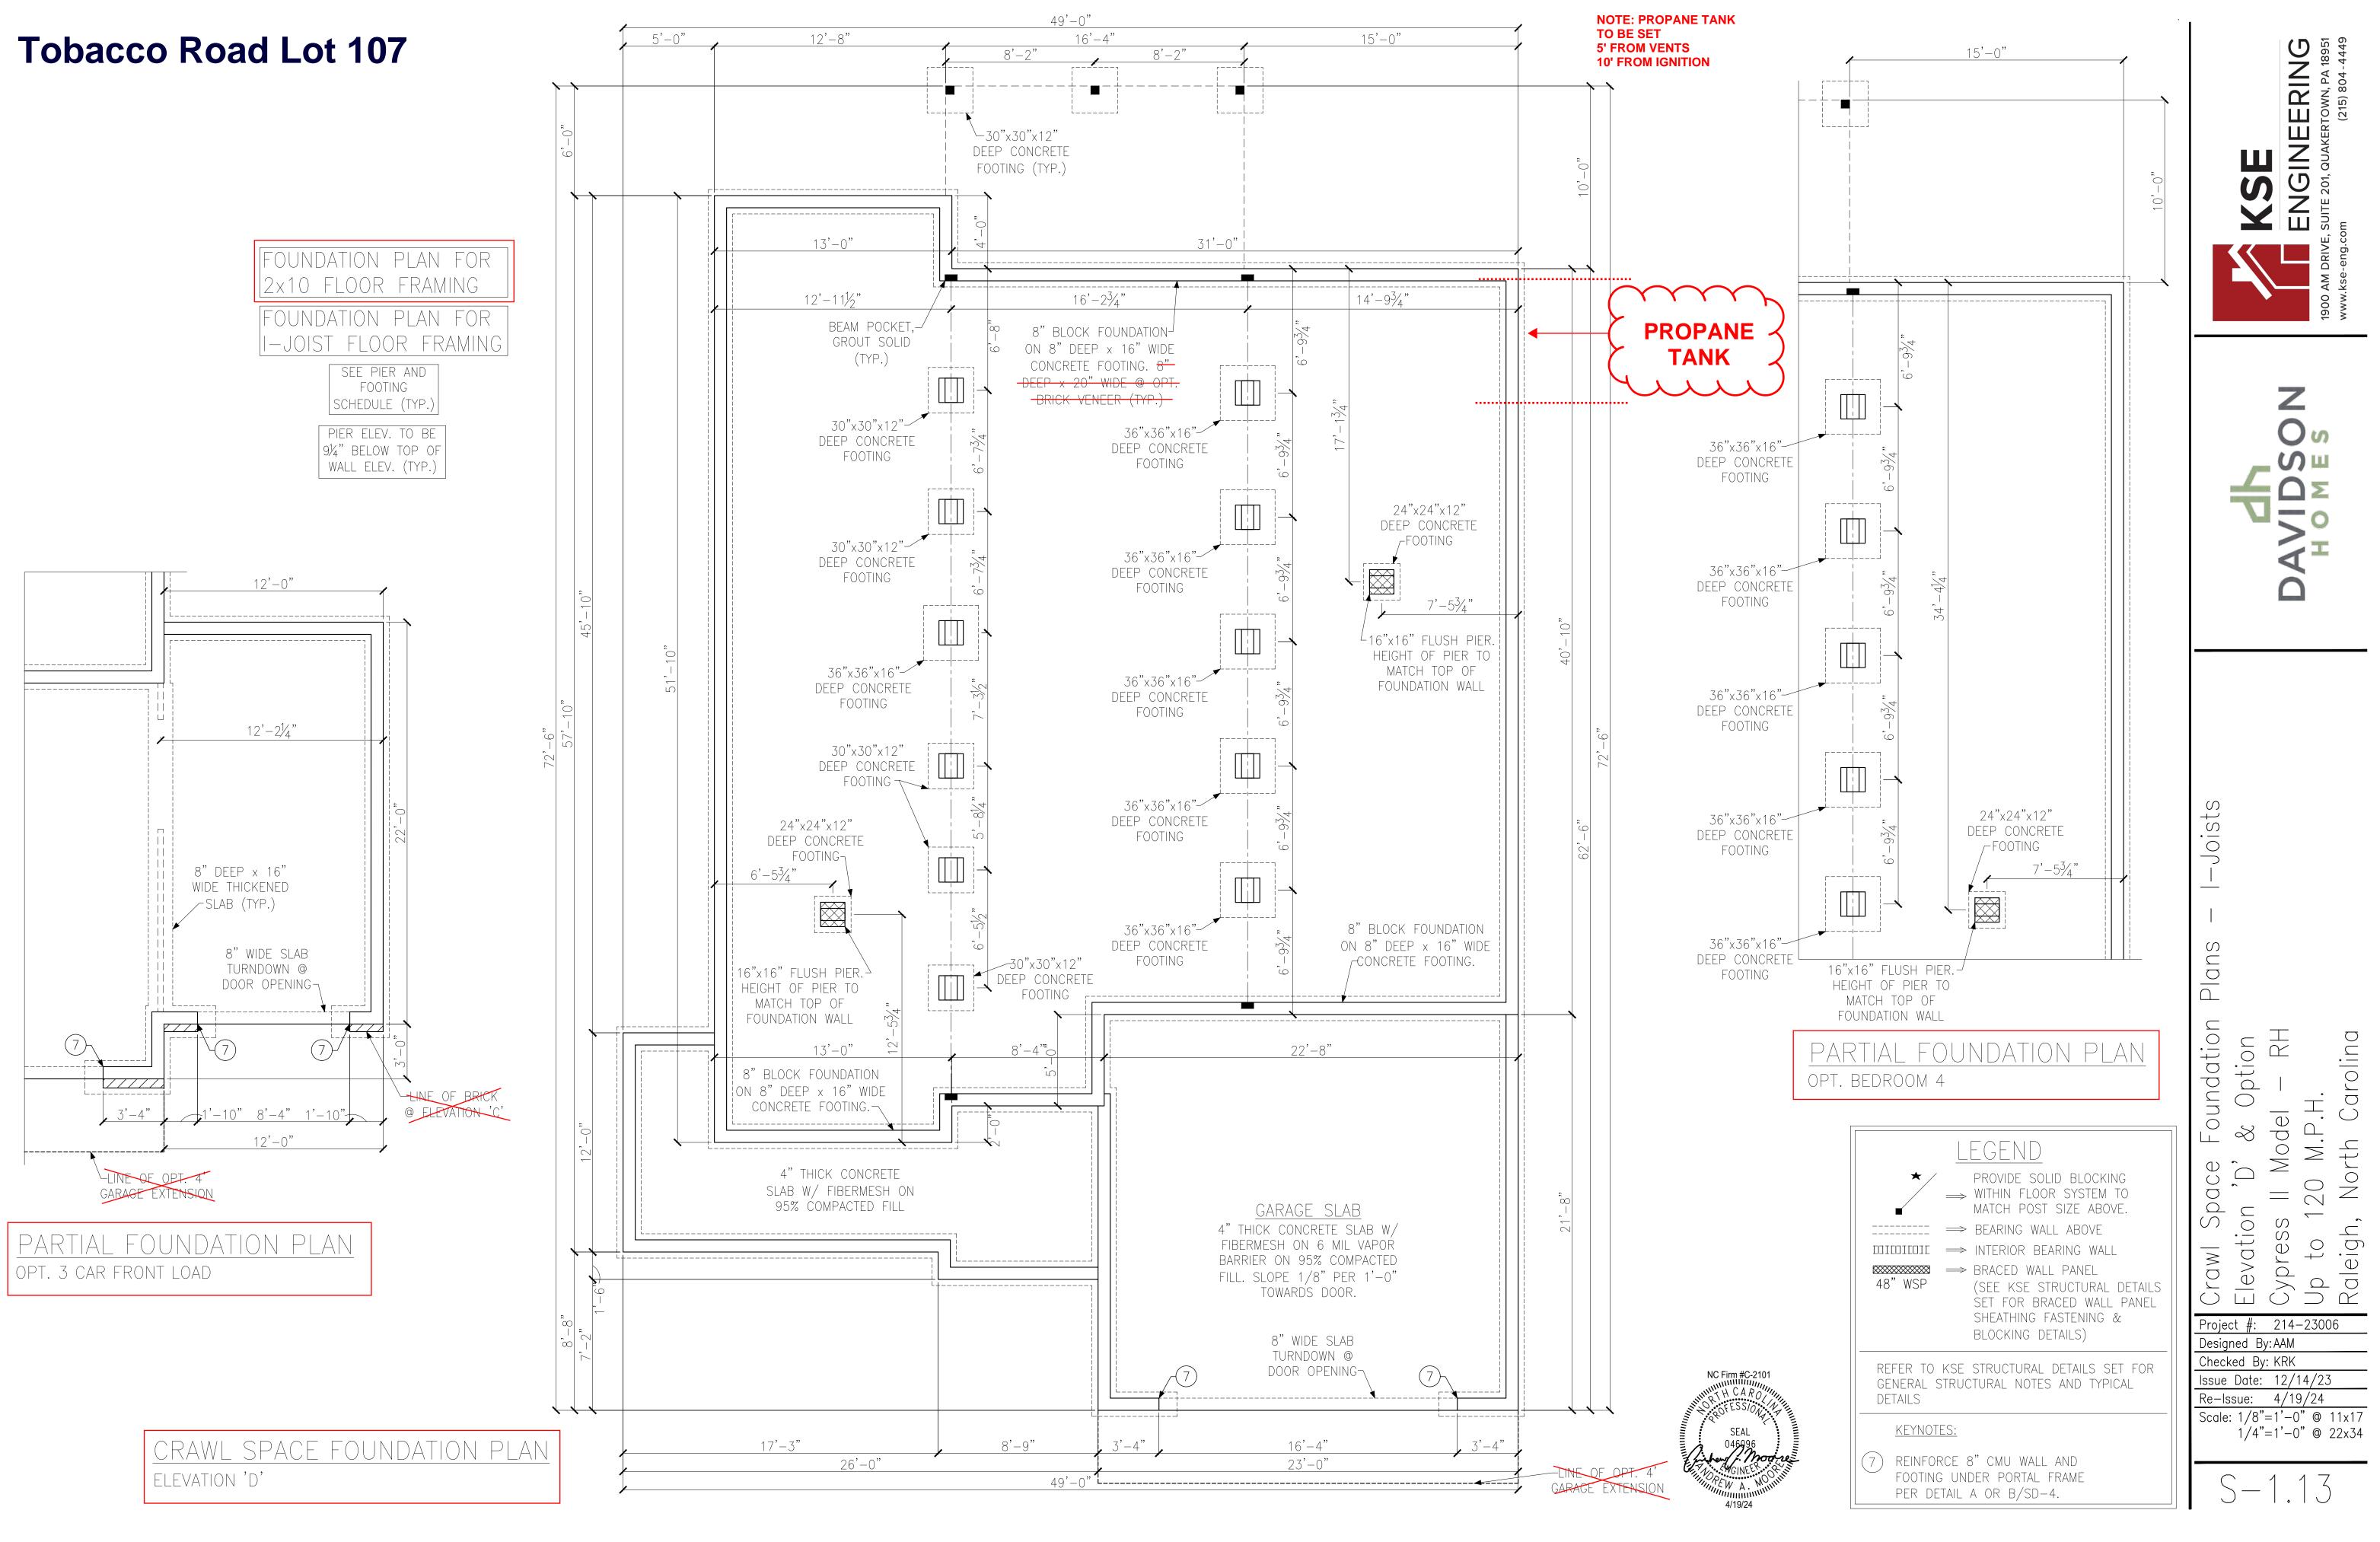


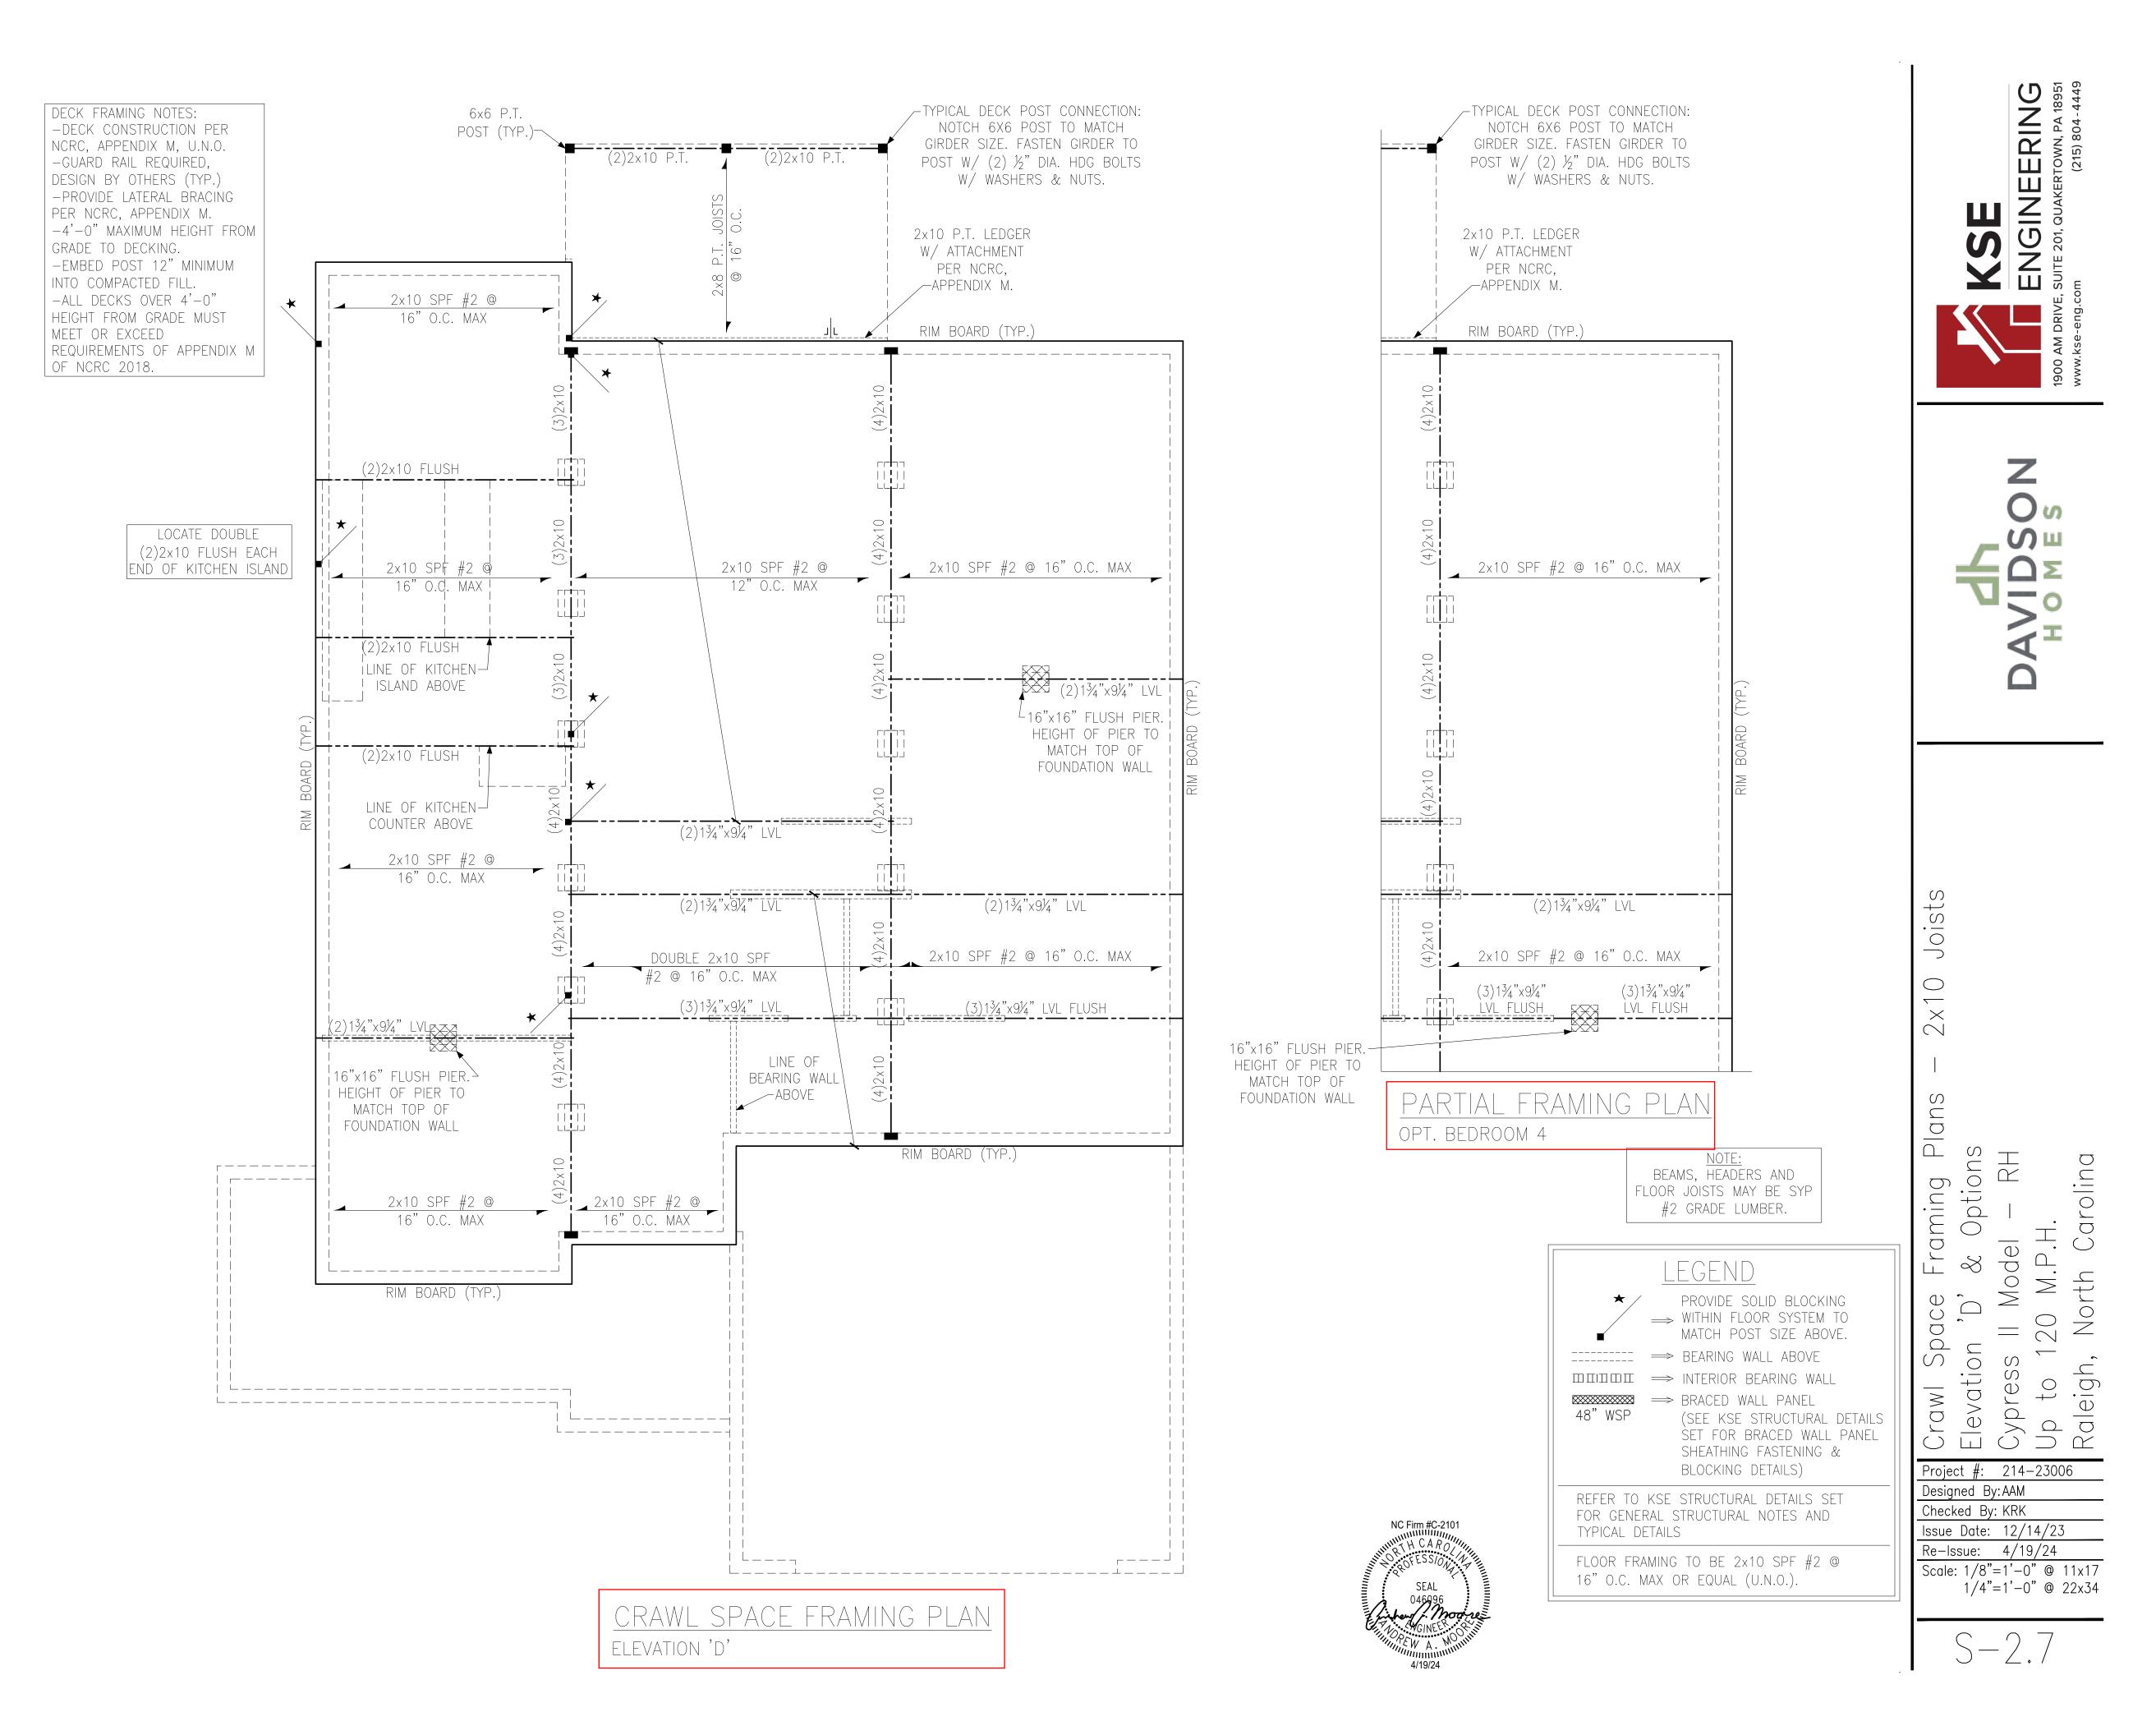

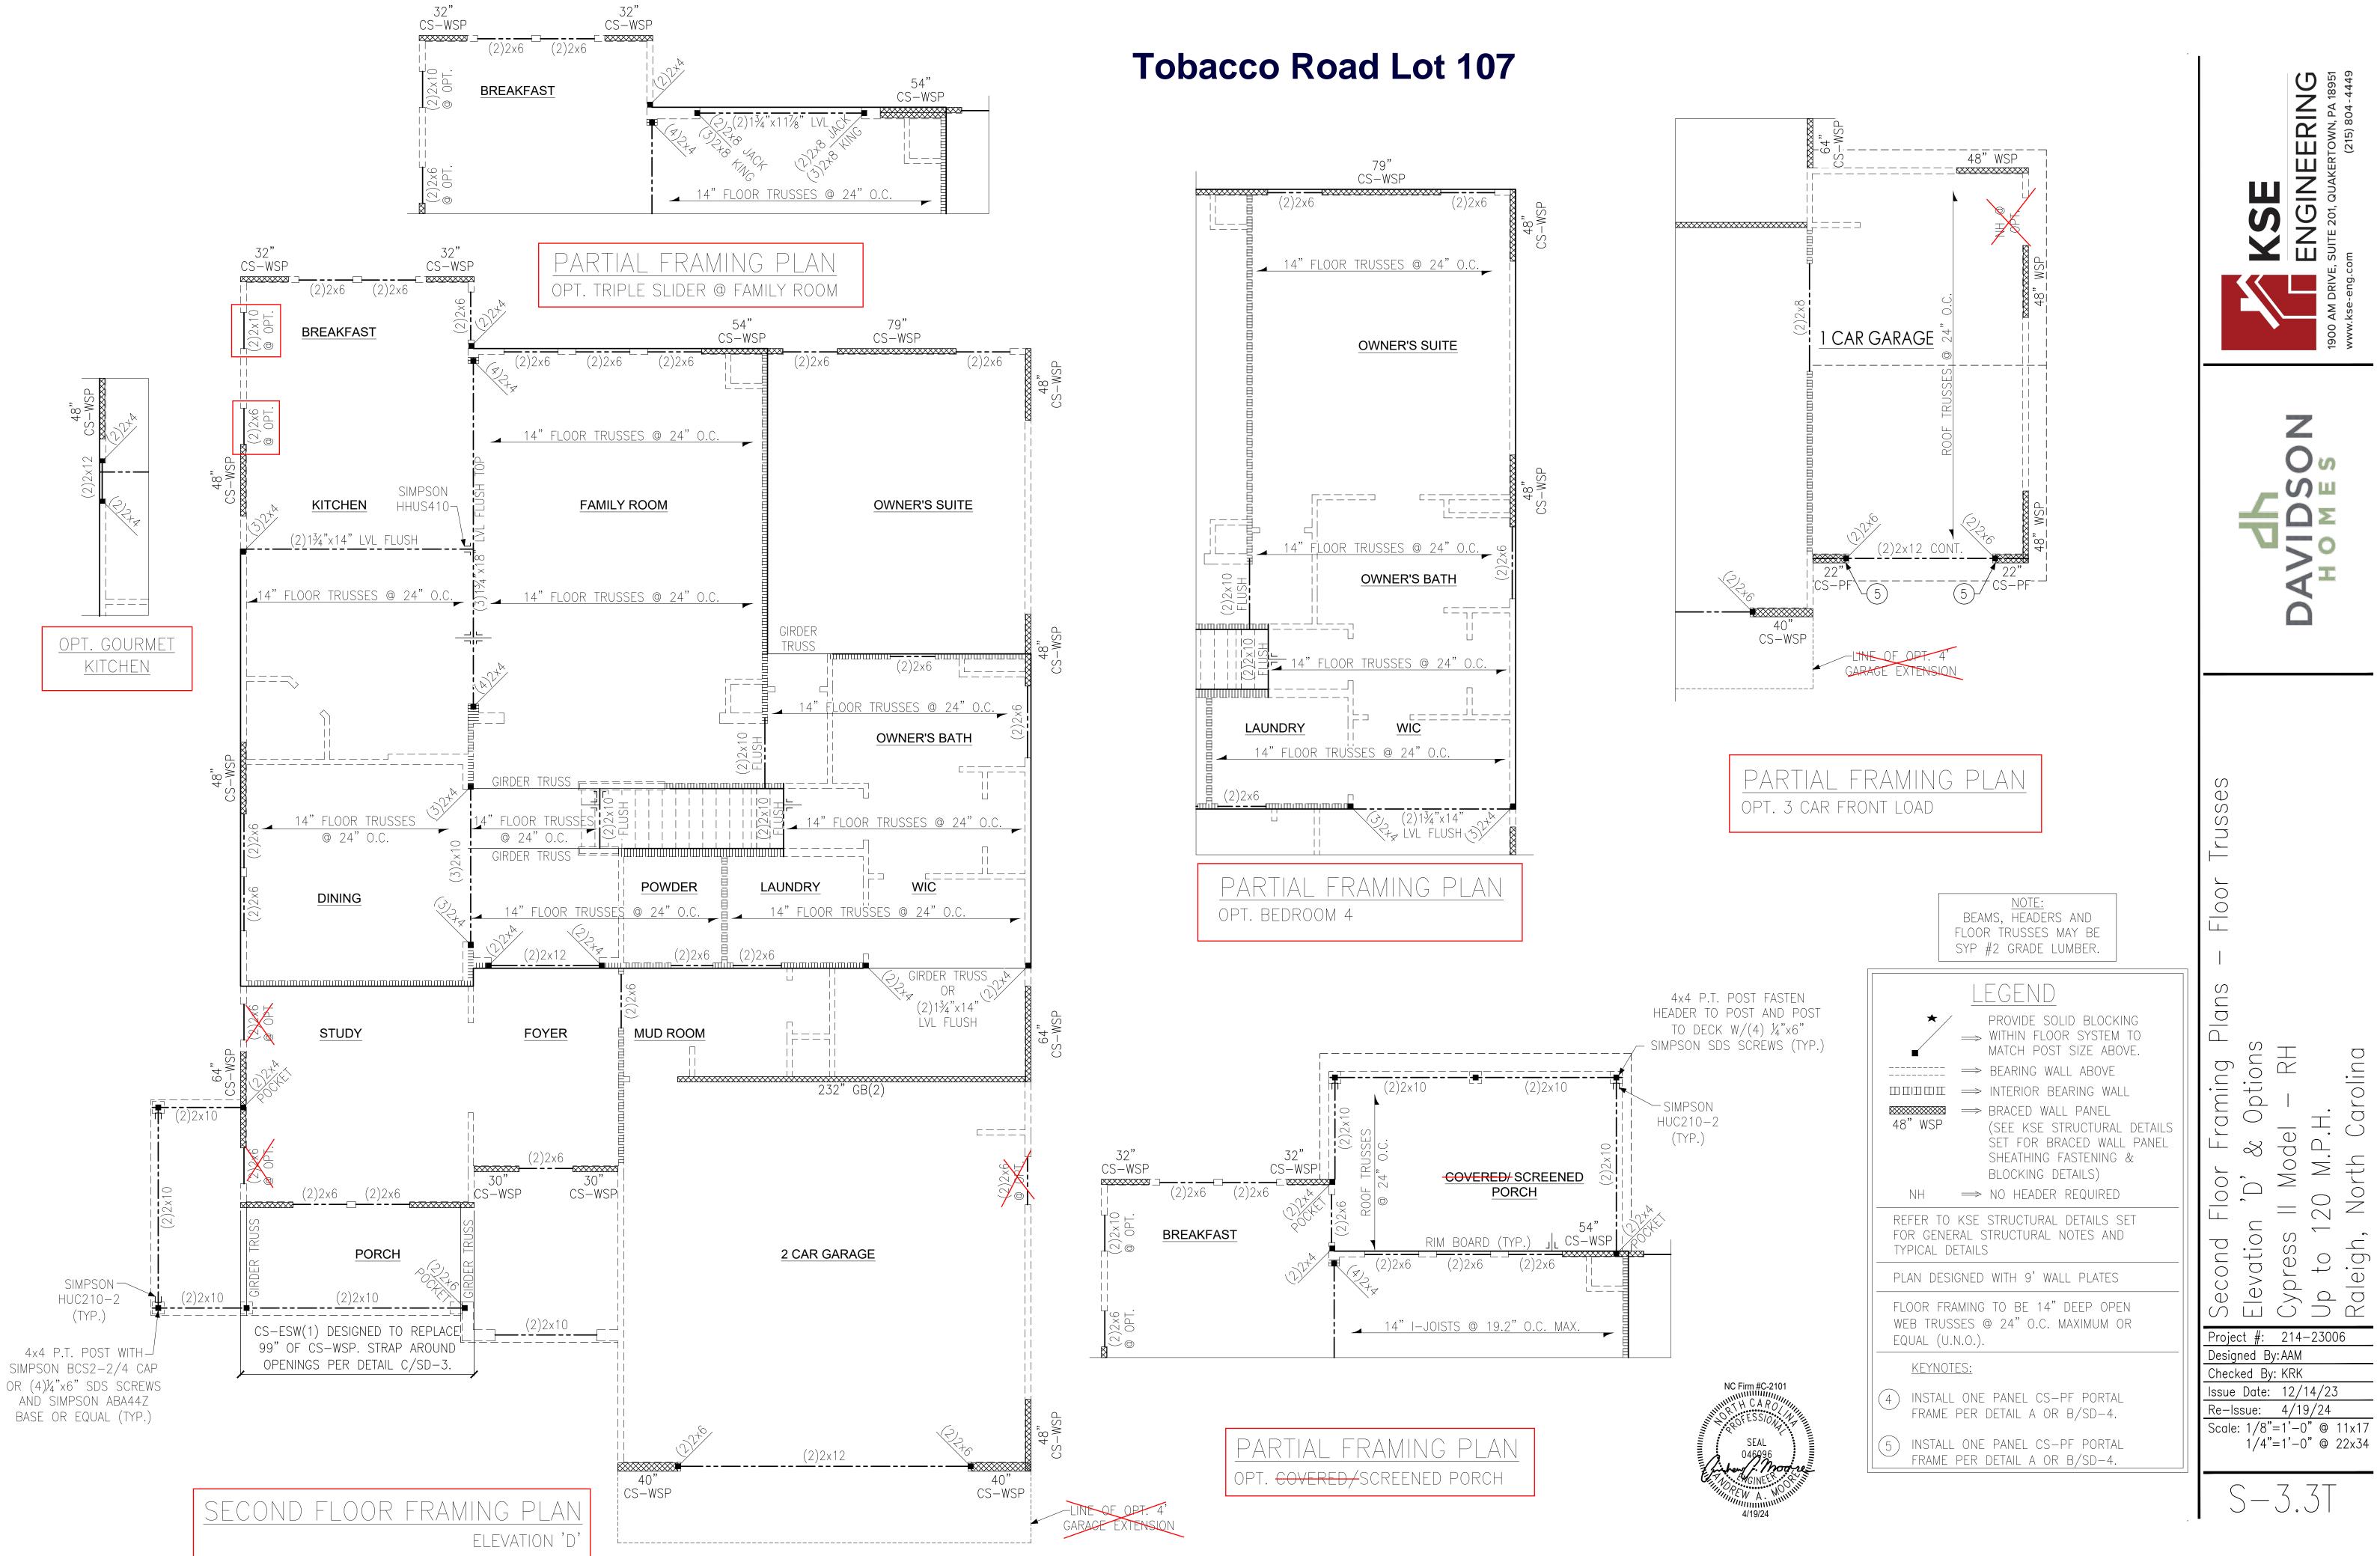



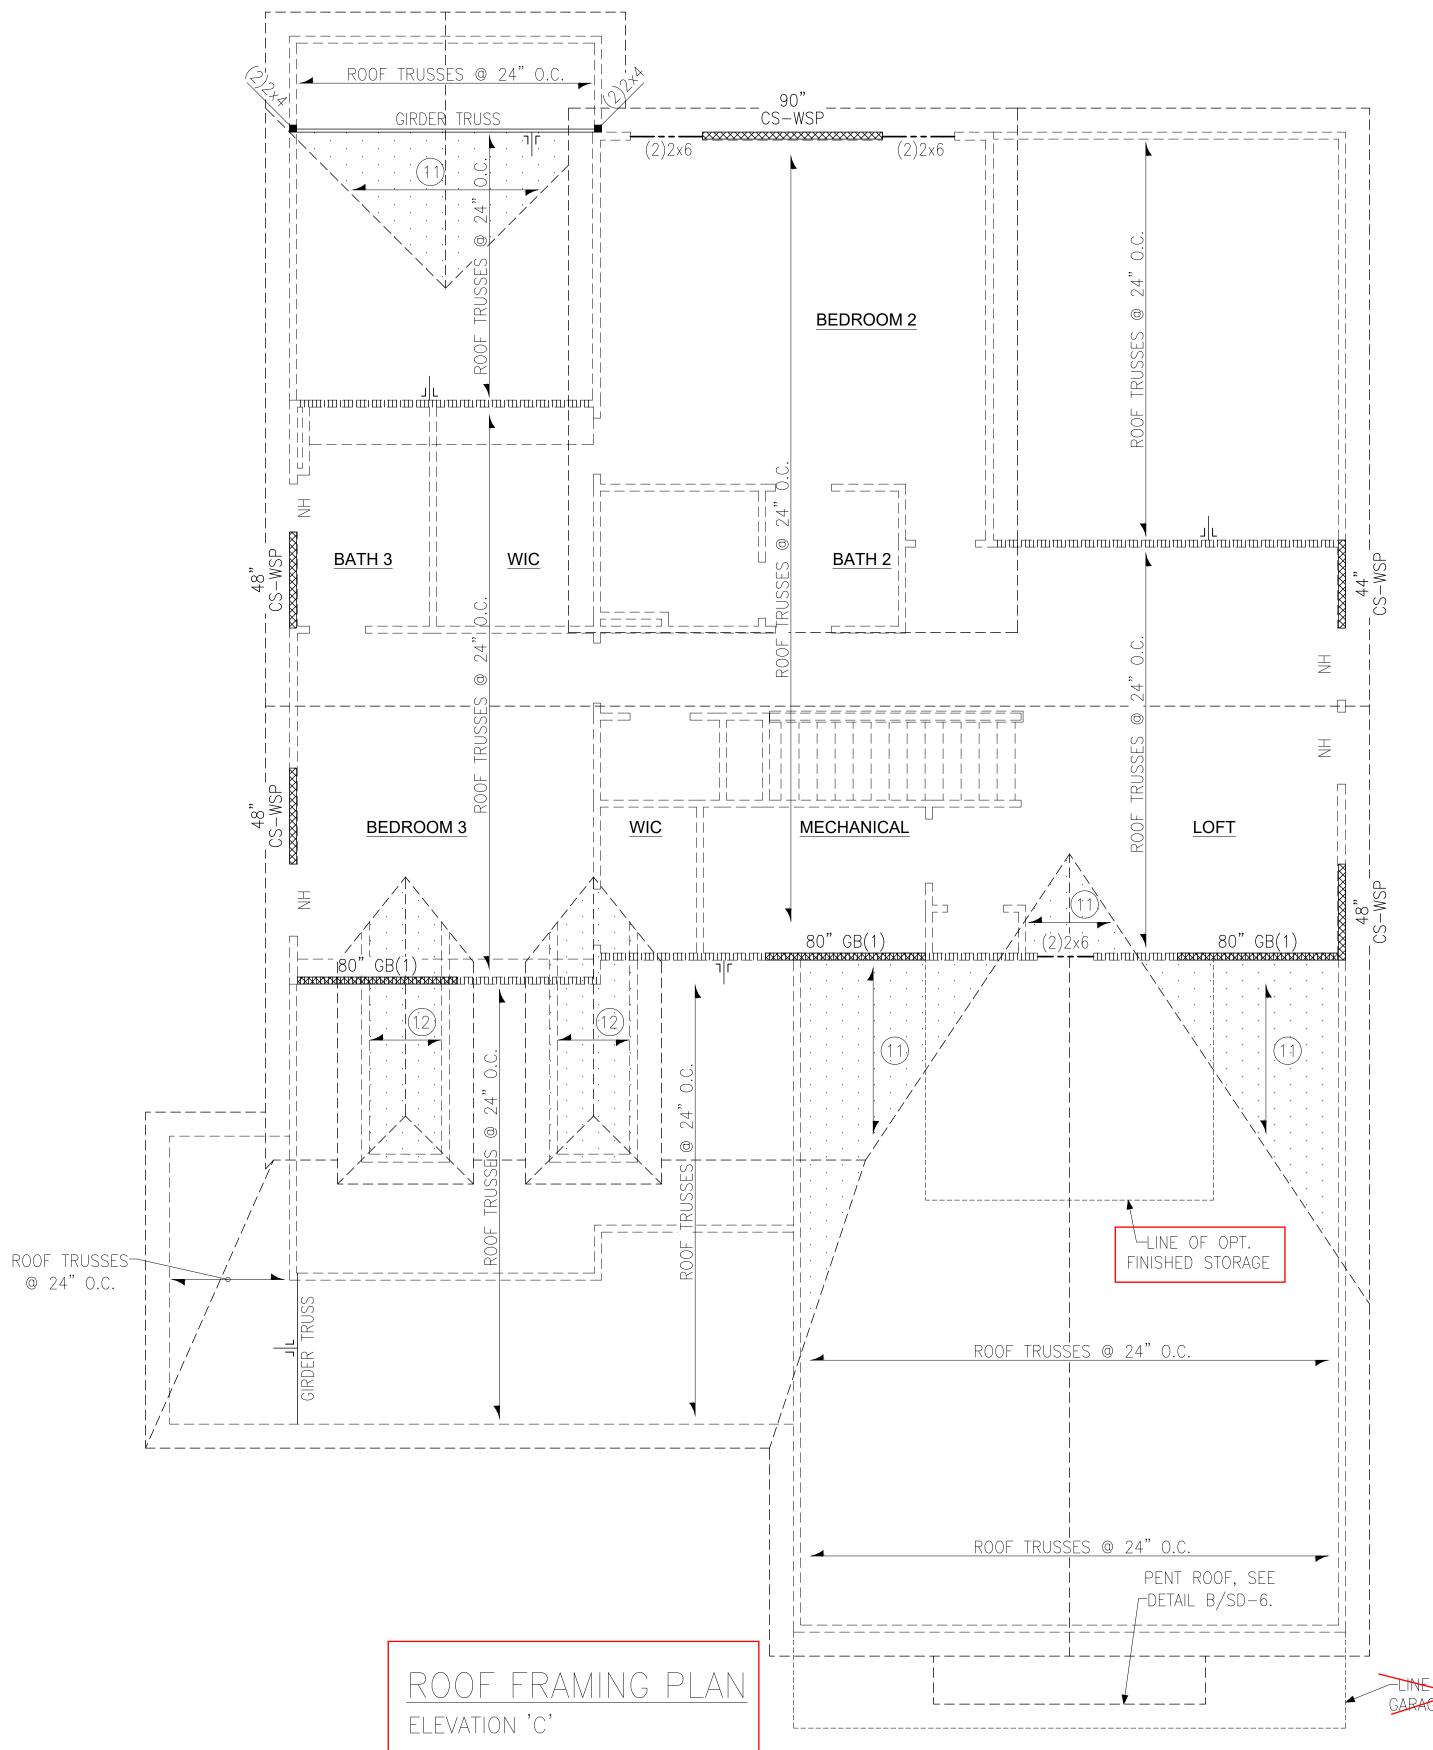

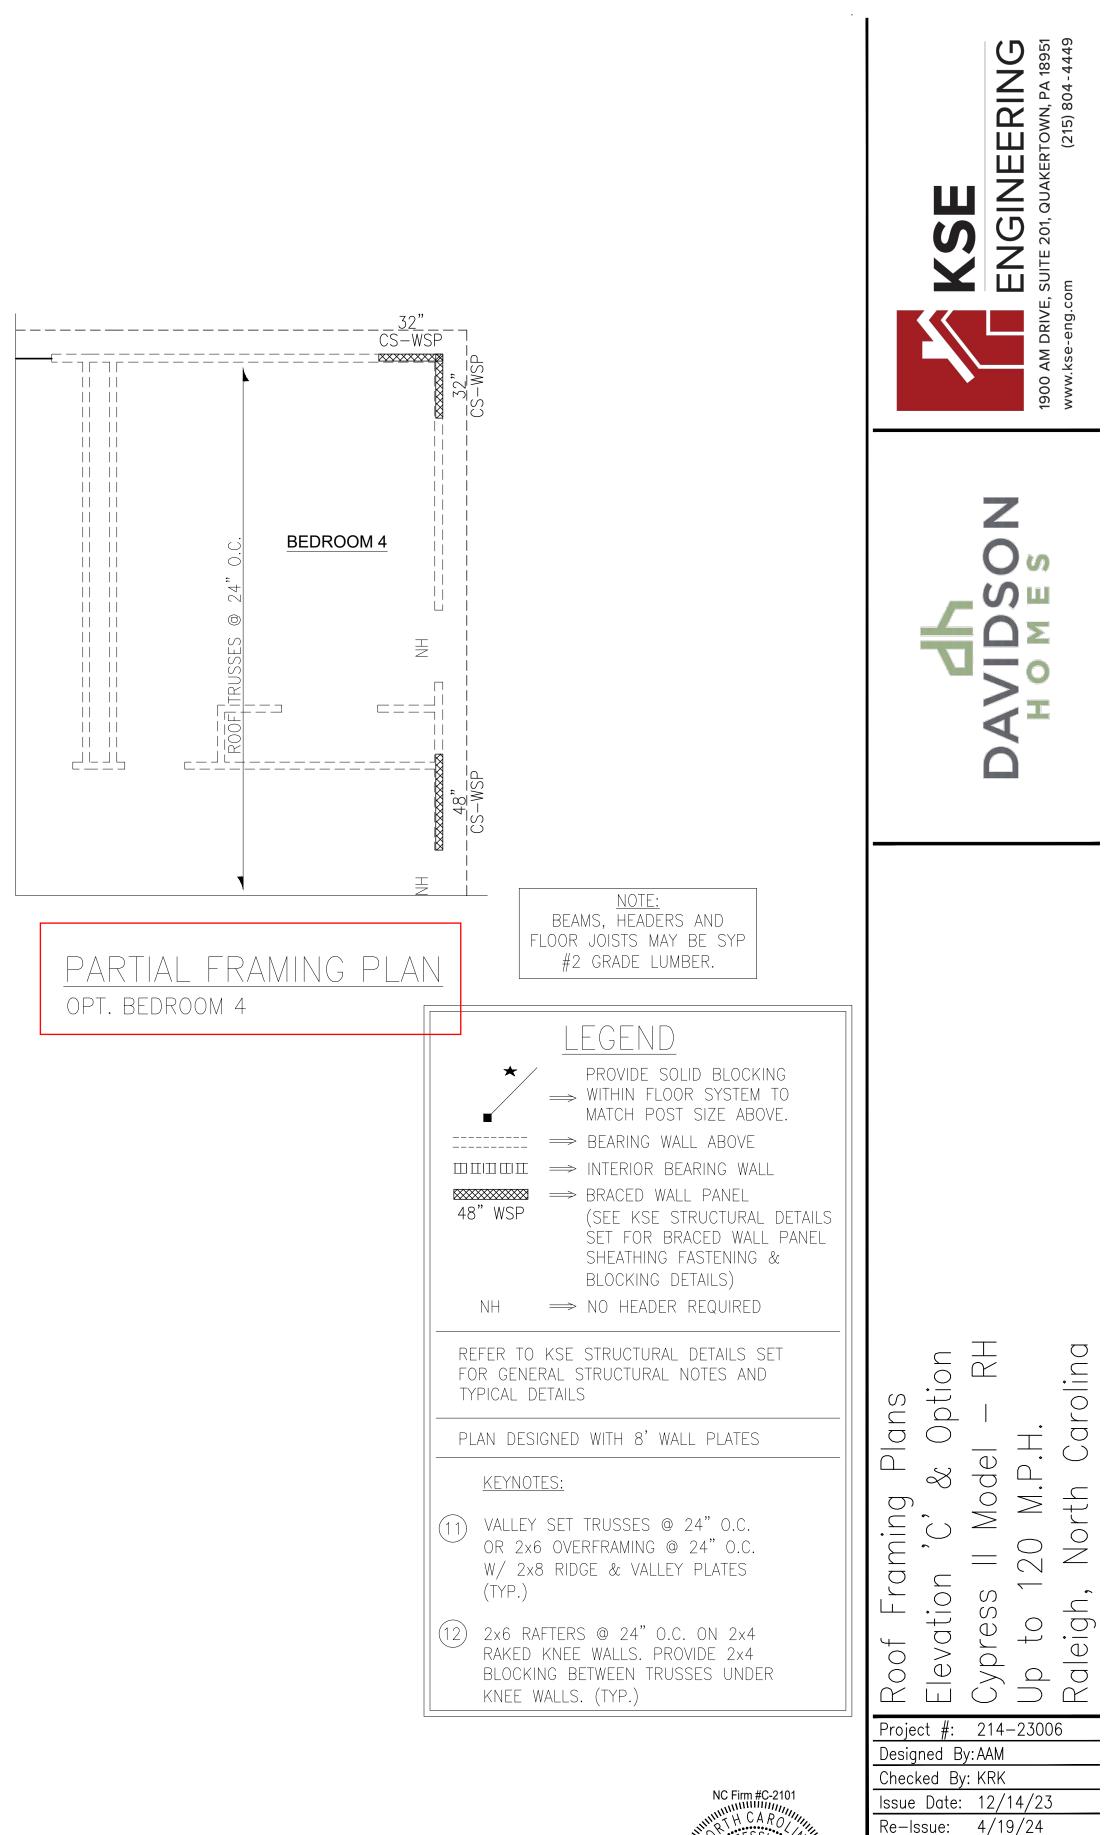







5 - 4.2

Scale: 1/8"=1'-0" @ 11x17

1/4"=1'-0" @ 22x34

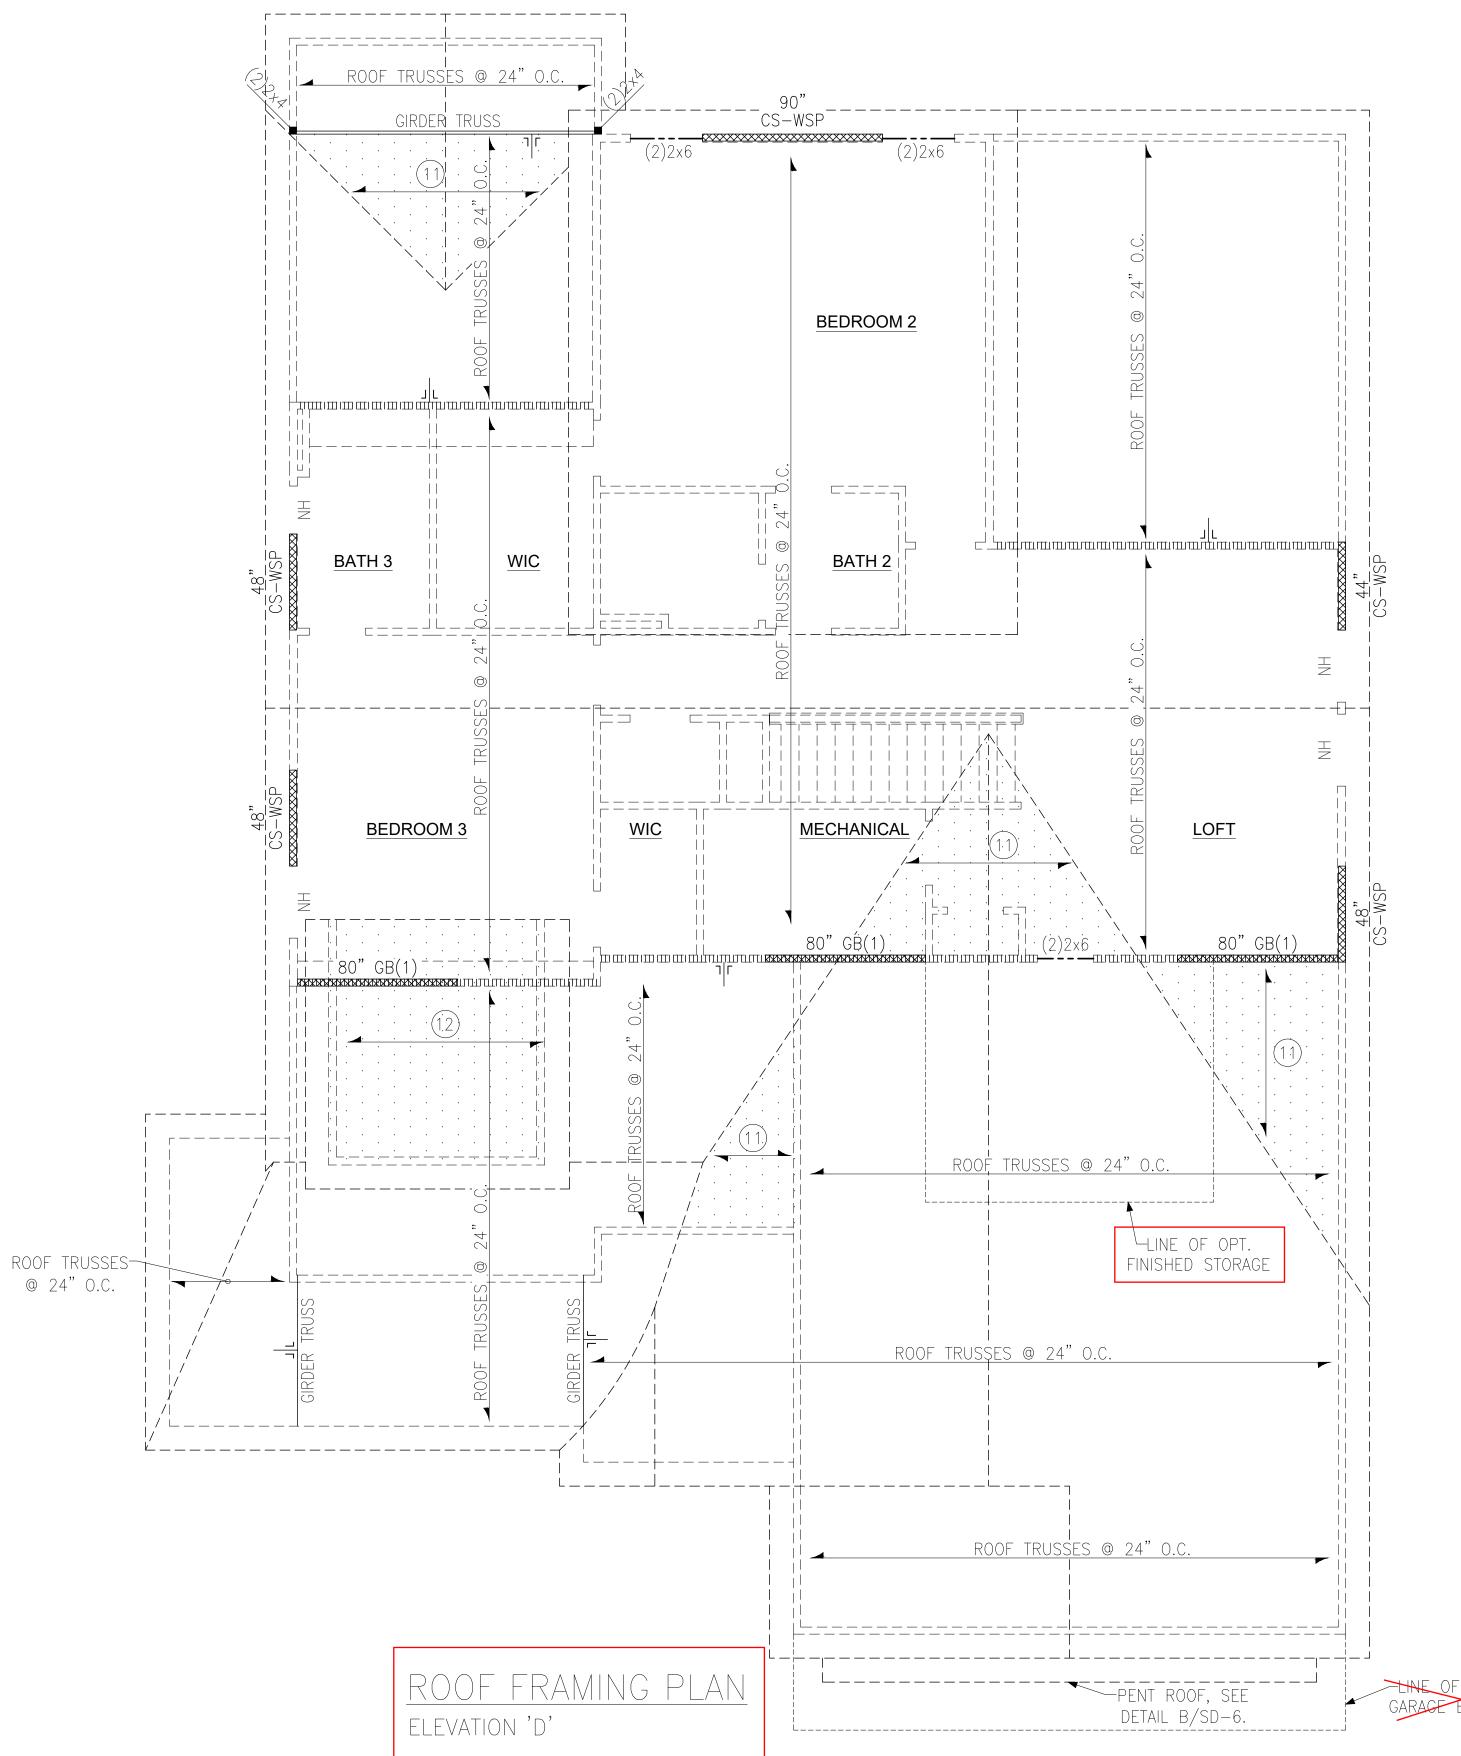

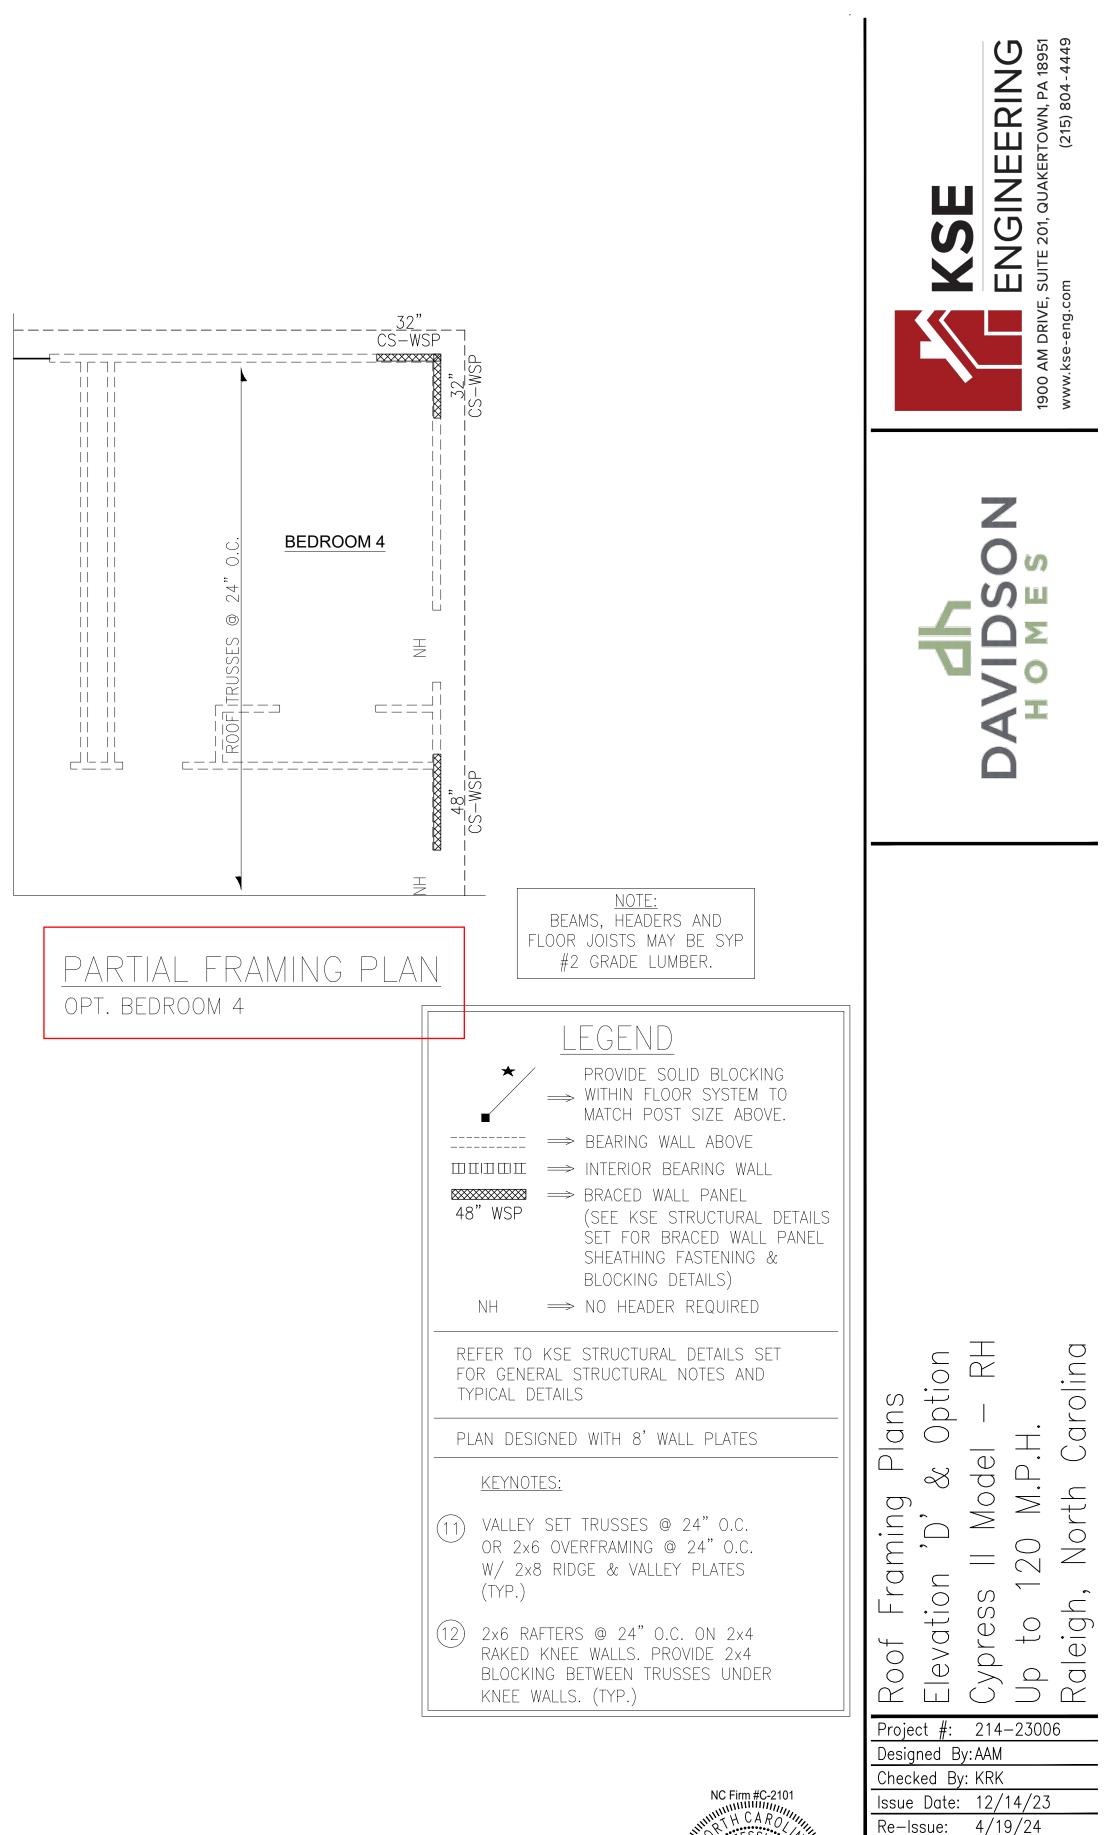






S - 4.5

Scale: 1/8"=1'-0" @ 11x17

1/4"=1'-0" @ 22x34

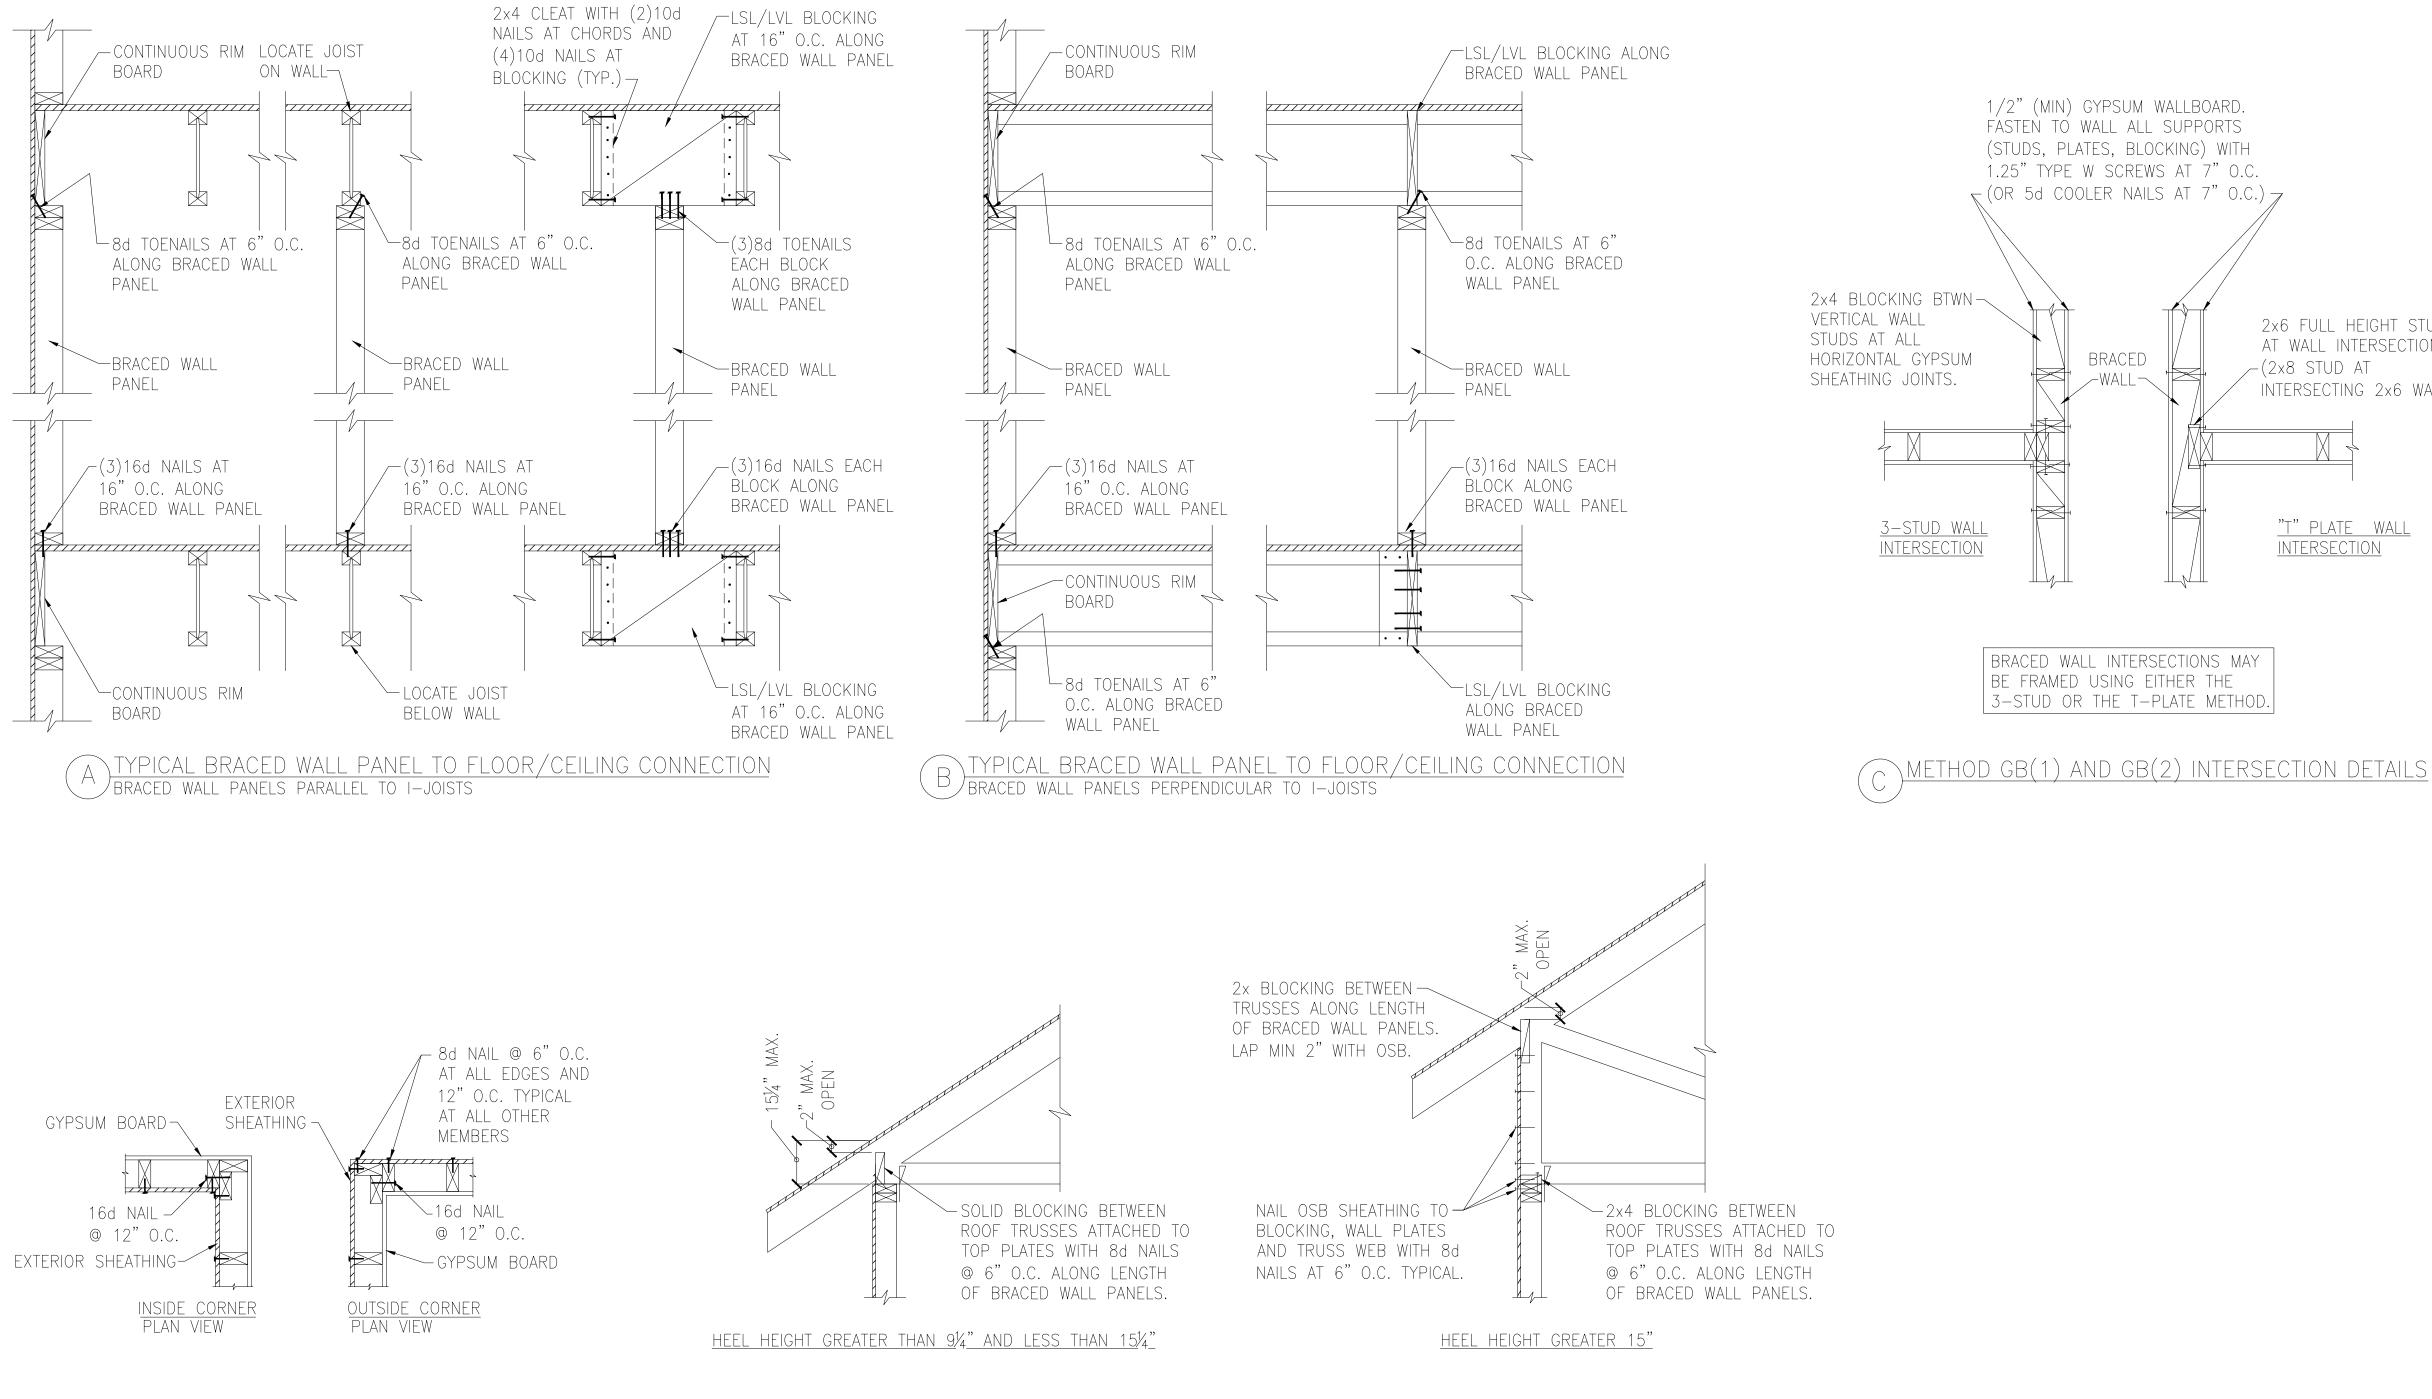




<u>ROOF TRUSS BEARING/BLOCKING AT BRACED WALL PANELS</u> ONLY REQUIRED AT BRACED WALL PANELS

2x6 FULL HEIGHT STUD AT WALL INTERSECTION /-(2x8 STUD AT INTERSECTING 2×6 WALL)

"T" PLATE WALL **INTERSECTION**

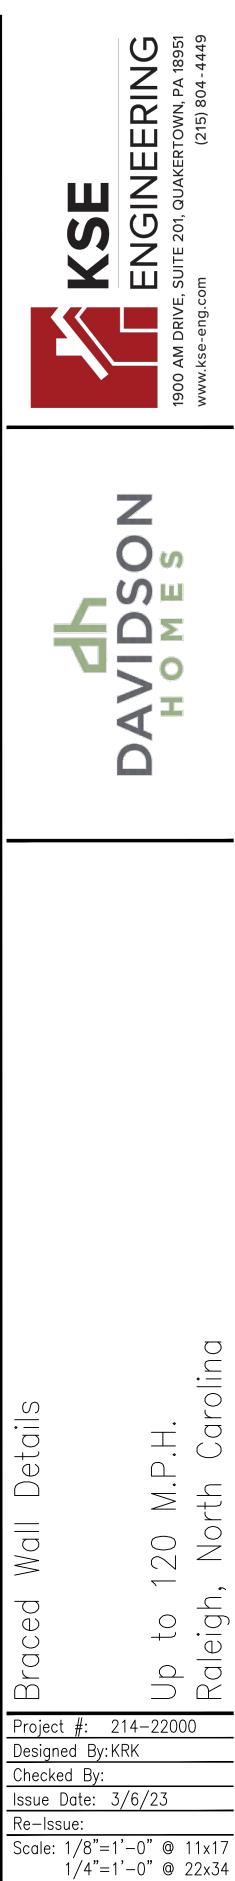



SEAL 046096 WGINEER WANNER SD-

NC Firm #C-2101

SEAL



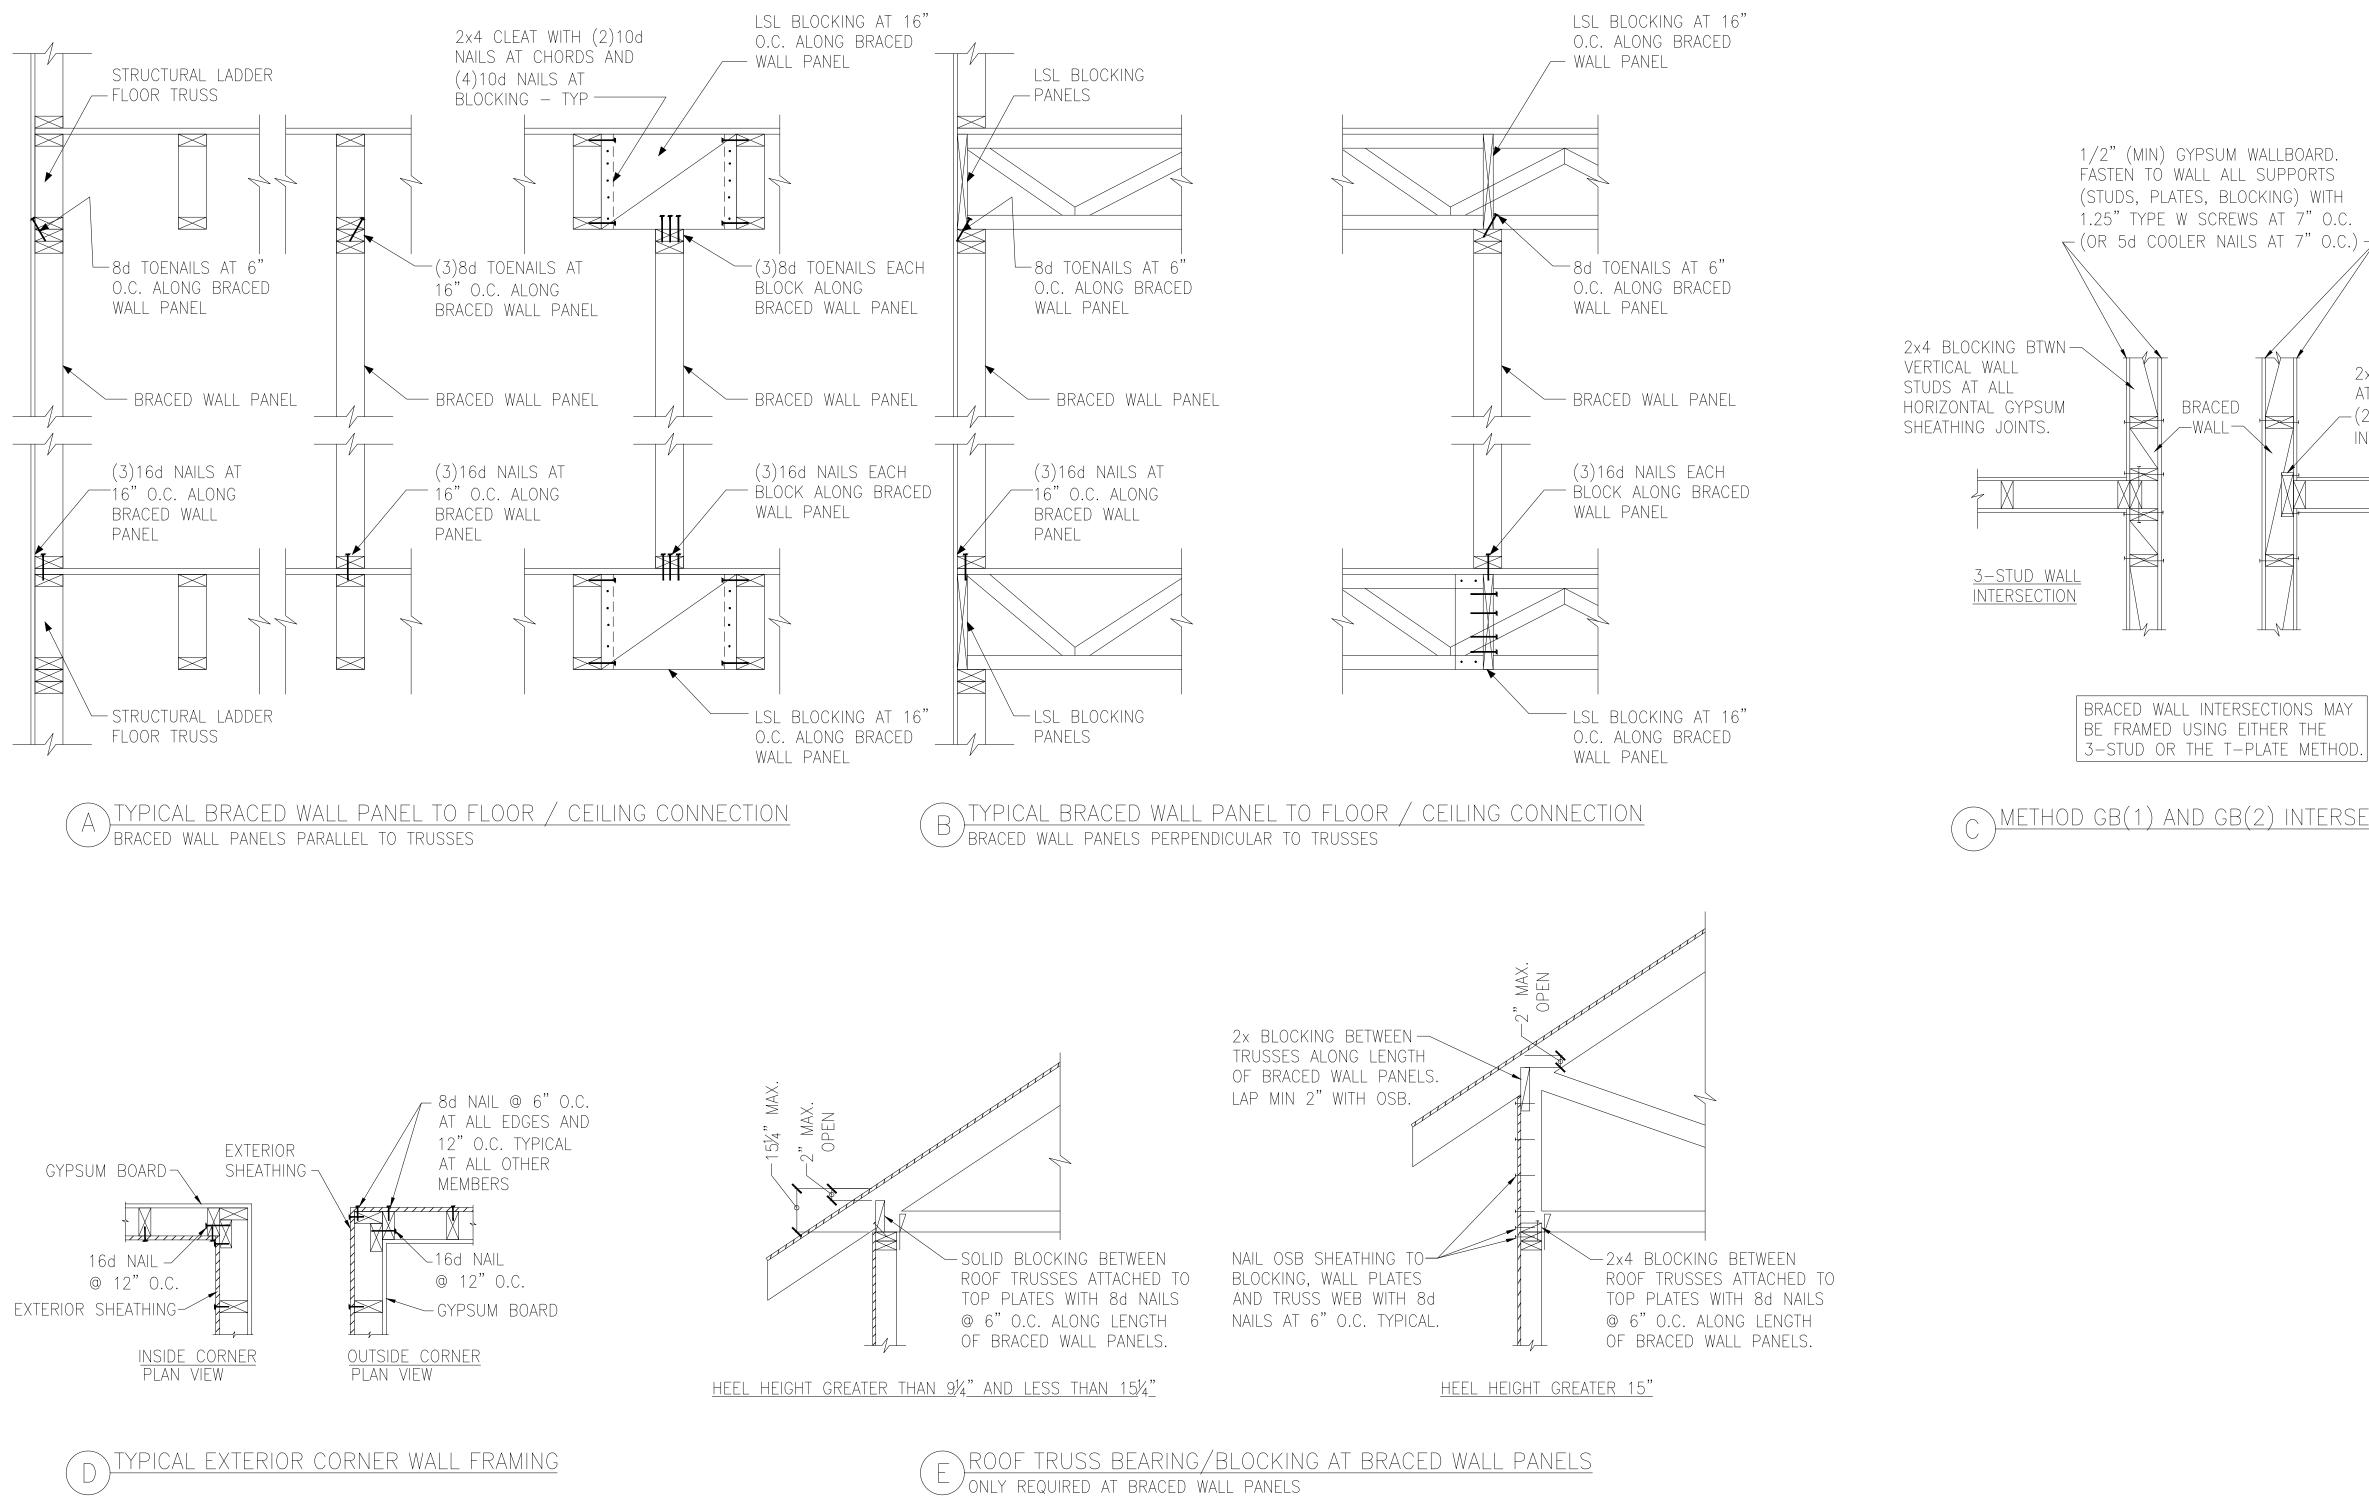

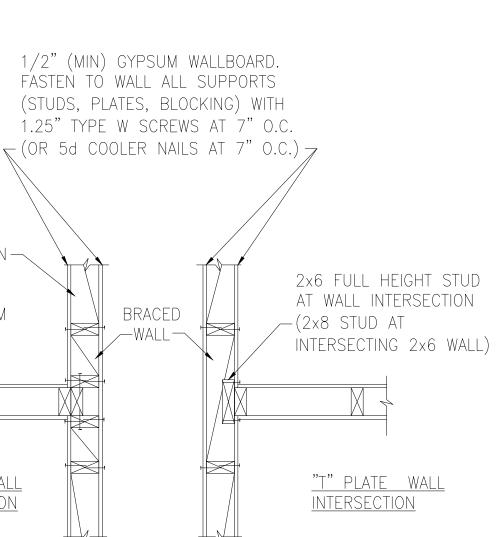

BRACED

 \bigcirc METHOD GB(1) AND GB(2) INTERSECTION DETAILS


SINEERING 1, QUAKERTOWN, PA 18951 (215) 804 - 4449 **В** C \mathbf{X} SШ Carolina Details \Box ∟. ≥ North Wall 20 $\overline{}$ aleigh, ced to \Box Up Ral Ē Project #: 214-22000 Designed By:KRK Checked By: Issue Date: 3/6/23

N NUNHUN N	C Firm #C-210 TH CARO	
THE OCO	C Firm #C-210 T H C A R O PF ESSION SEAL 046096 CHORNEER PEW A. M	C. C
	4/19/24	

Scale: 1/8"=1'-0" @ 11x17


1/4"=1'-0" @ 22x34

Re-Issue:

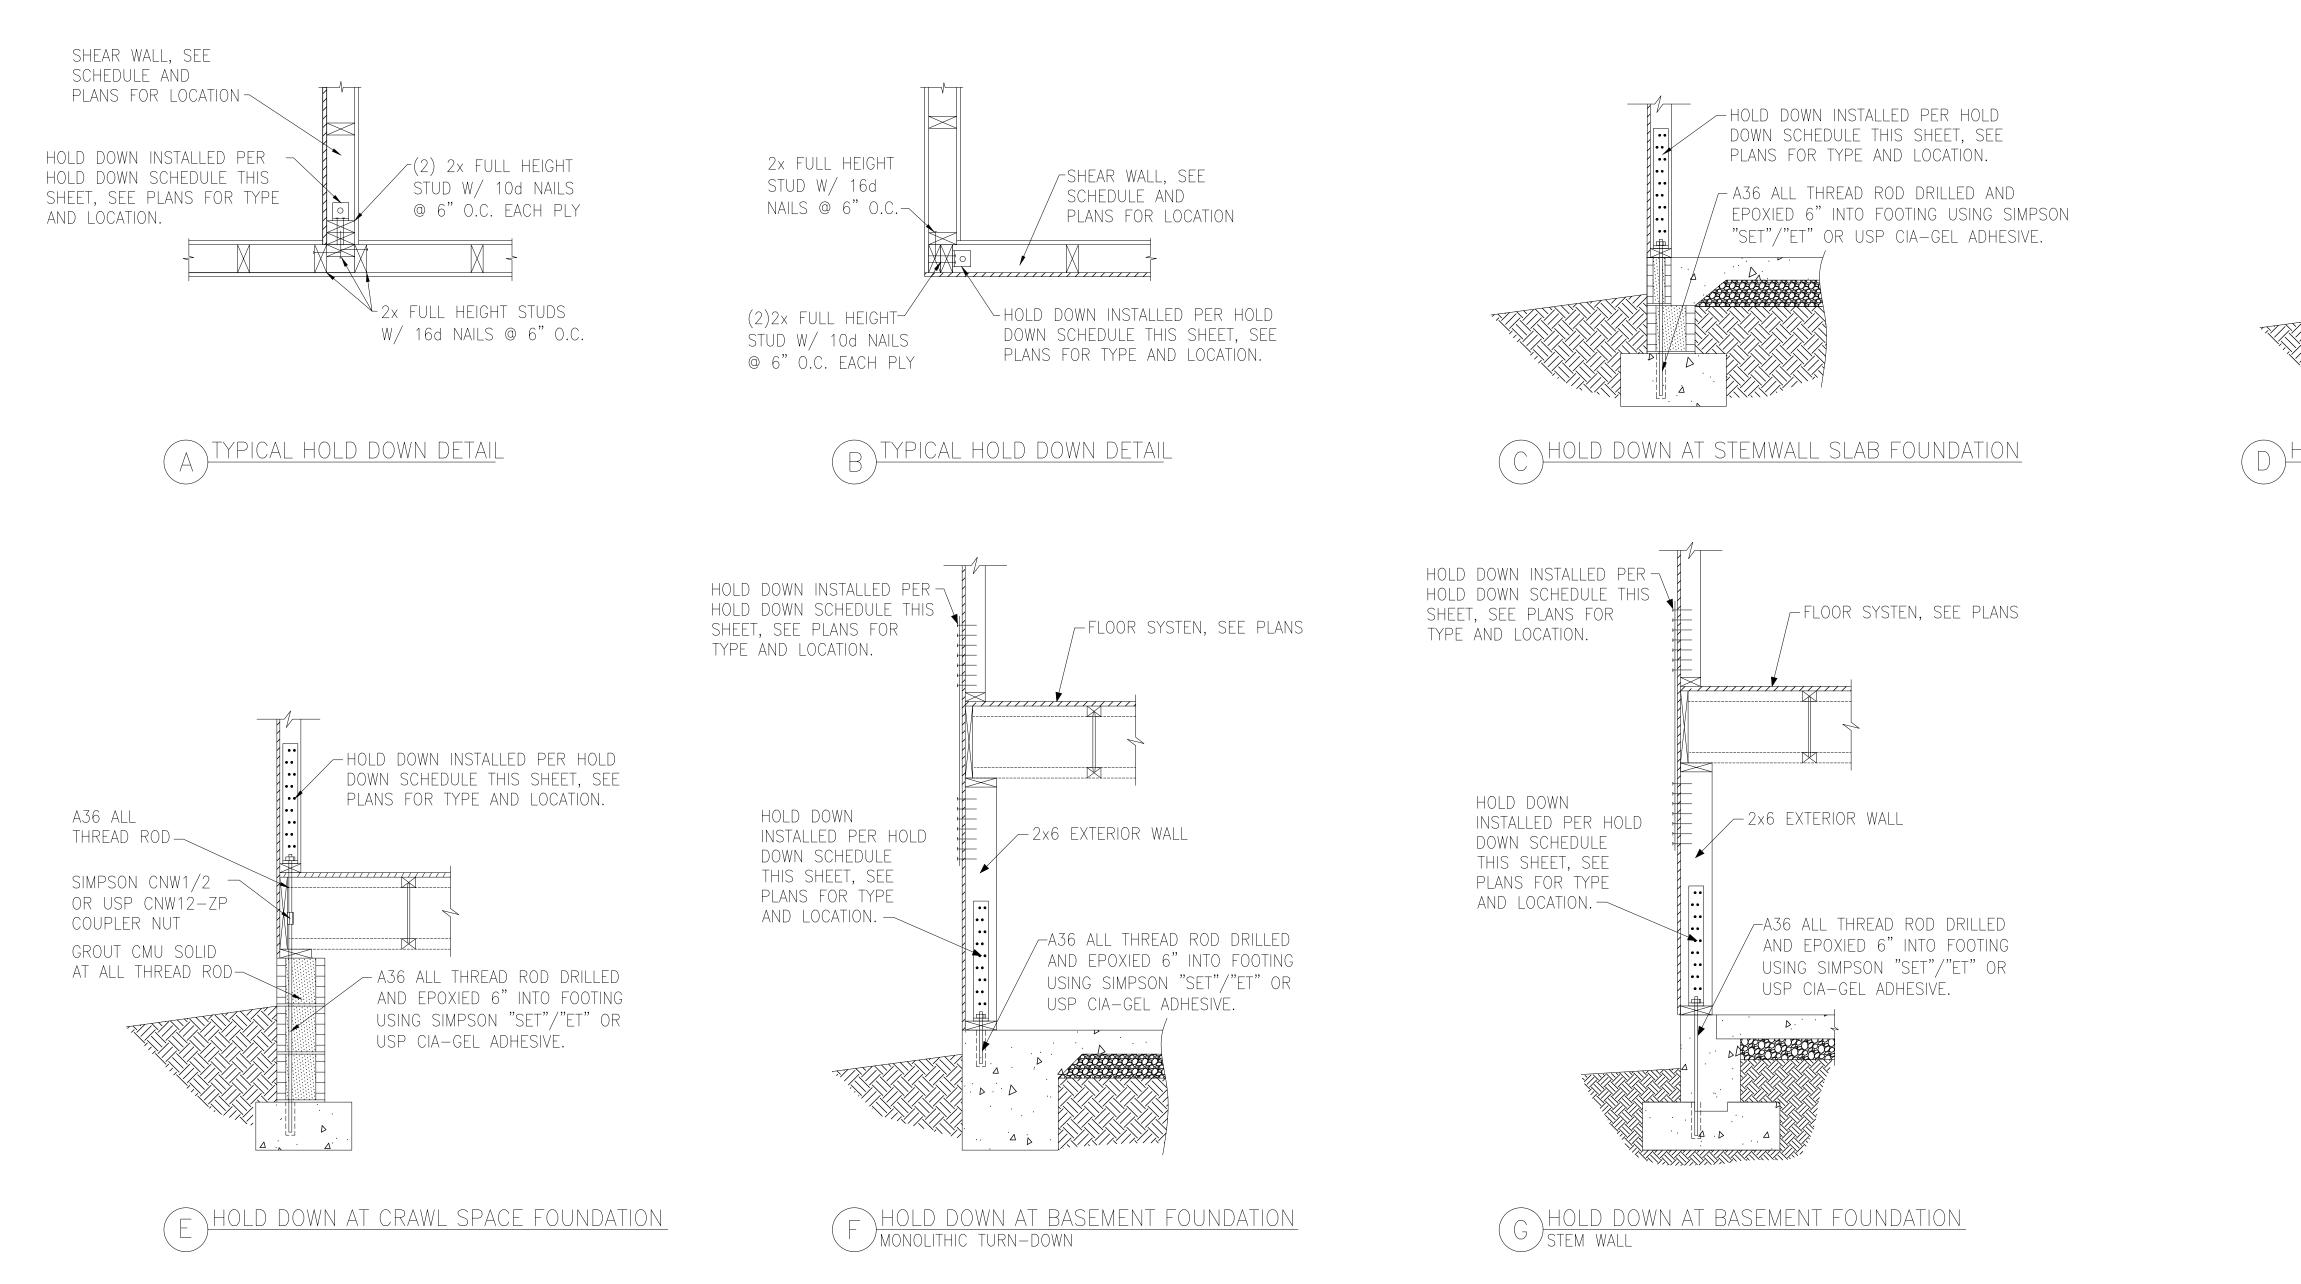


HOLD DOWN SCHEDULE					
HOLD DOWN SIMPSON USP ALL THREAD ROD FASTENERS					
LTTP2	LTS20B	1⁄2" DIA.	(12)0.148"x2.5" LONG NAILS		
HTT4	HTT16	5∕8" DIA.	(18)0.162"x2.5" LONG NAILS		
HTT5	HTT45	5⁄8" DIA.	(26)0.162"x2.5" LONG NAILS		




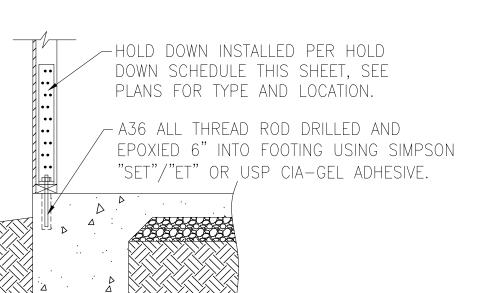

D HOLD DOWN AT MONOLITHIC SLAB FOUNDATION

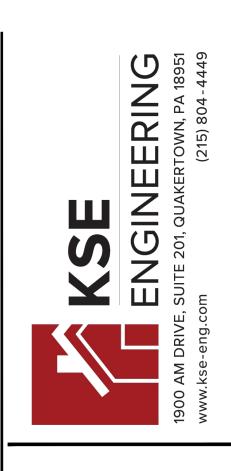



DAVIDSON H 0 M E S

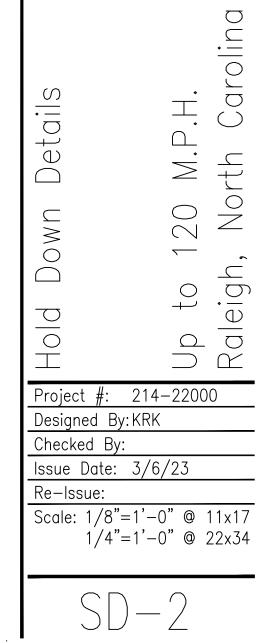

0	Road	Lot	107



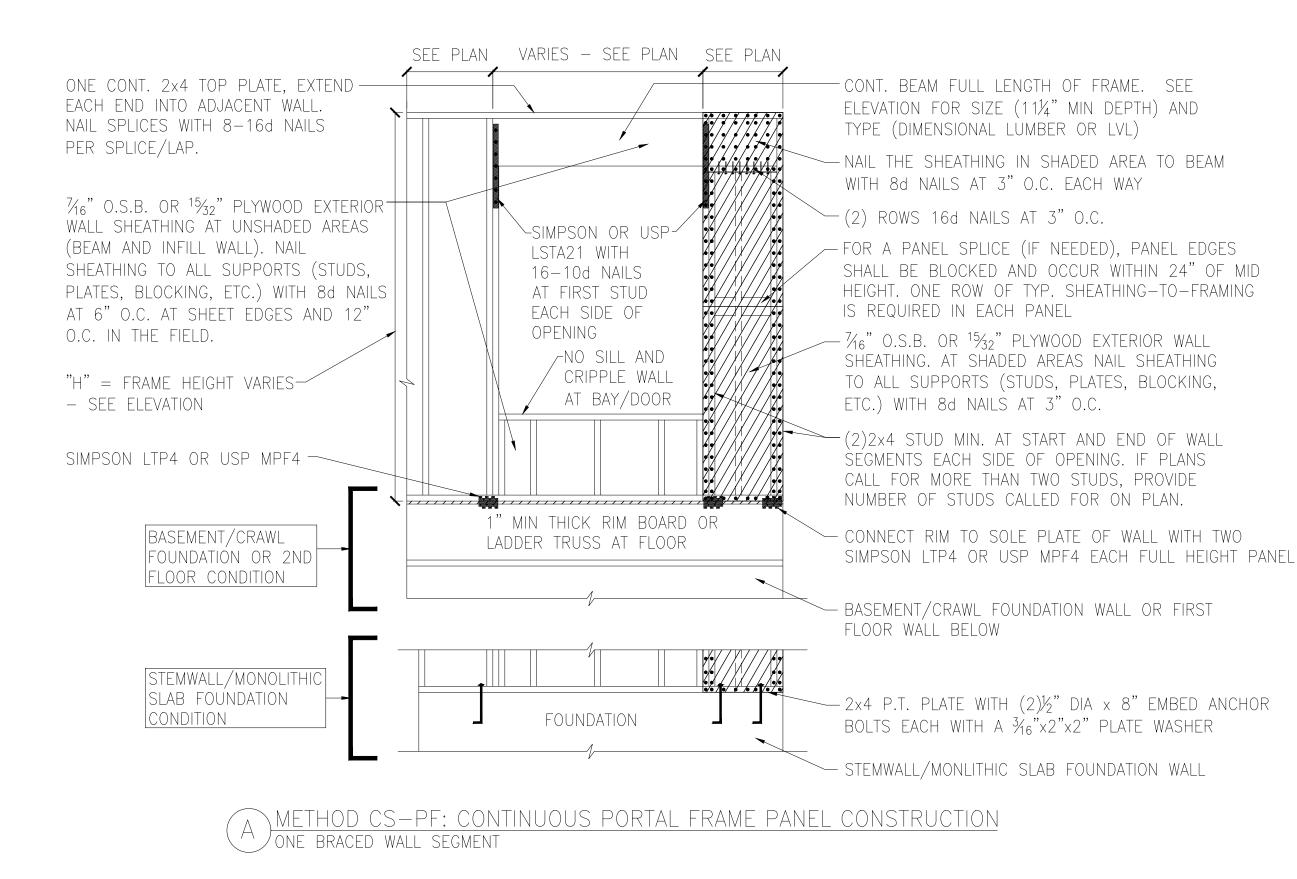

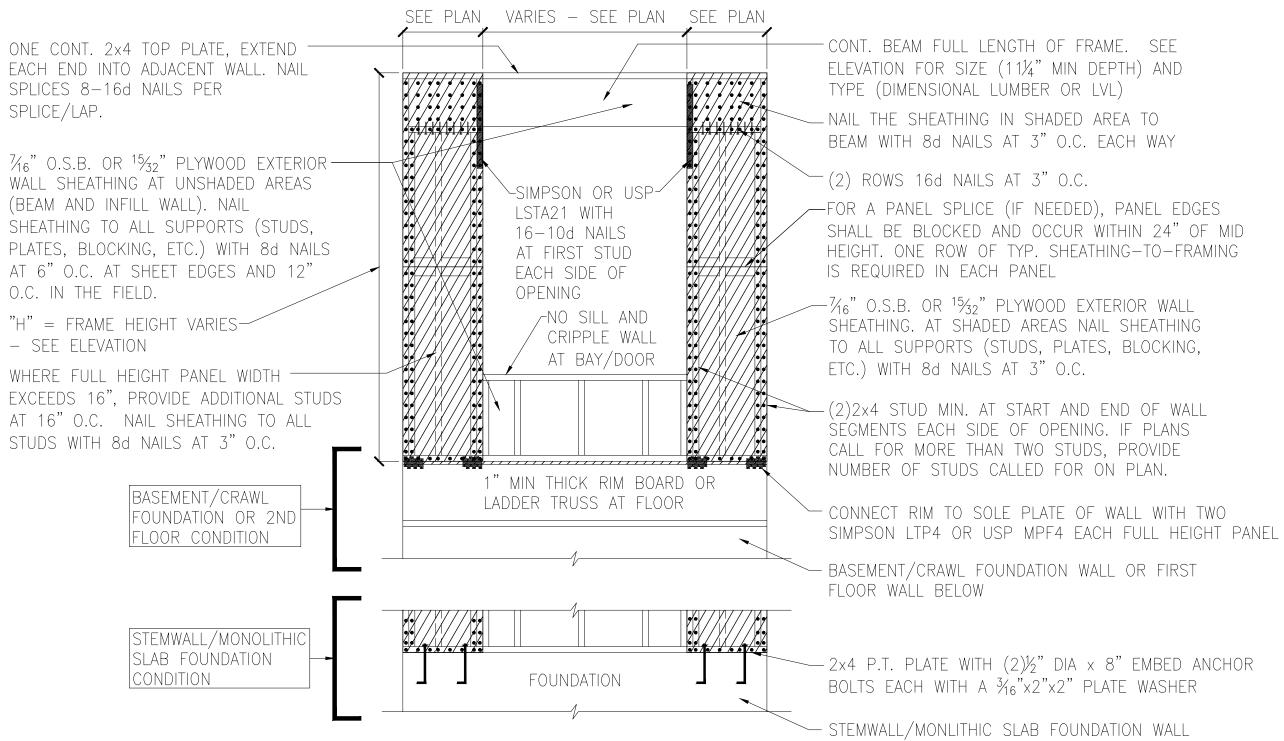

METHOD CS-PF: CONTINUOUS PORTAL FRAME PANEL CONSTRUCTION B) TWO BRACED WALL SEGMENTS

E.	SEE	
	AND	
)		
, Т Л Т		

WSP	INTERMITTENT WOOD STRUCTURAL PANEL	7/16"OSB	6D OR 8D COMMON INTERMEDIATE SUPPC <u>STAPLES AT 3"O.C.</u>
GB(1)	INTERMITTENT GYPSUM BOARD (SHEATHING ONE FACE OF WALL)	1/2"GYPSUM	1.5" LONG GALV. RO DRYWALL SCREWS AT
GB(1)-4	INTERMITTENT GYPSUM BOARD (SHEATHING ONE FACE OF WALL)	1/2"GYPSUM	1.5" LONG GALV. RO DRYWALL SCREWS AT
GB(2)	INTERMITTENT GYPSUM BOARD (SHEATHING BOTH FACES OF WALL)	1/2"GYPSUM	1.5" LONG GALV. RO DRYWALL SCREWS AT
CS-WSP	CONTINUOUS SHEATHED WOOD STRUCTURAL PANEL	7/16"OSB	6D OR 8D COMMON INTERMEDIATE SUPPC <u>STAPLES AT 3"O.C.</u>
CS-PF	CONTINUOUS SHEATHED PORTAL FRAME	7/16"OSB	NAILING PER DETAIL
PFH	PORTAL FRAME WITH HOLD DOWNS	7/16"OSB	NAILING PER DETAIL
CS-ESW(1)	ENGINEERED SHEAR Wall, TYPE 1	7/16"OSB	8D COMMON NAILS A INTERMEDIATE SUPPC
CS-ESW(2)	ENGINEERED SHEAR Wall, Type 2	7/16"OSB	8D COMMON NAILS A INTERMEDIATE SUPPC
CS-ESW(3)	ENGINEERED SHEAR Wall, TYPE 3	7/16"OSB	8D COMMON NAILS A INTERMEDIATE SUPPC

BRACED WALL PANEL AND ENGINEERED

MATERIAL

BRACED WALL PANEL NOTES:


PANEL TYPES

PANEL TYPE

1. ALL BRACED WALL PANELS, EXCEPT GB(1) & GB(2), SHALL HAVE 2x BLOCKING BETWEEN WALL STUDS AT ALL HORIZONTAL SHEET EDGES. 2. PROVIDE NAILING/BLOCKING ABOVE AND BELOW ALL BRACED WALL PANELS PER KSE BRACED WALL DETAILS.

3. SHEATH ALL EXTERIOR WALLS OF THE HOUSE WITH $\frac{7}{16}$ " O.S.B., OR $\frac{15}{32}$ " PLYWOOD, FASTENED PER IRC. AT EXTERIOR CORNERS, SHEATHING SHALL BE FASTENED PER KSE BRACED WALL DETAILS. AT INTERIOR WALL INTERSECTIONS, FASTEN STUDS & WALL BRACING PER KSE BRACED WALL DETAILS.

4. BRACED WALL PANELS AND ENGINEERED SHEAR WALLS ARE PROVIDED PER IRC. PANEL LENGTHS SHOWN ON PLANS ARE THE MINIMUM LENGTH REQUIRED.

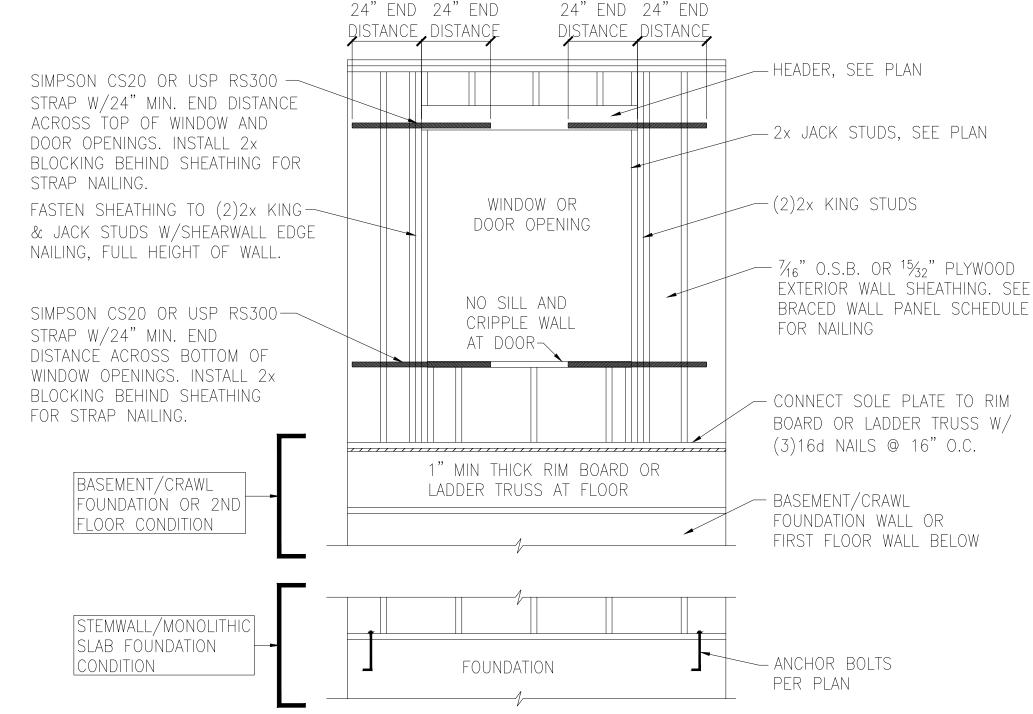

🗩 WINDOW OR DOOR REINFORCEMENT IN ENGINEERED SHEAR WALL ✓ JONLY REQUIRED WHERE SPECIFED ON PLANS.

FASTENERS

NAILS AT 6" O.C. AT SHEET EDGES AND 12" O.C. AT PORTS. ENGINEERED ALTERNATIVE: 16 GAGE BY 1.75" LONG AT SHEET EDGES AND 6" O.C. AT INTERMEDIATE SUPPORTS

OOFING NAILS, 6d COMMON NAILS, OR 1.25" LONG TYPE W AT 7" O.C. AT SHEET EDGES AND INTERMEDIATE SUPPORTS.

OOFING NAILS, 6d COMMON NAILS, OR 1.25" LONG TYPE W AT 4" O.C. AT SHEET EDGES AND INTERMEDIATE SUPPORTS.

ROOFING NAILS, 6d COMMON NAILS, OR 1.25" LONG TYPE W AT 7" O.C. AT SHEET EDGES AND INTERMEDIATE SUPPORTS.


NAILS AT 6" O.C. AT SHEET EDGES AND 12" O.C. AT PORTS. ENGINEERED ALTERNATIVE: 16 GAGE BY 1.75" LONG . AT SHEET EDGES AND 6" O.C. AT INTERMEDIATE SUPPORTS

AT 6" O.C. AT SHEET EDGES AND 12" O.C. AT PORTS. CONTINUOUS OSB AROUND DOOR/WINDOW OPENINGS AT 4" O.C. AT SHEET EDGES AND 12" O.C. AT PORTS. CONTINUOUS OSB AROUND DOOR/WINDOW OPENINGS AT 3" O.C. AT SHEET EDGES AND 12" O.C. AT

PORTS. CONTINUOUS OSB AROUND DOOR/WINDOW OPENINGS




IEERING KERTOWN, PA 18951 (715) 804-4449 Ζ ШU S ш SШ etails \square -olina \sim D S Note \Box . ∟. ≥ $\frac{1}{2}$ $\overset{\mathrm{O}}{\sim}$ Wa 20 $\overline{}$ to eigh \bigcirc Ū \bigcirc \bigcirc \supset \ltimes \cap Project #: 214-22000 Designed By:KRK Checked By: Issue Date: 3/6/23 Re-Issue: Scale: 1/8"=1'-0" @ 11x17 1/4"=1'-0" @ 22x34 SD-3

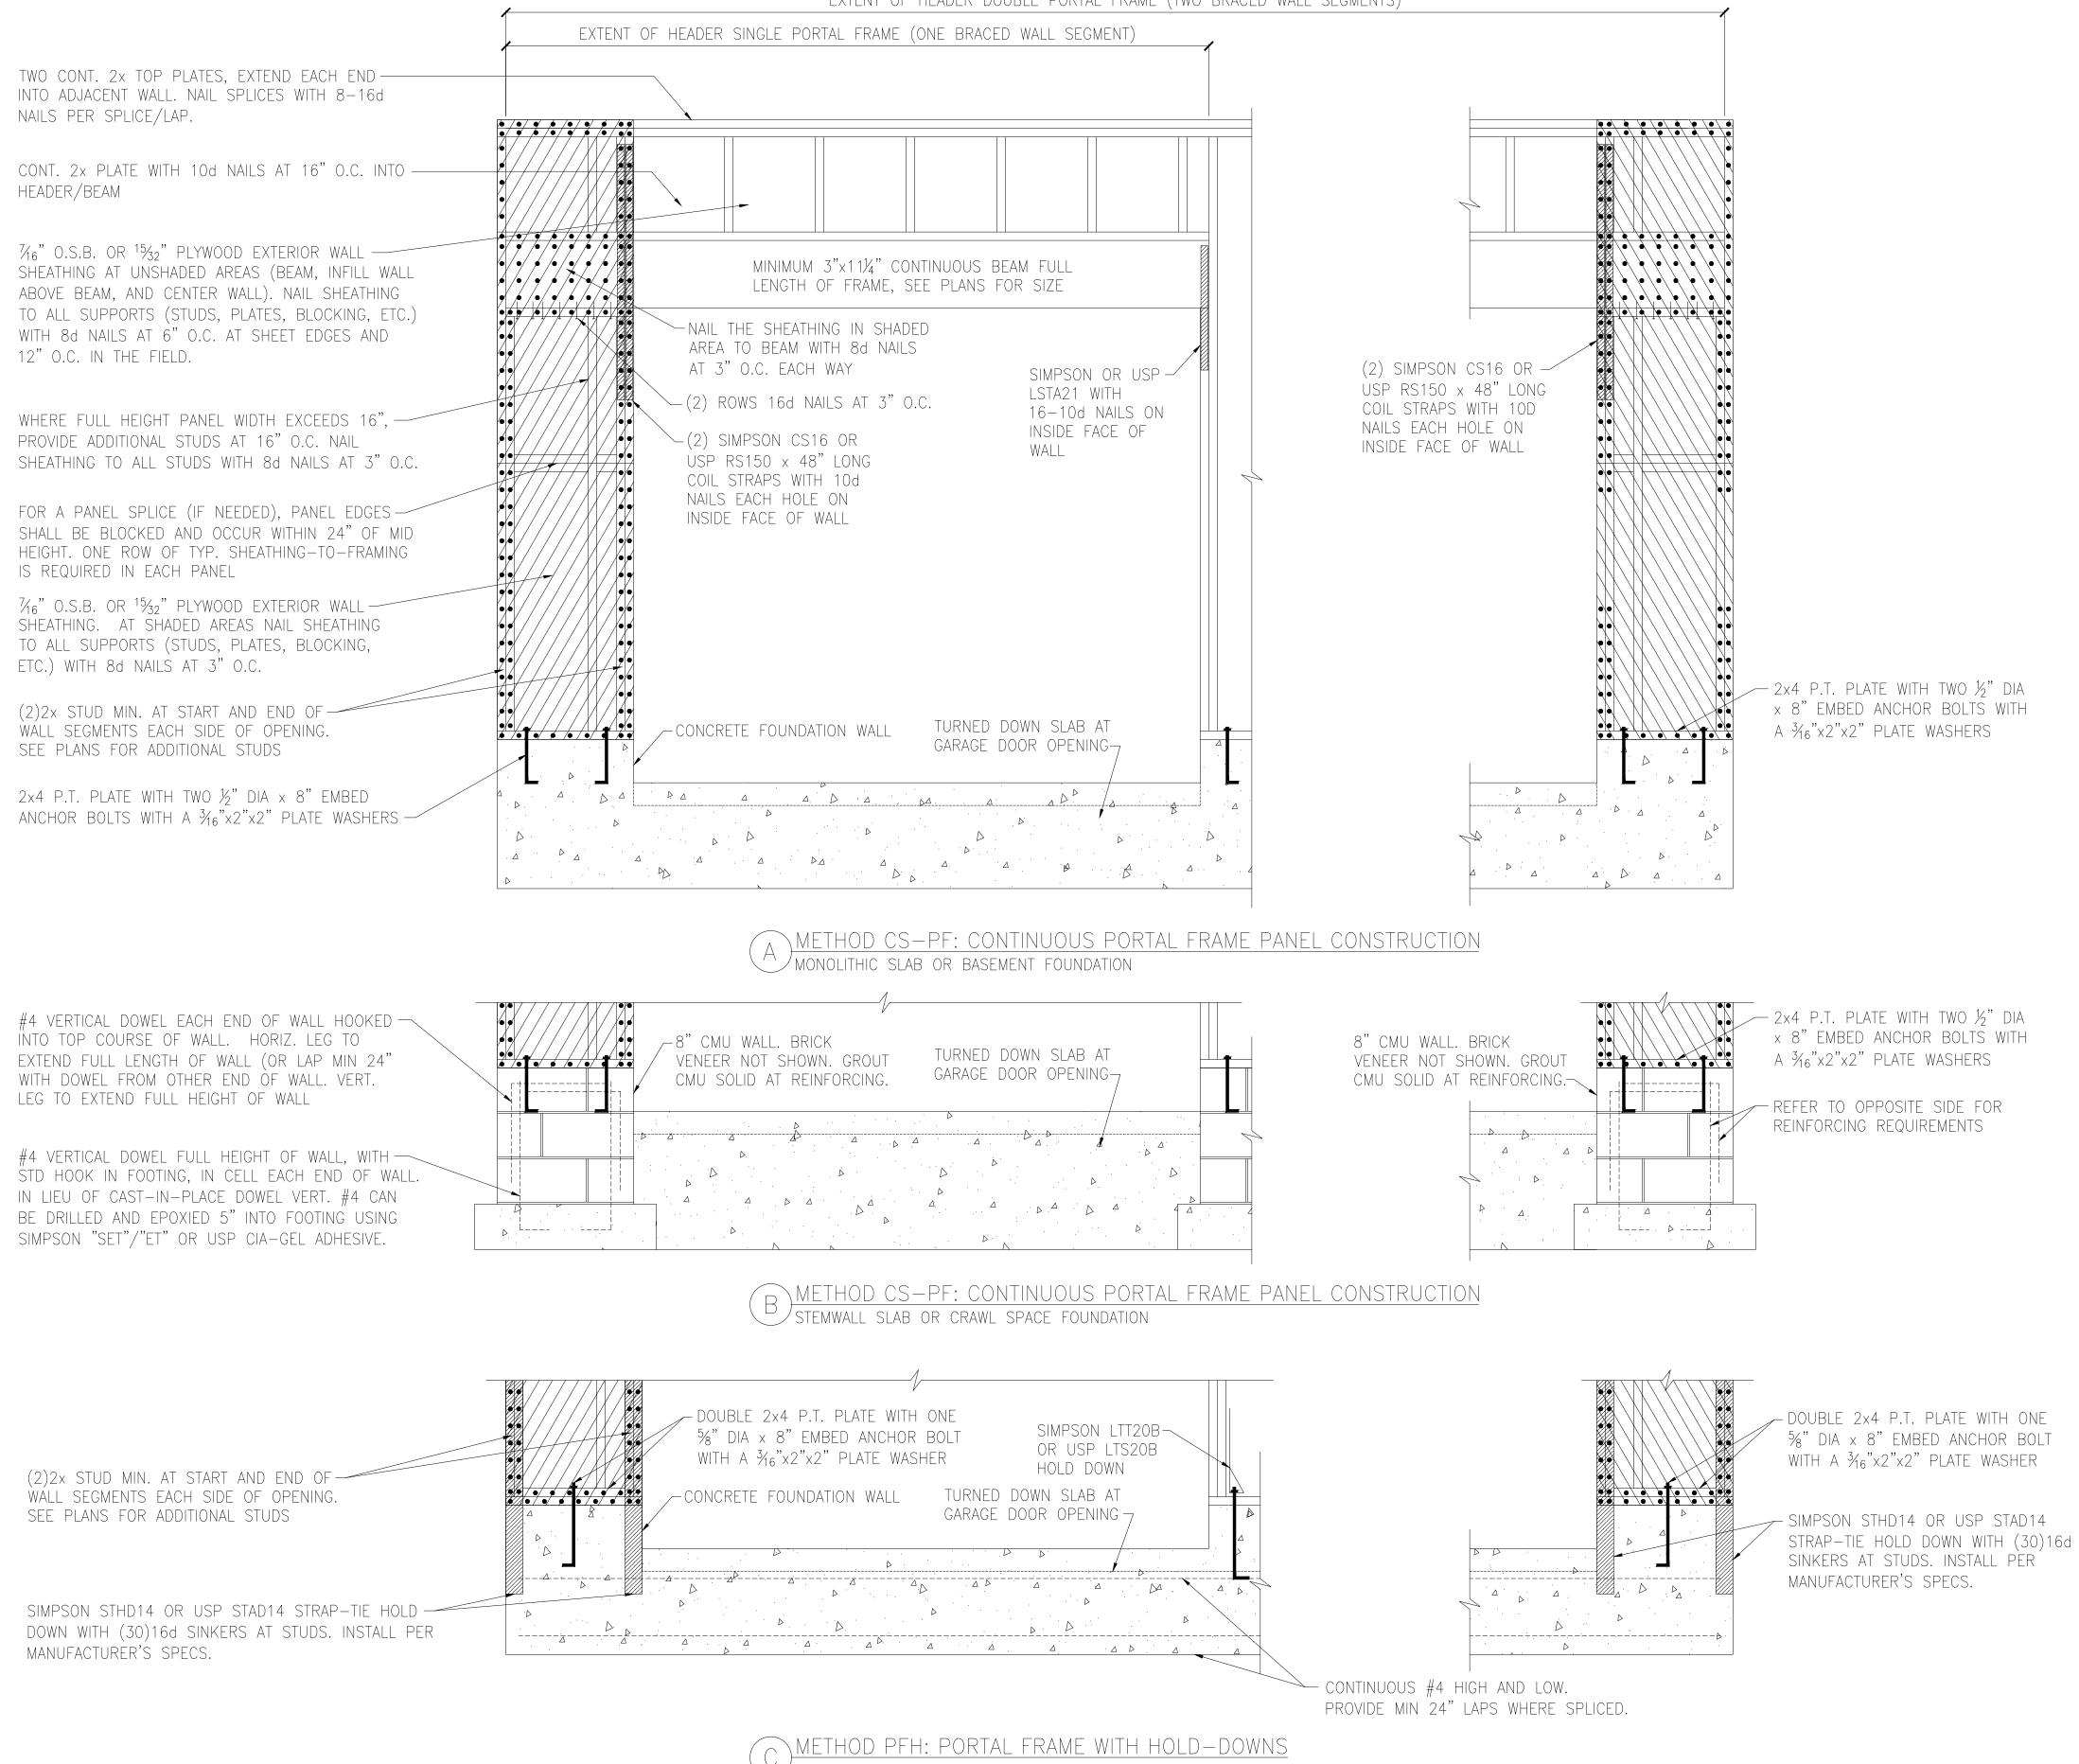







MONOLITHIC SLAB OR BASEMENT FOUNDATION

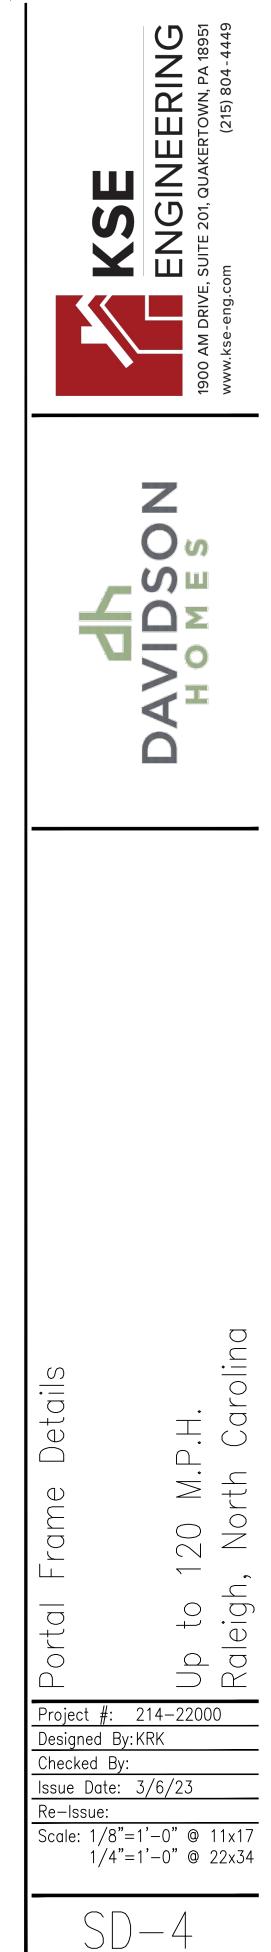

Tobacco Road Lot 107

NC Firm #C-2101 KH CAR SEAL

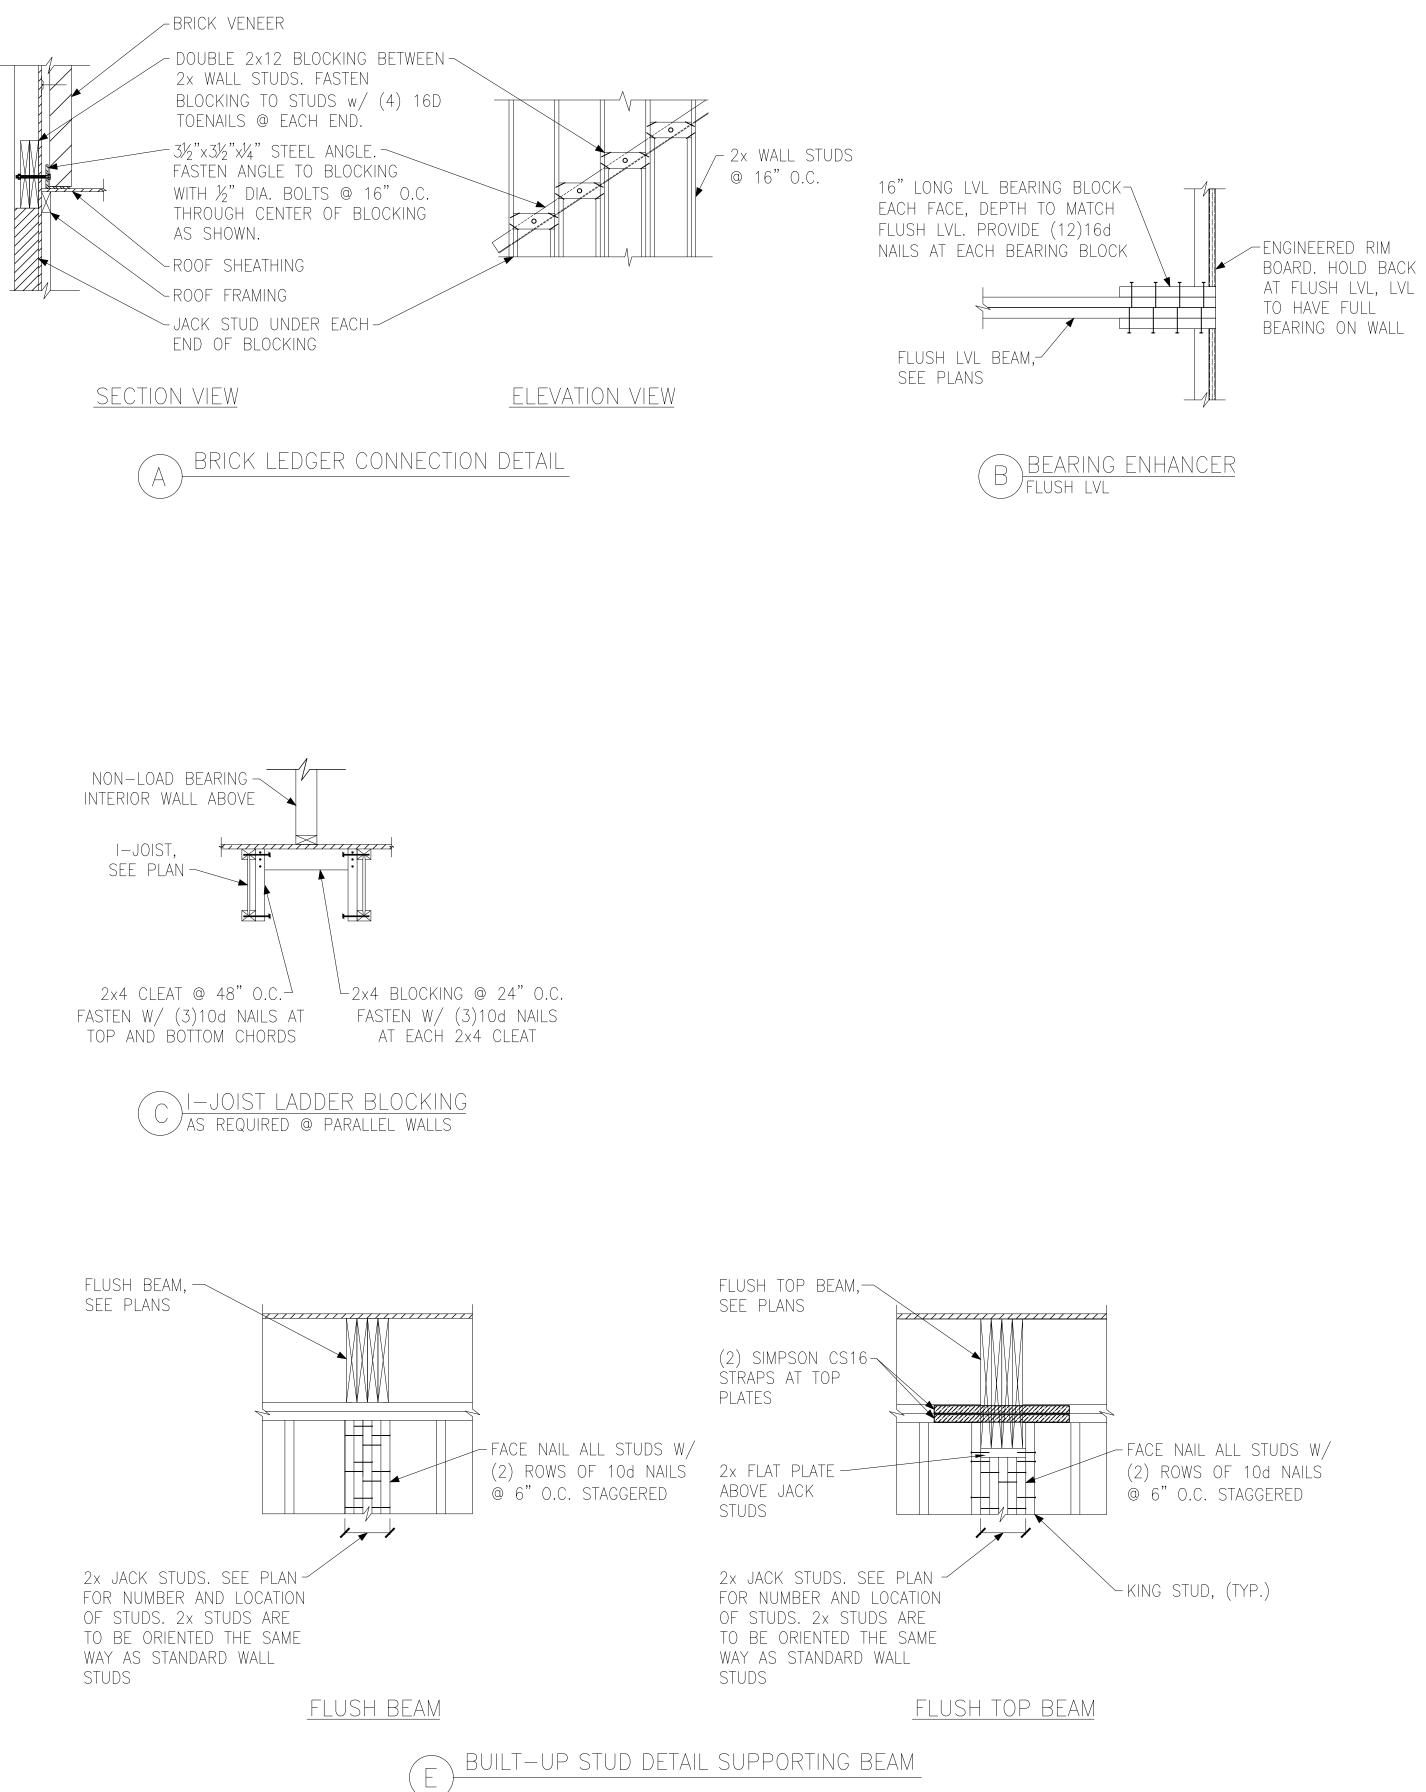


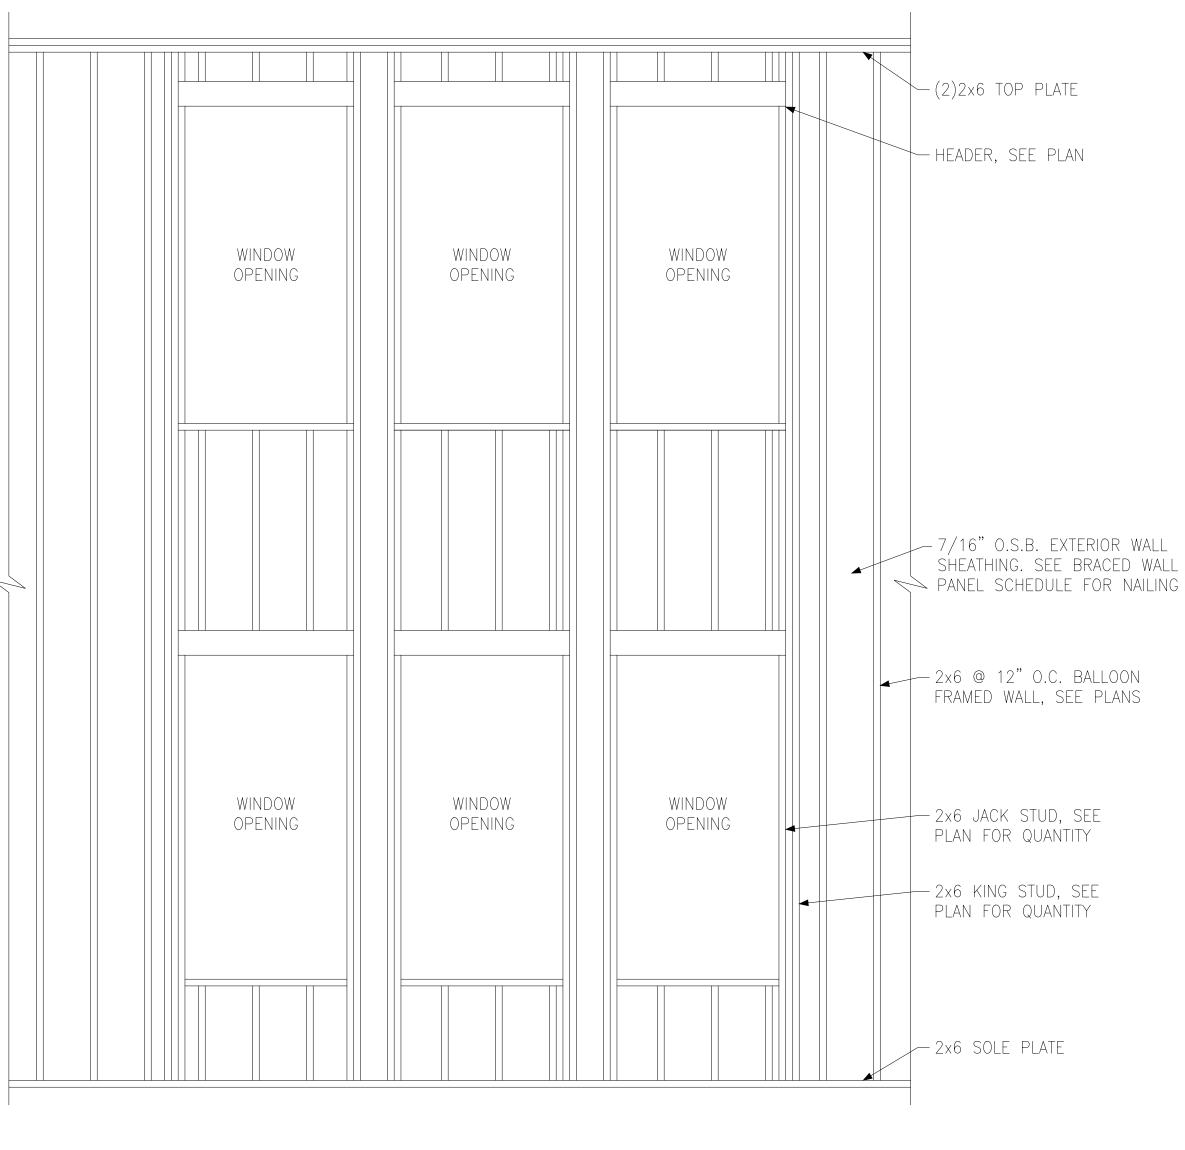



D BALLOON FRAMED WALL DETAIL N.T.S.



NC Firm #C-2101 HCAR FESS SEAL

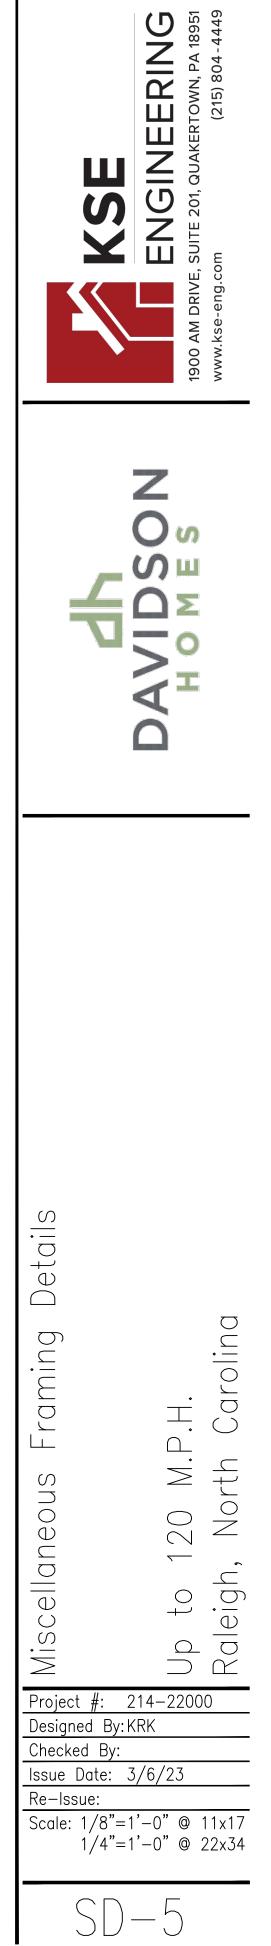

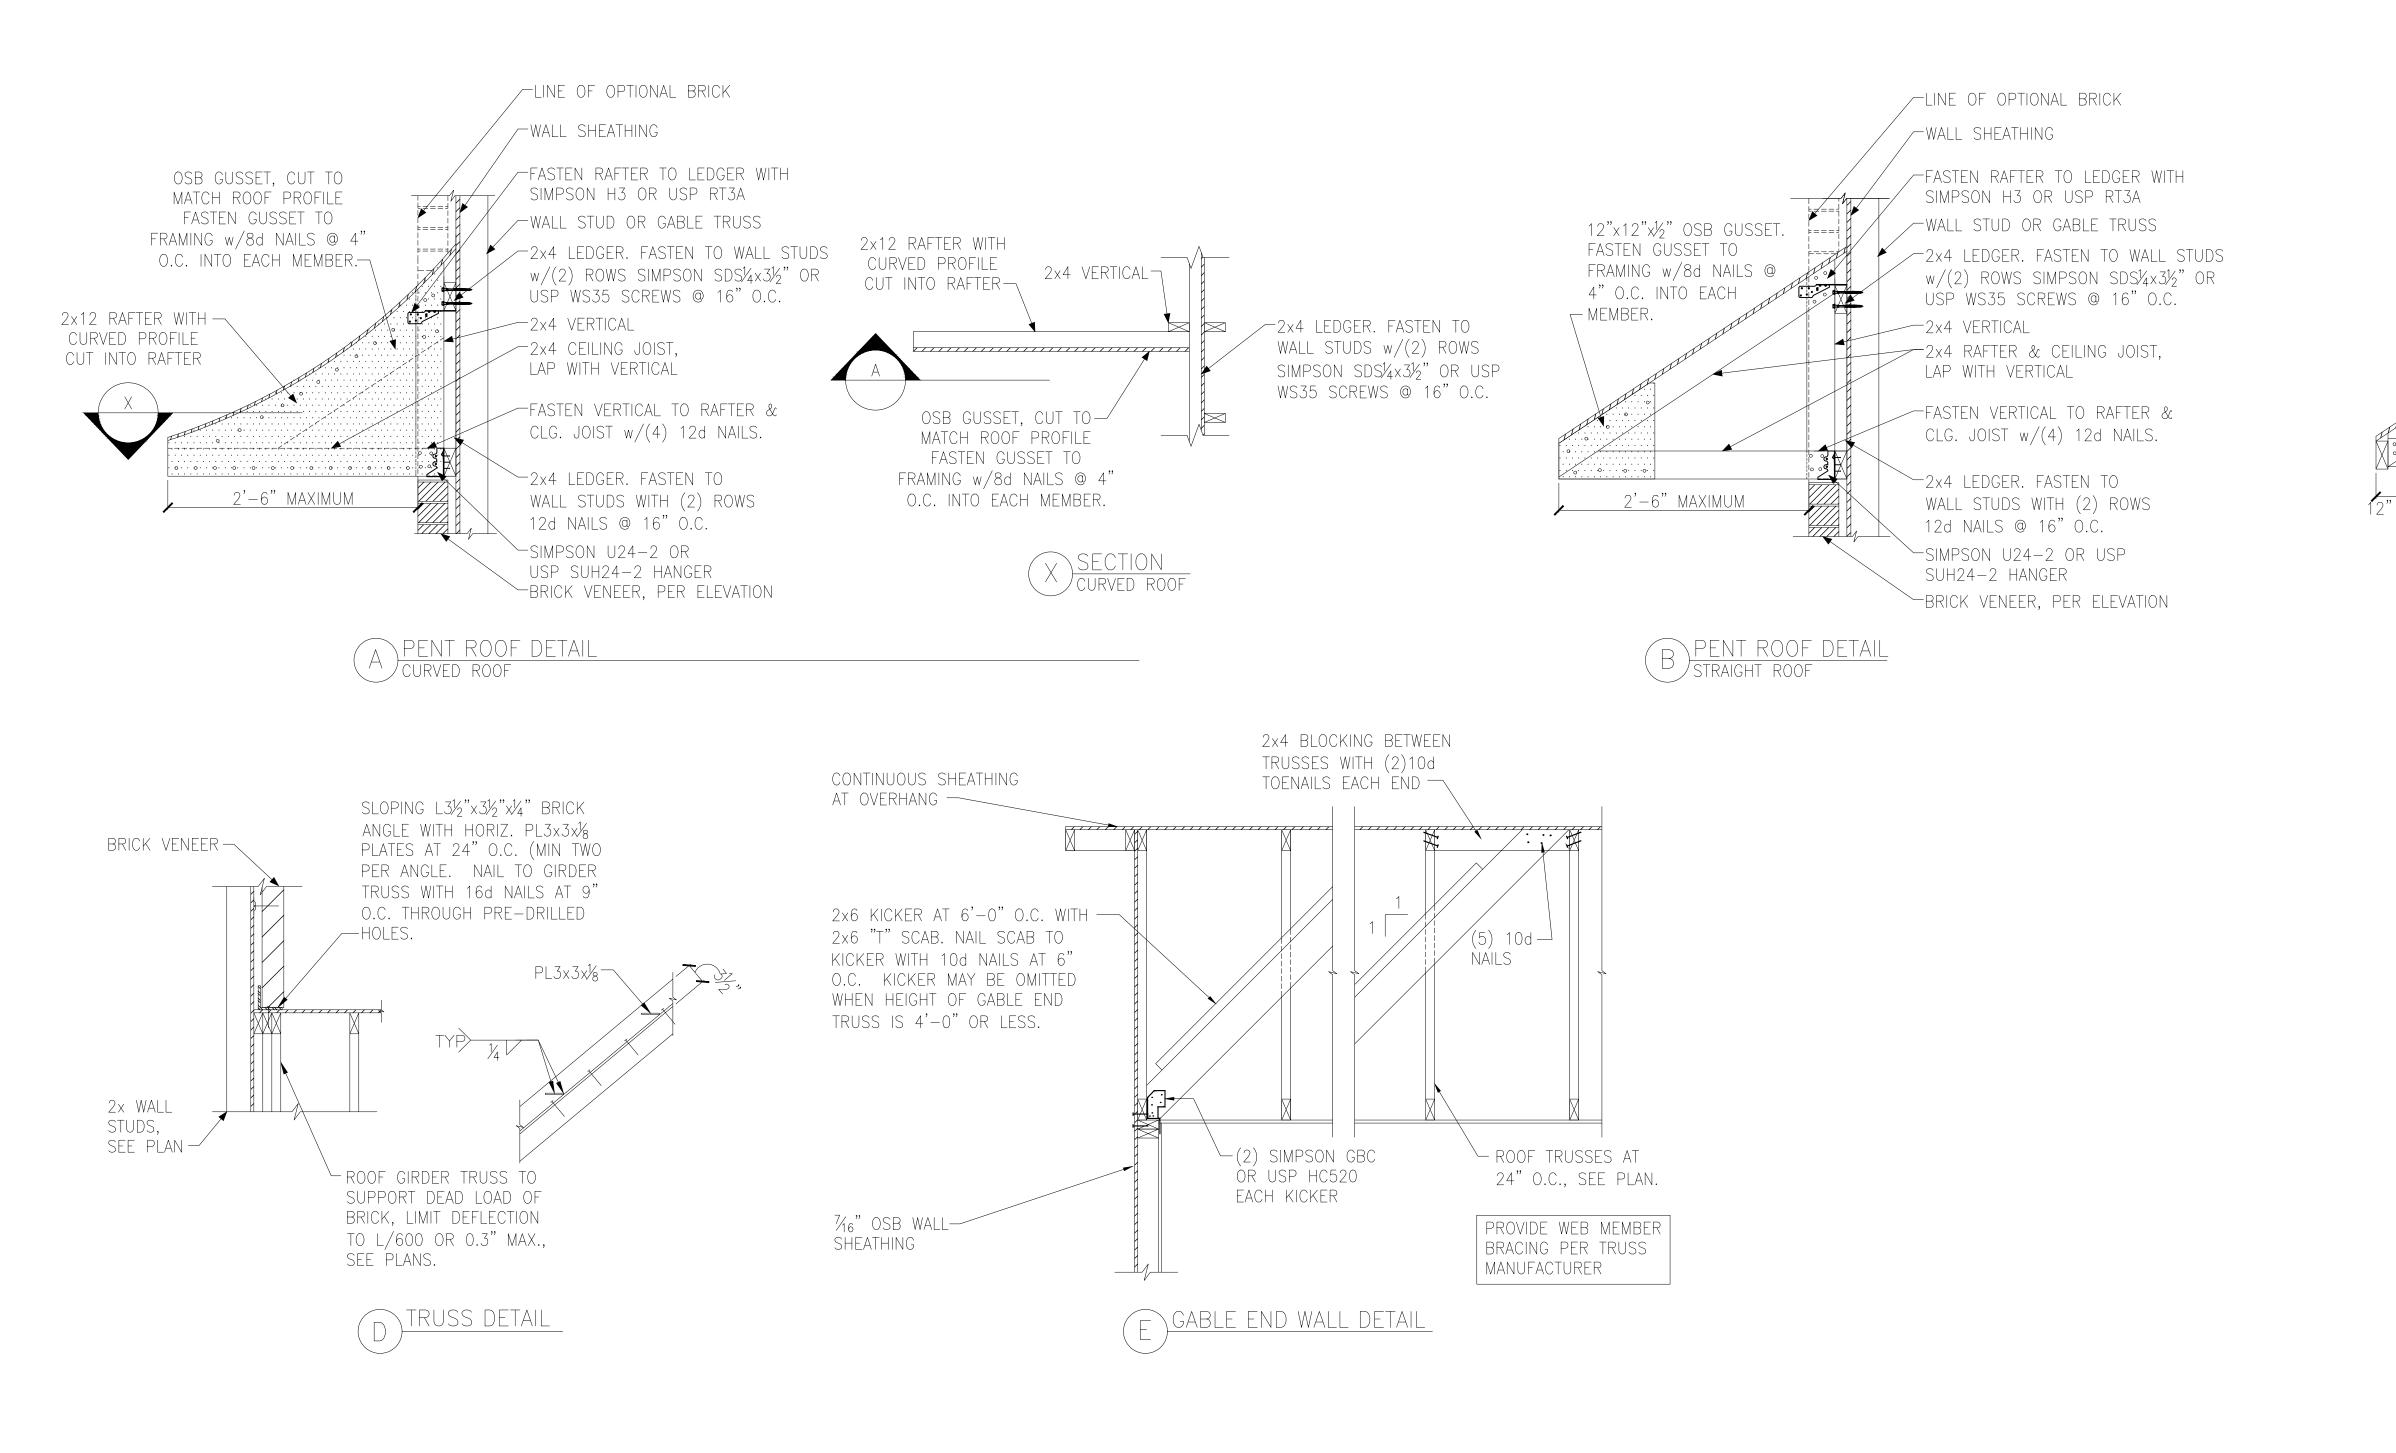

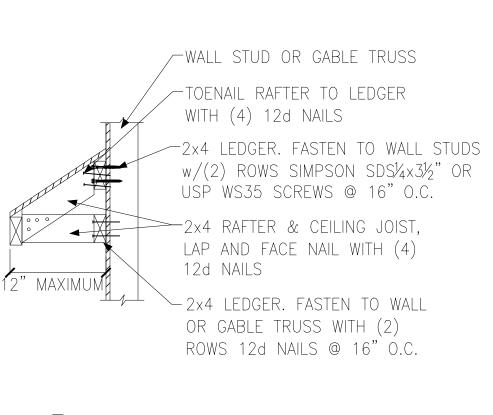

C EYEBROW ROOF DETAIL STRAIGHT ROOF

Details Carolina Framing \Box . J. \downarrow Miscellaneous Nor 20 $\overline{}$ aleigh. \bigcirc +U D D Project #: 214-22000 Designed By: KRK Checked By: Issue Date: 3/6/23 Re-Issue: Scale: 1/8"=1'-0" @ 11x17 1/4"=1'-0" @ 22x34 SD-6

JEERING KERTOWN, PA 18951 (215) 804 - 4449

Ζ

C

O თ

ŚШ

ш

Ш S


 \mathbf{Y}

Tobacco Road Lot 107

NC Firm #C-2101 SEAL 046096 1. Juny Monager MGINEER OCTIVITY MGINEER MG







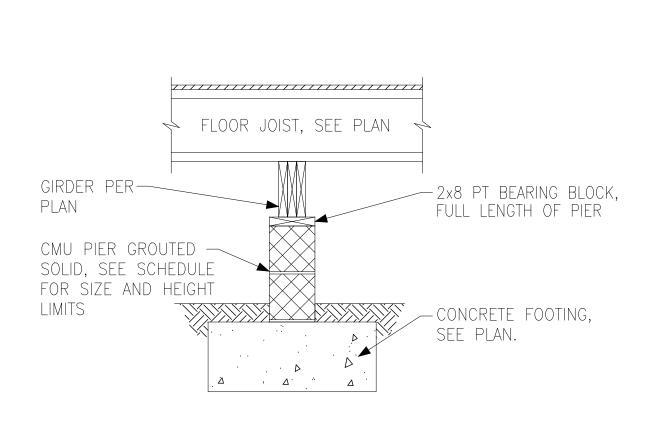



FOUNDATION SECTION

L/EXTERIOR GARAGE WALL

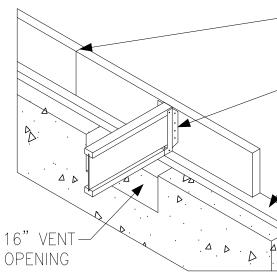

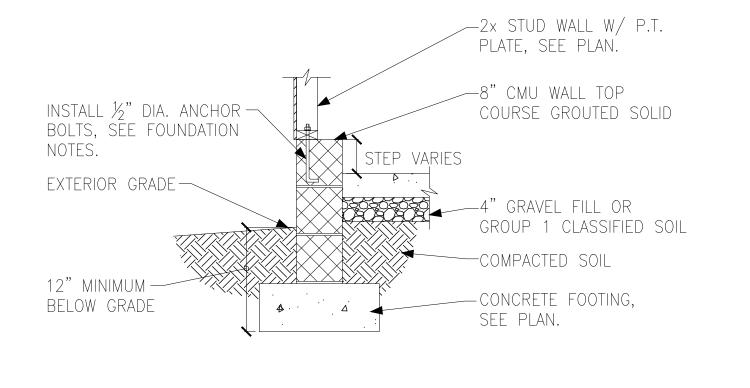


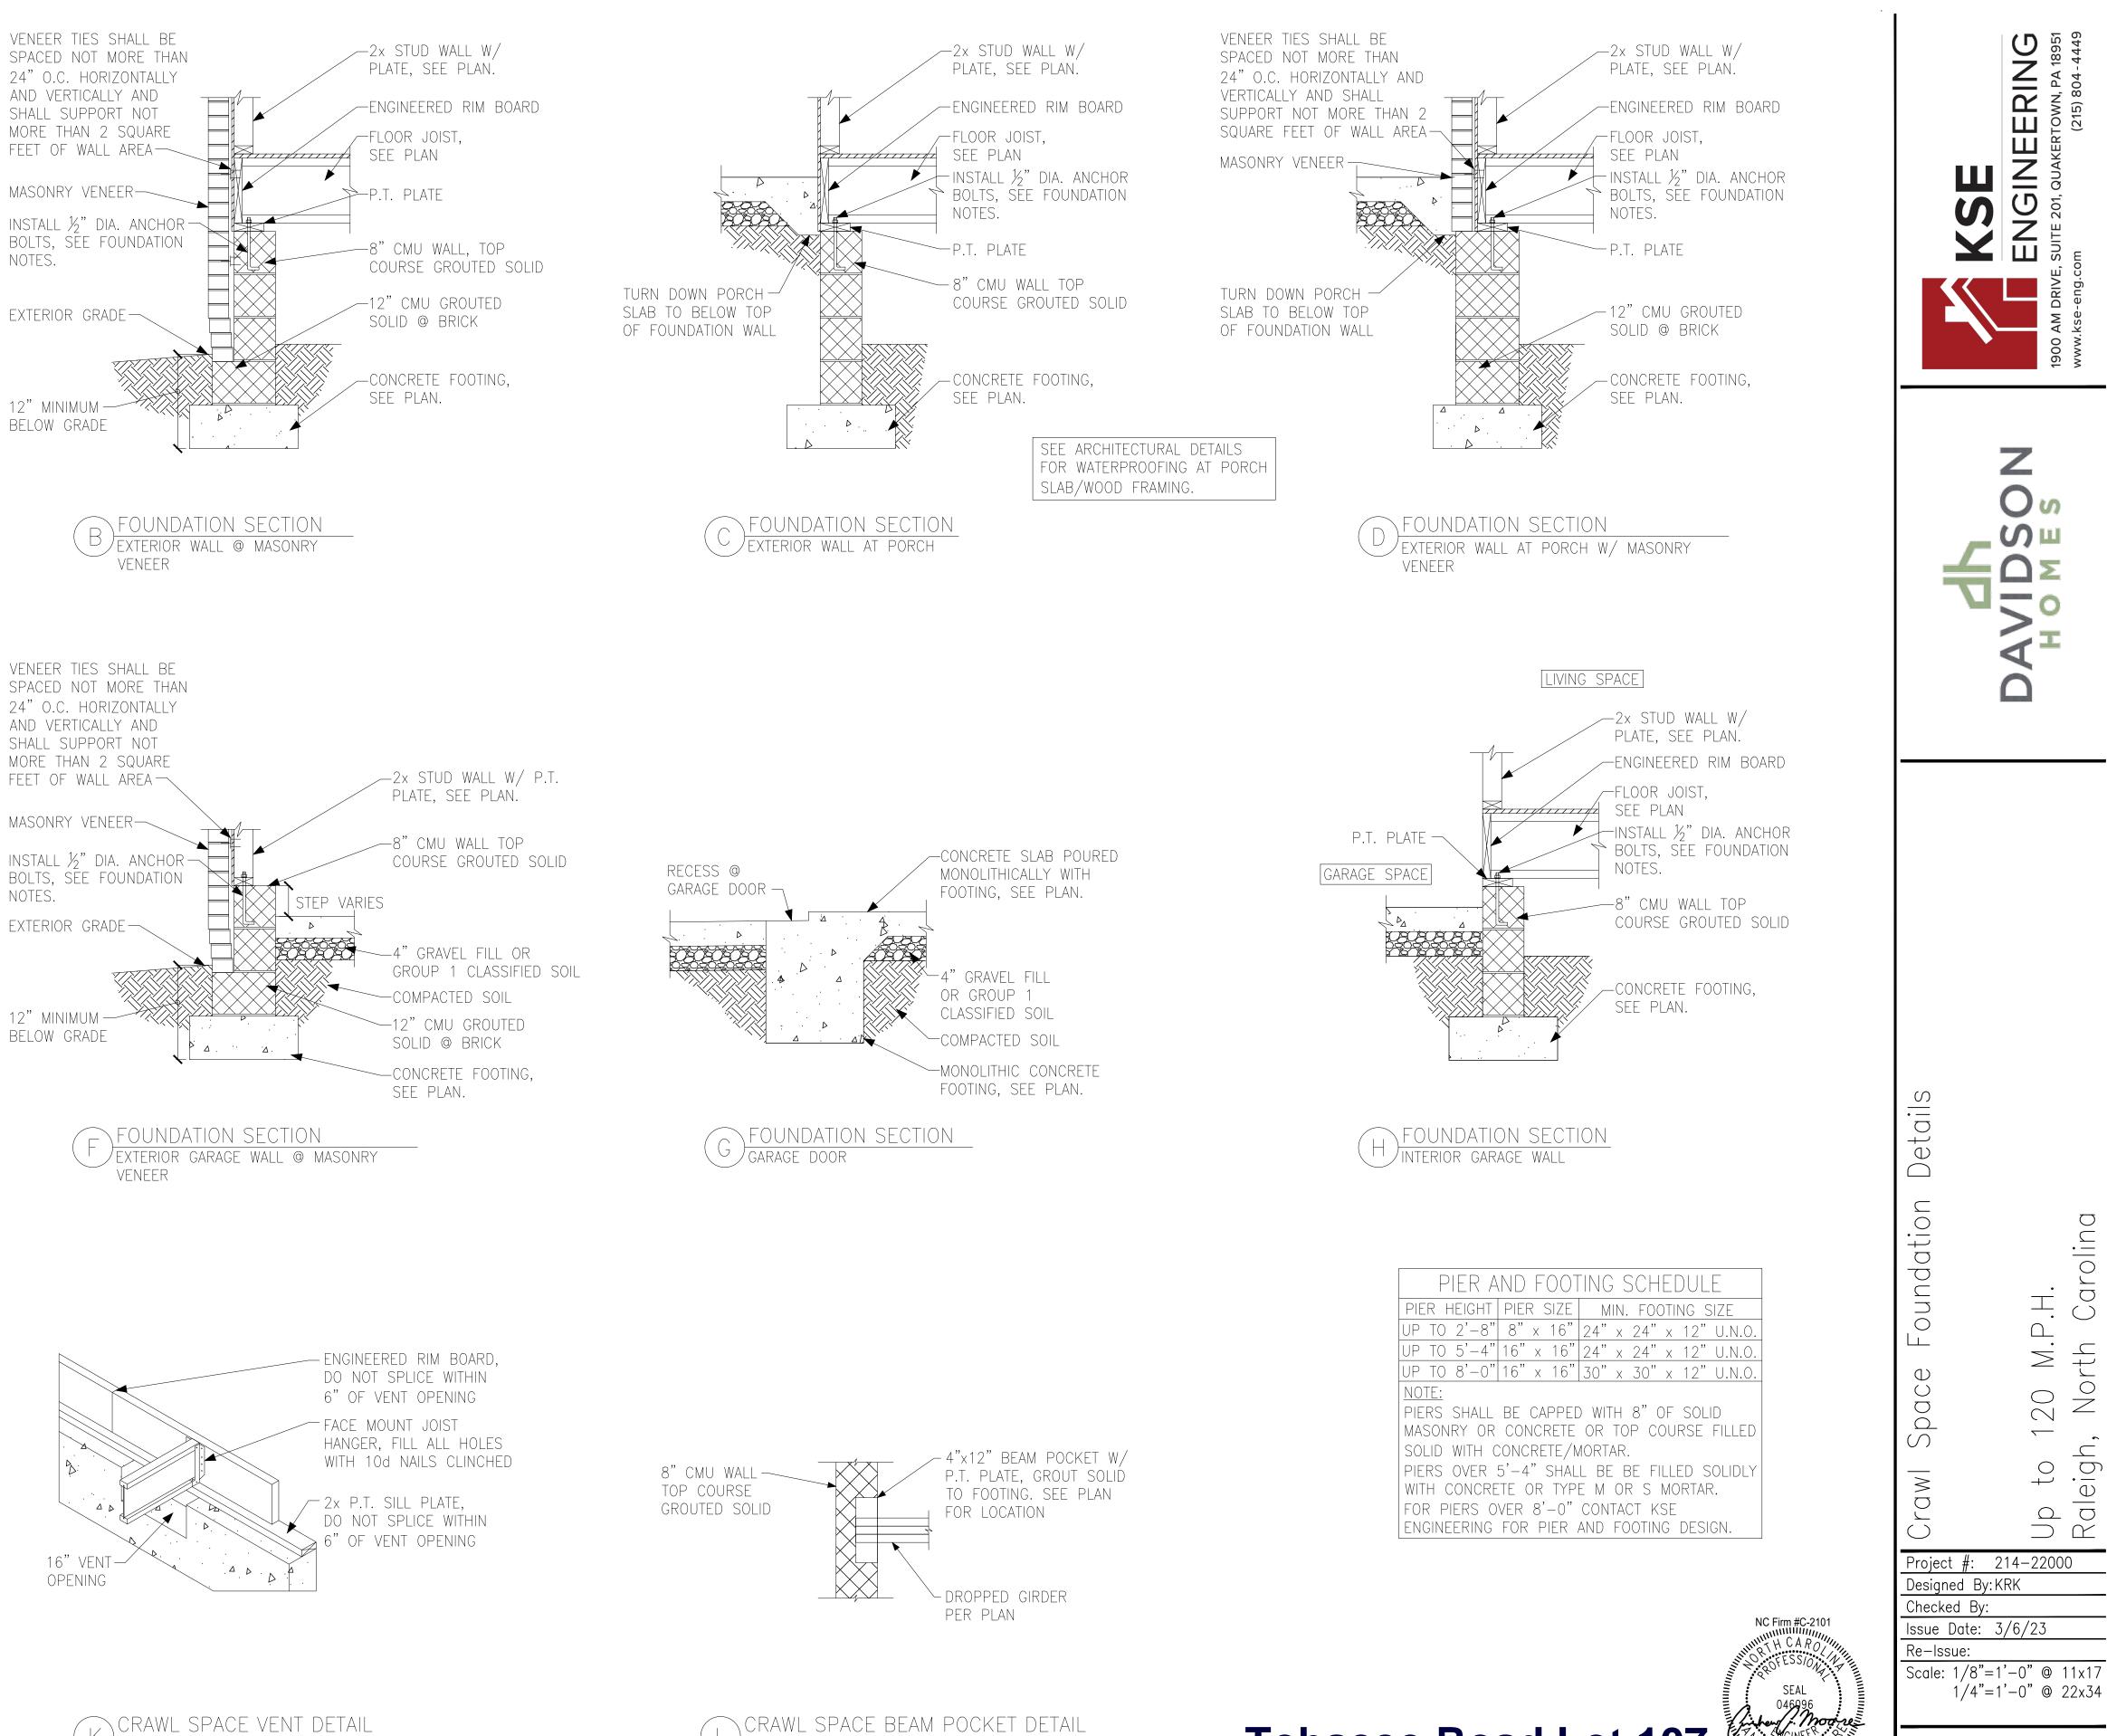

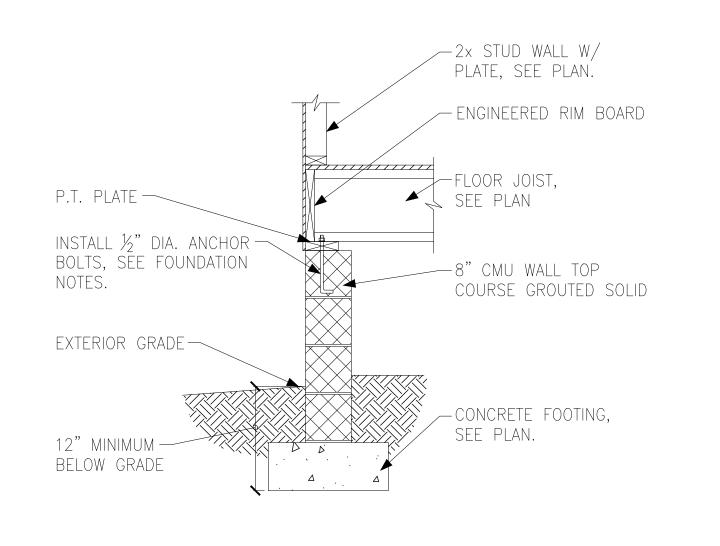

FOUNDATION SECTION

/exterior wall

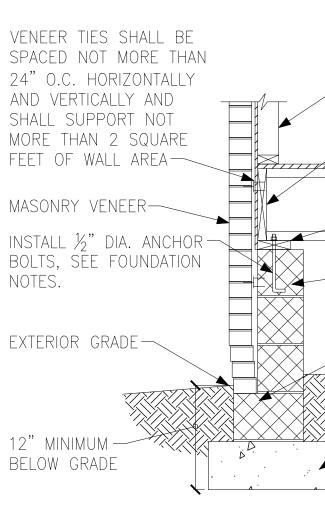

CRAWL SPACE BEAM POCKET DETAIL





SD-9

		<u>}</u>	43	3-11-00			
		12-11-00	16-01	-00		14-11-00	
51-09-00	24.04-00	BM2 10/08 1-10-00 F13 2-00-00 F15 2-00-00 F15 -00	F6L	2-00-00 2-00-00 2-00-00 2-00-00 2-00-00 2-00-00 2-00-00 2-00-00 0 2-00-00 0 2-00-00 0 2-00-00 0 0 0 0 0 0 0 0 0 0 0 0		F04 1. 14-04-00 2. F04 2. F03 1. 503 2. F03 2.	
	-08	F15 2-00-00 F15 2-00-00 F15 2-00-00 F15 1-08-00 F15	F10 1-02-08 © F11G 1-05-04 F12 2-00-00 F12 2-02-00 F12 2-02-00 F12 2-02-00	F3C	16 ⁻	F02 2.	-00-
	12-03-08		2-00-00 		21-07-08	27-11-08	
		12-11-00	8-01-00		22-11-00		

	Products							
PlotID	Length	Product	Plies	Net Qty	Fab Type			
BM2	14-00-00	1-3/4" x 14" VERSA-LAM® LVL 2.1E 3100 SP	2	2	MFD			
BM1	10-00-00	1-3/4" x 14" VERSA-LAM® LVL 2.1E 3100 SP	2	2	MFD			
BM3	22-00-00	1-3/4" x 18" VERSA-LAM® LVL 2.1E 3100 SP	3	3	MFD			

	HANGER LIS	т
А	LUS410	23
В	HHUS410	1
С	THA422	2

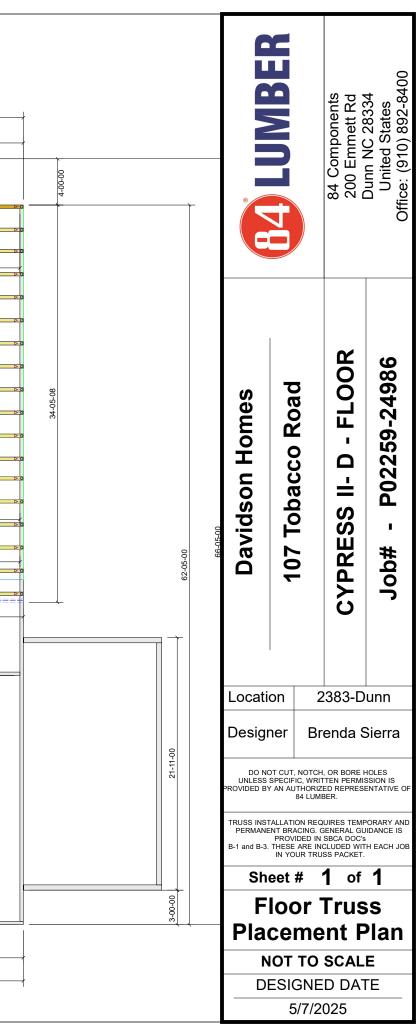

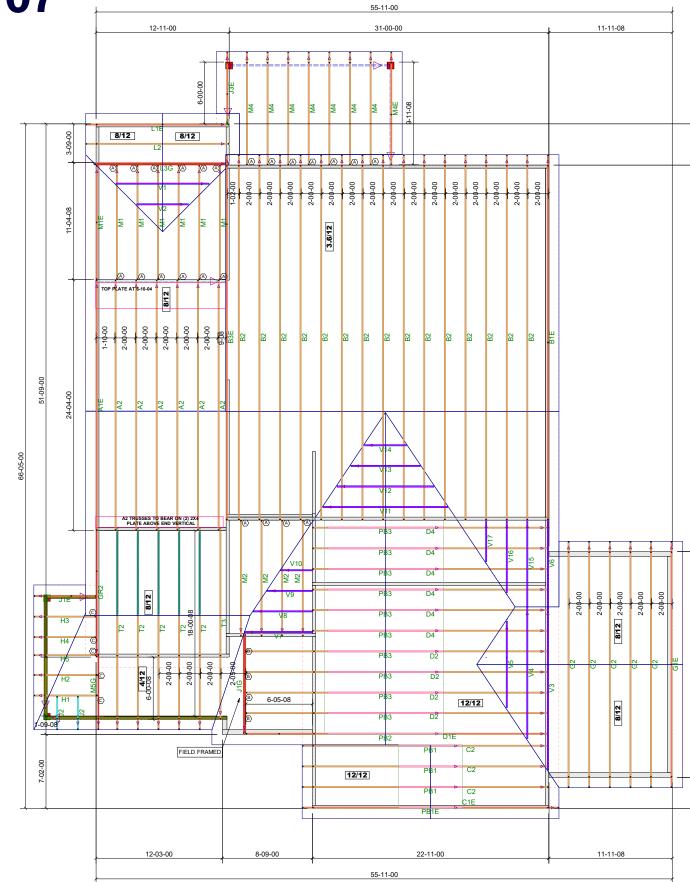

HANGER LIST						
А	LUS26	23				
В	HUS26	3				
С	LUS24	5				

			U4 LUWBER		84 Components 200 Emmett Rd	Dunn NC 28334 United States Office: (910) 892-8400	
 66-05-00		Davidson Homes	107 Tohacco Road		CYPRESS II - D - ROOF	Job# - P02259-24985	
		Locati	on	2	202		
		Desig			383-D enda S		
		DO NOT CUT, NOTCH, UNLESS SPECIFIC, WRIT PROVIDED BY AN AUTHORIZE 84 LUMB TRUSS INSTALLATION REQU			TTEN PERMISSION IS 2ED REPRESENTATIVE OF BER.		
		B-1 and B-3.	PROVID	DED IN S ARE INC R TRUS	SBCA DOC's	H EACH JOB	
					rus	-	
					nt F		
		NOT TO SCALE DESIGNED DATE					
		5/7/2025					